

[illegible]

	BRICK
	SAND
	CORTEX
	CORRUMPT
	CORRUPT
	COCK
	SEMI
	GUTTERAL WOOD
	BLOCKING
	FLYWOOD
	GUTTERAL WOOD
	FINISH WOOD
	HOLLOWER
	RADIO ALLOCATION
	BATTEN ALLOCATION

	BUILDING SECTION DRAWING LOCATION SHEET NUMBER
	WALL SECTION DRAWING LOCATION SHEET NUMBER
	DETAIL SECTION DRAWING LOCATION SHEET NUMBER
	DETAIL LOCATION DRAWING LOCATION SHEET NUMBER
	BUILDING ELEVATION DRAWING LOCATION SHEET NUMBER
	INTERIOR ELEVATION DRAWING LOCATION SHEET NUMBER
	WINDOW/DOOR REFERENCE DRAWING LOCATION SHEET NUMBER
	DOOR MARK ROOM NUMBER/DOOR NUMBER
	ASSEMBLY TYPE REFERENCE TO SCHEDULE
ENTRY	ROOM NUMBER/ROOM NAME
	SECTION ELEVATION

ARCHITECTURAL	A1	GENERAL INFO AND SITE PLAN
	A2	FLOOR PLAN & SCHEDULES
	A3	ROOF PLAN & DETAILS
	A4	EXTERIOR ELEVATIONS
	A5	SECTIONS
	A6	INTERIOR ELEVATIONS \$ DETAILS
	A7	REF. CEIL. PLAN & DETAILS
STRUCTURAL	S1	FOUNDATION PLAN
	S2	ROOF FRAMING PLAN
	S3	DETAILS
	S4	DETAILS
MECHANICAL	M1	LEGEND, SCHEDULES & DETAILS
	M2	FOUNDATION PLAN – MECHANICAL
	M3	FLOOR PLAN – MECHANICAL
	M4	CEILING/ATTIC PLAN – HVAC
ELECTRICAL	E1	LIGHTING
	E2	POWER AND SIGNAL
	E3	SITE PLAN – ELECTRICAL
LANDSCAPE	L1	PLANTING & IRRIGATION

OWNER:
CITY OF WARRENTON
P.O. BOX 250
WARRENTON, OREGON 97146-0250
(503) 861-9233
(503) 861-2351 FAX


ARCHITECT:
MCM ARCHITECTS
1022 SW SALMON, SUITE 350
PORTLAND, OREGON 97205
(503) 222-5757
(503) 241-1514 FAX

STRUCTURAL ENGINEER:
BERRY/NORDLING ENGINEERS
701 SE MILLER STREET
PORTLAND, OREGON 97202
(503) 231-0717
(503) 231-0718 FAX

MECHANICAL ENGINEER:
CHRIS BILLINGS & ASSOCIATES
4445 SW BARBUR BLVD-2ND FLR
PORTLAND, OREGON 97201
(503) 228-0008
(503) 228-2280 FAX




ELECTRICAL ENGINEER:
COLUMBIA CONSULTING ENGINEERS
620 SW 5TH -SUITE 1220
PORTLAND, OREGON 97204
(503) 243-2850
(503) 224-5046 FAX

8-10-2024 BLOCK 6, TRACT 002
 VACATED BETWEEN 5th AVE
 BETWEEN 5th 3RD AND 5th 4TH AND
 8-10-21-24 BLOCK 11, TRACT 1020
 5th 11-EDITION WARENTON
 INCLUDING VACATED 5th BIRCH
 BETWEEN 5th 3RD AND 5th 4TH
 CITY OF WARENTON
 CLATSOP COUNTY, OREGON
 CITY PARK
 ZONE:
 OCCUPANCY GROUP: E2 1 E3
 UBC CONSTRUCTION TYPE: V-NON RATED
 NO OF STORES: 1 STORYES
 ALLOWED BUILDING AREA:
 FOR DECK AREA: X 2
 ALLOWABLE AREA:
 PROPOSED AREA:
 9100 SF.
 9100 SF.
 10100 SF.
 6540 GSF
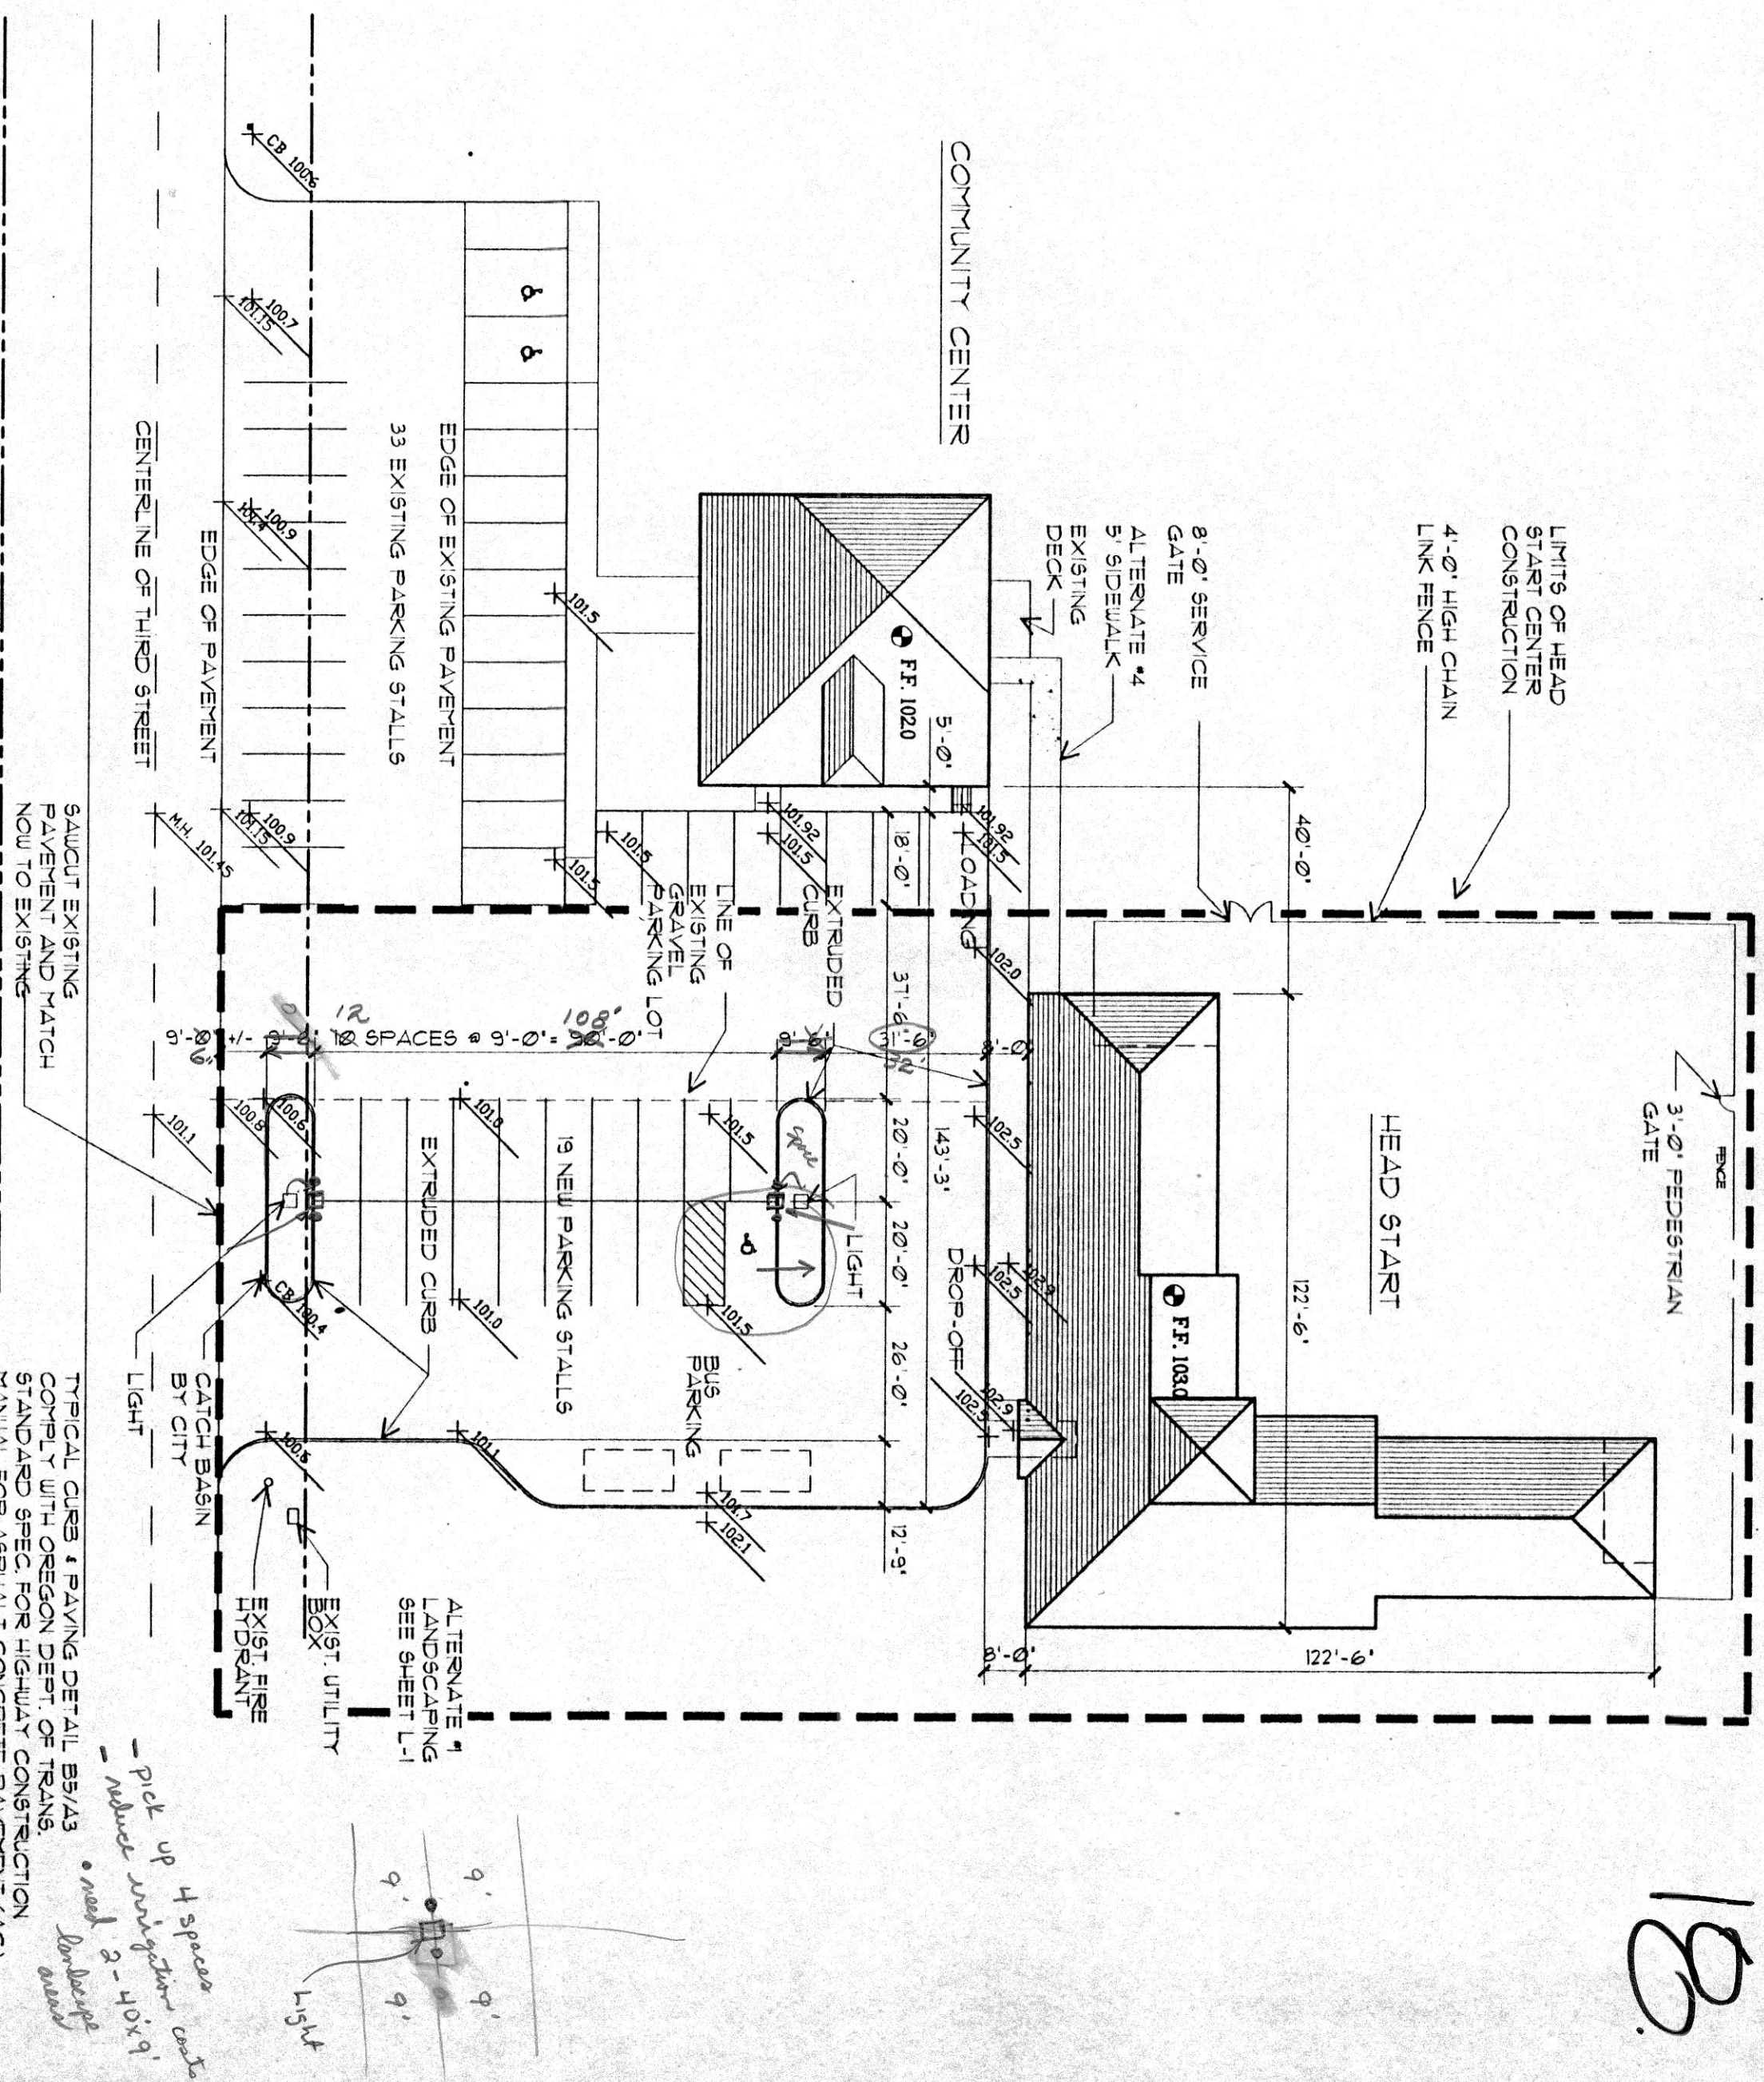
$$1'' = 30'$$


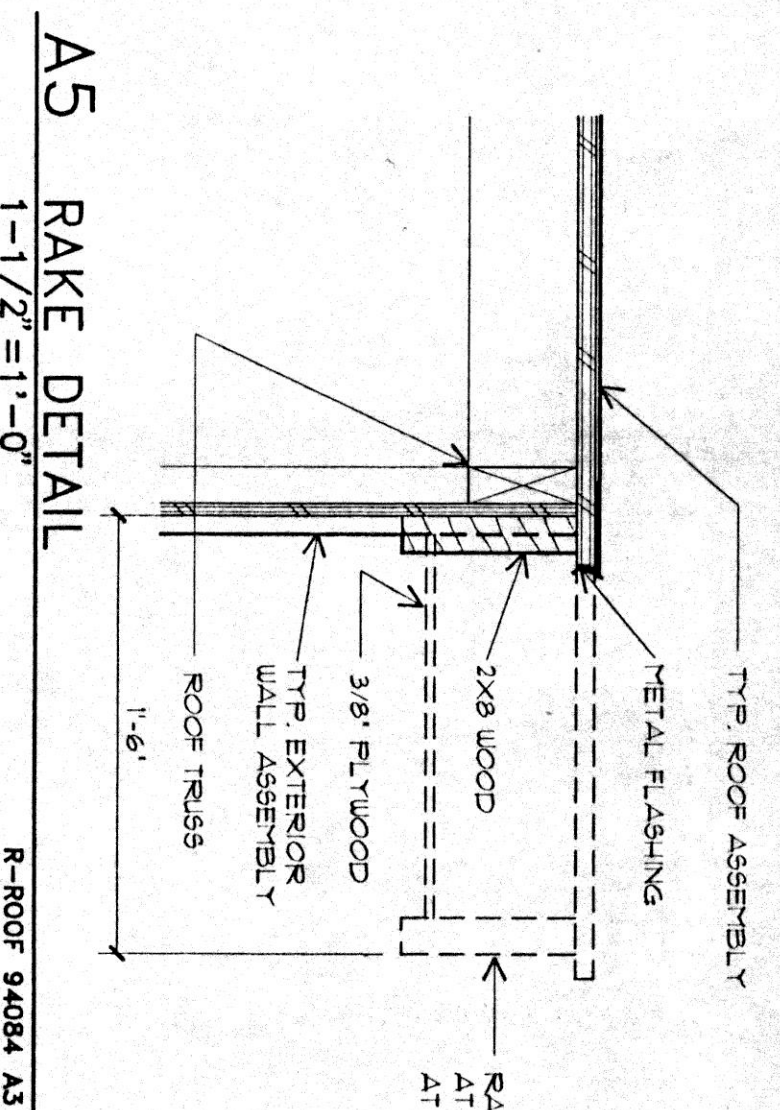
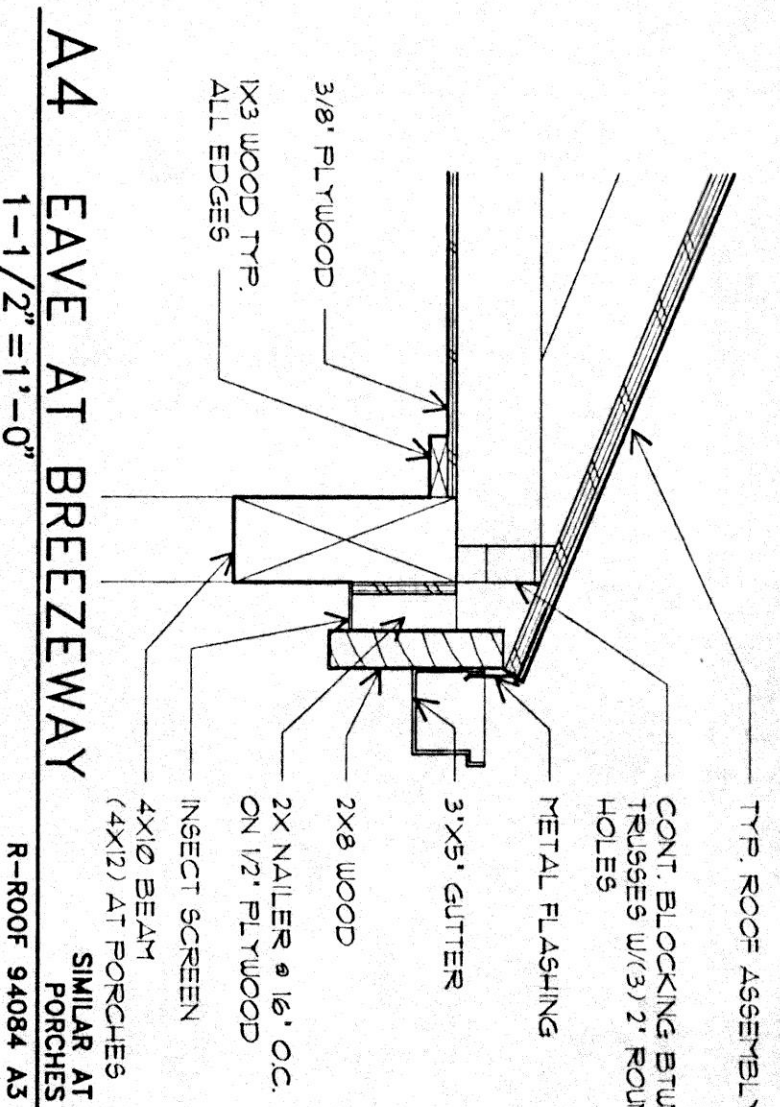
SHEET NO. 1

A1

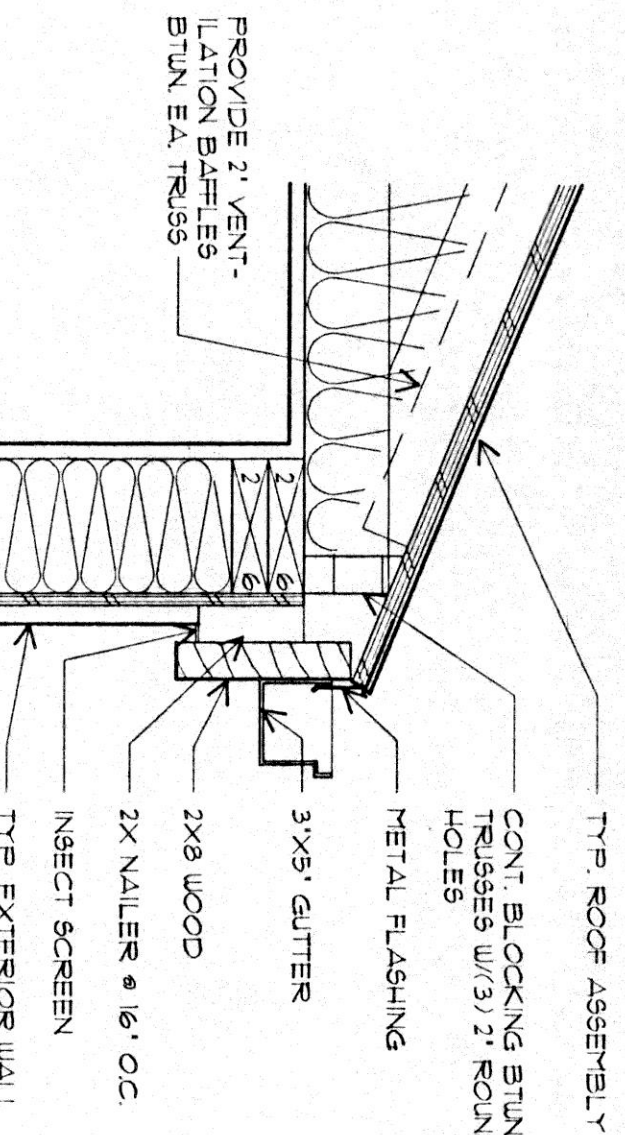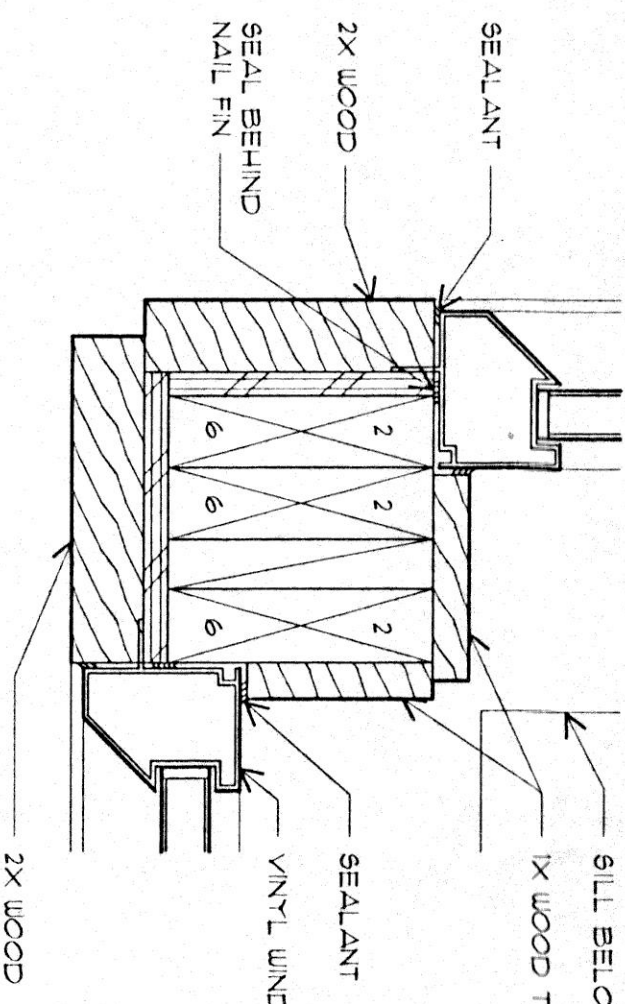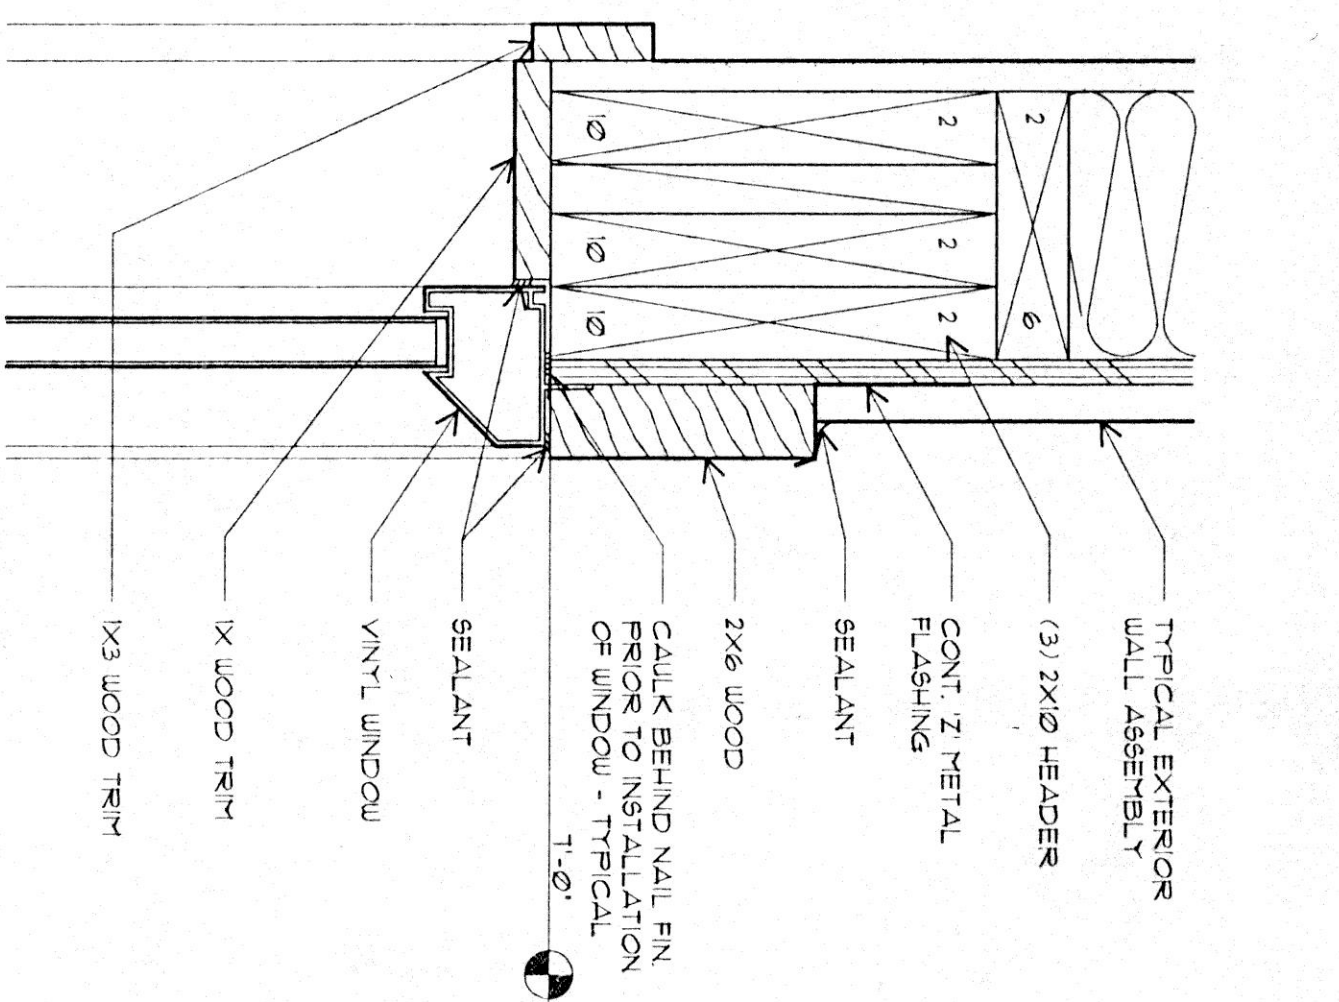

A2 WINDOW JAMB AT CORNER
R-EXWL 94084 A3
3'-1'-0"

A3 EAVE DETAIL
R-ROOF 94084 A3
1'-1/2"=1'-0"



A4 EAVE AT BREZEWAY
R-ROOF 94084 A3
1'-1/2"=1'-0"

A5 RAKE DETAIL
R-ROOF 94084 A3
1'-1/2"=1'-0"





B1 WINDOW HEAD
R-EXWL 94084 A3
3'-1'-0"

B2 EXTERIOR DOOR JAMB
R-EXWL 94084 A3
3'-1'-0"

B3 EXTERIOR DOOR HEAD
R-ROOF 94084 A3
3'-1'-0"

B4 ROOF AT WALL - TYPICAL
R-ROOF 94084 A3
3'-1'-0"

B5 TYPICAL CURB & PAVING DETAIL
R-SITE 94084 A3
1'-1/2"=1'-0"

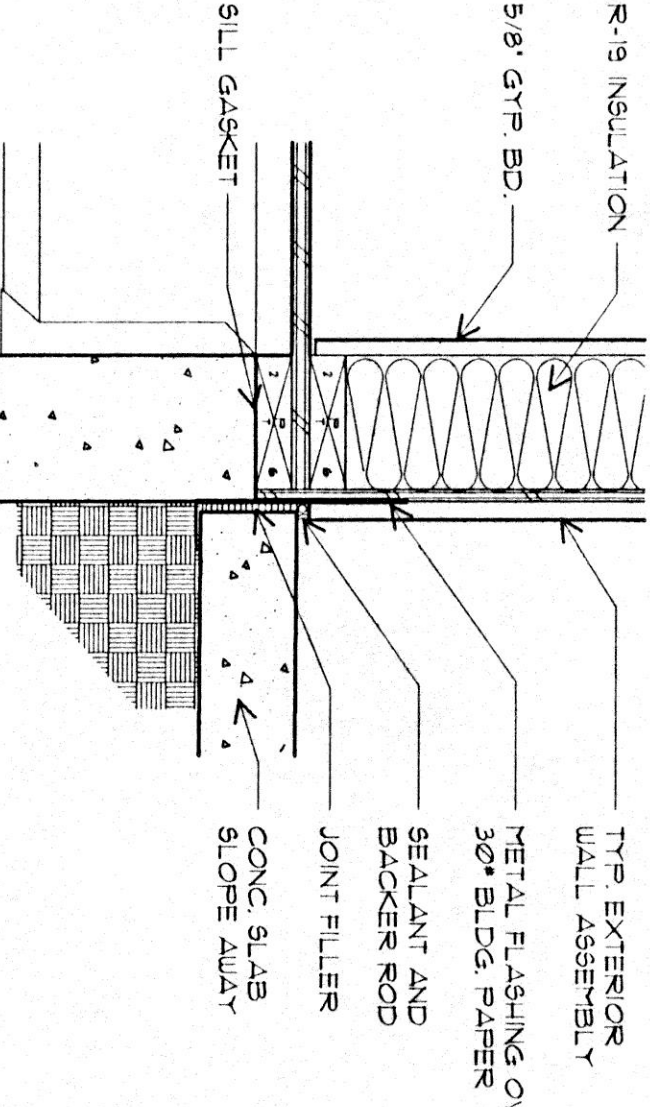
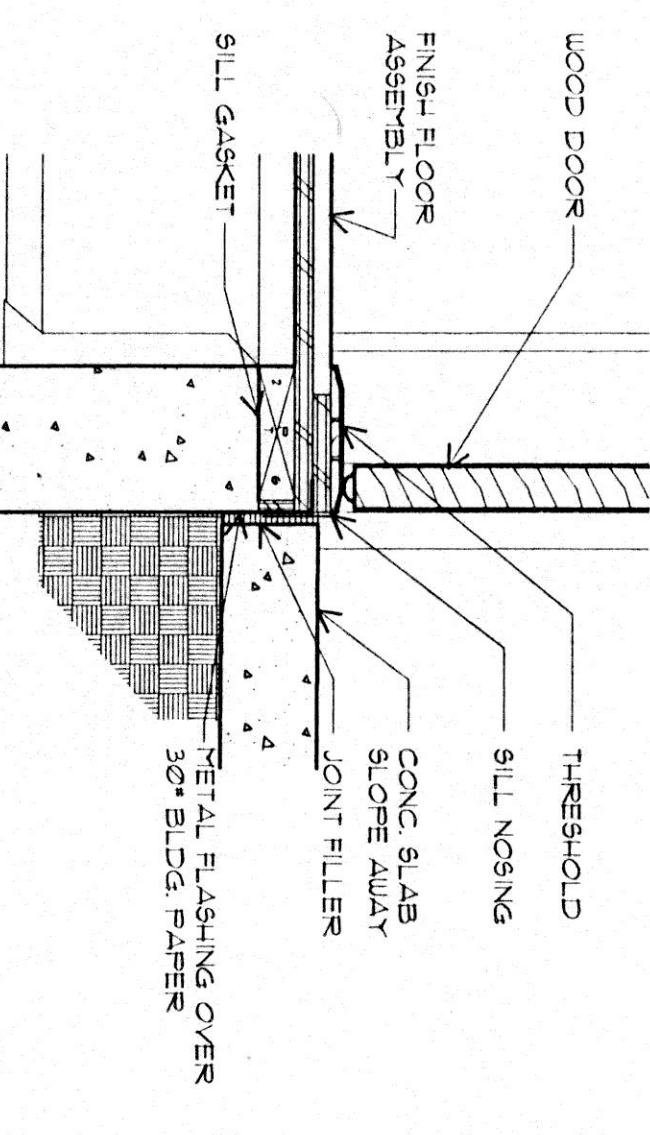
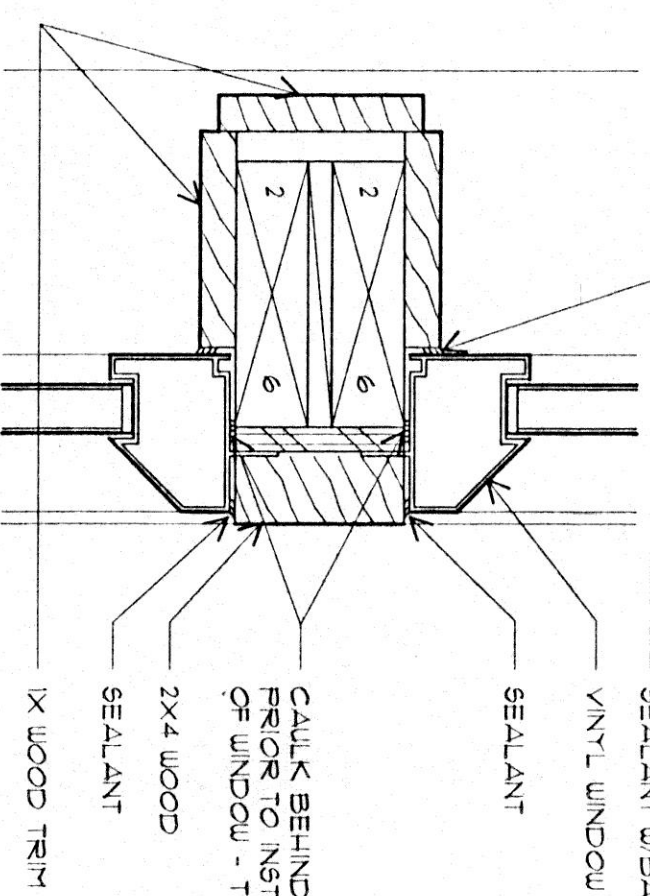
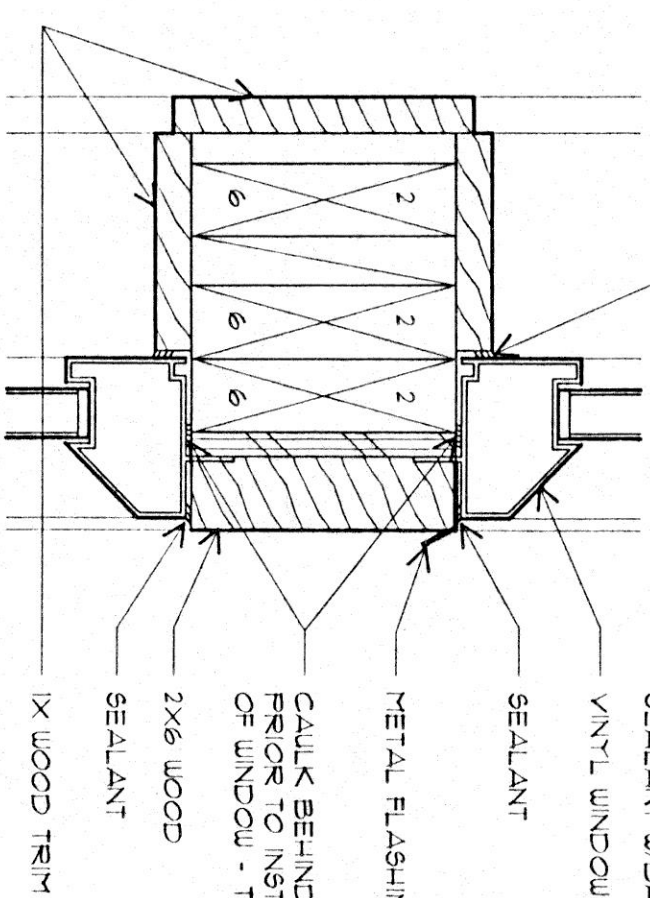


C1 HORIZONTAL WINDOW MULLION
R-EXWL 94084 A3
3'-1'-0"

C2 VERTICAL WINDOW MULLION
R-EXWL 94084 A3
3'-1'-0"

C3 DOOR THRESHOLD
R-EXWL 94084 A3
1'-1/2"=1'-0"

C4 WALL SILL AT PORCHES
R-EXWL 94084 A3
1'-1/2"=1'-0"

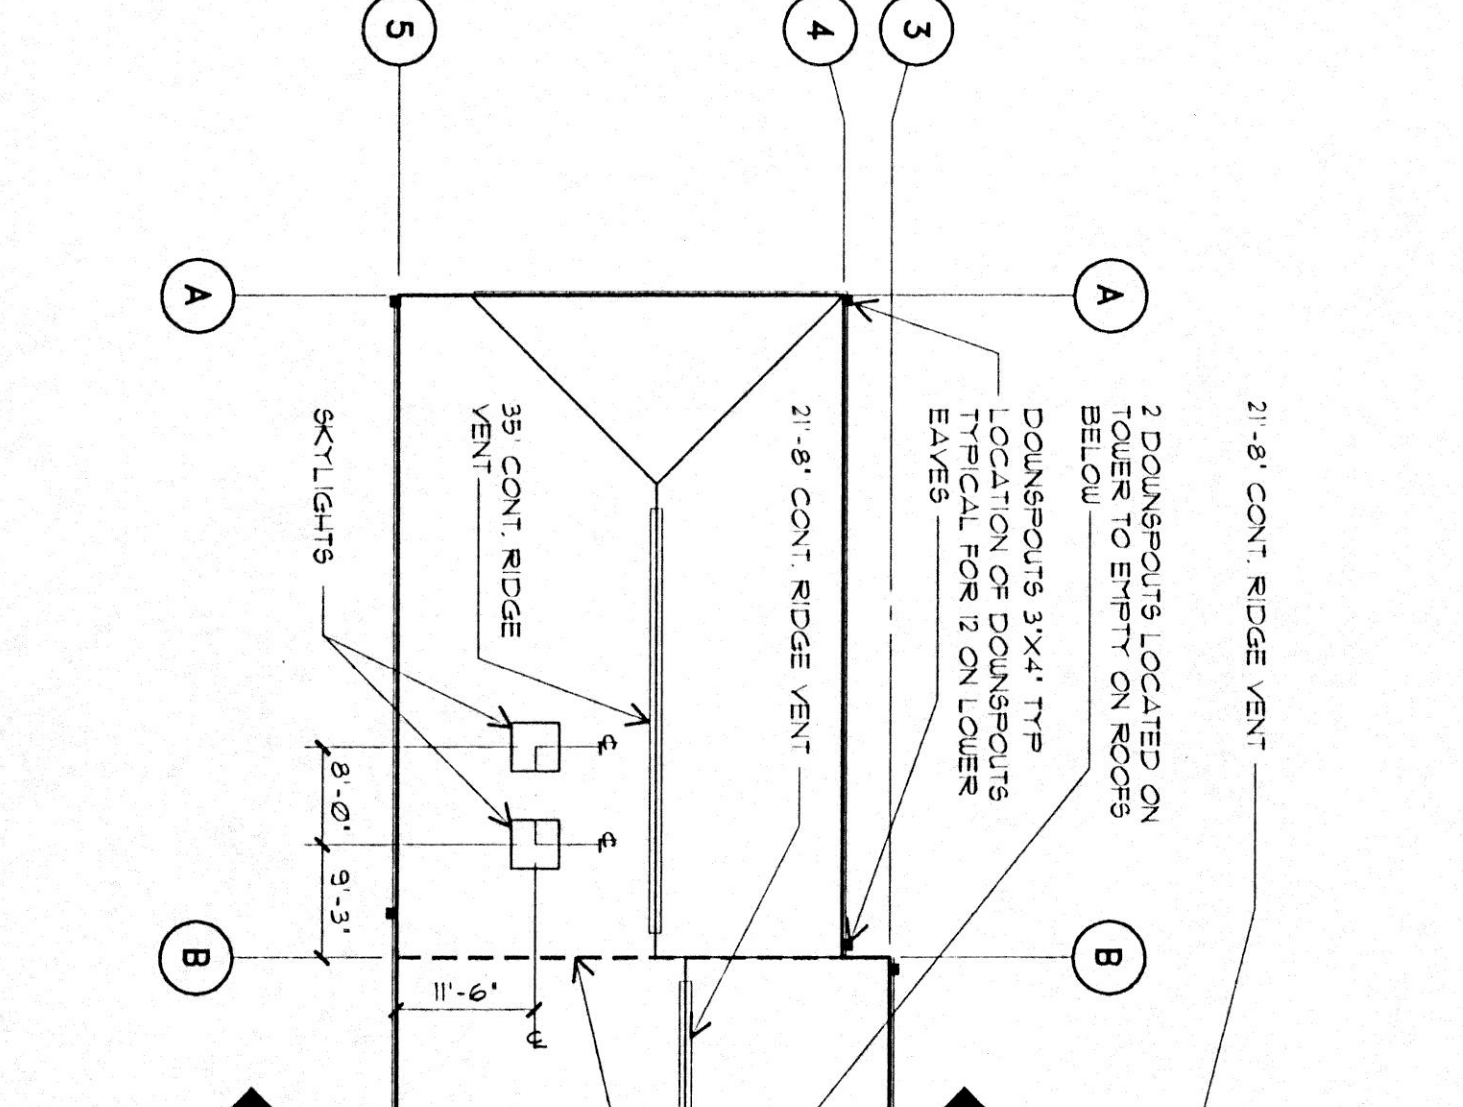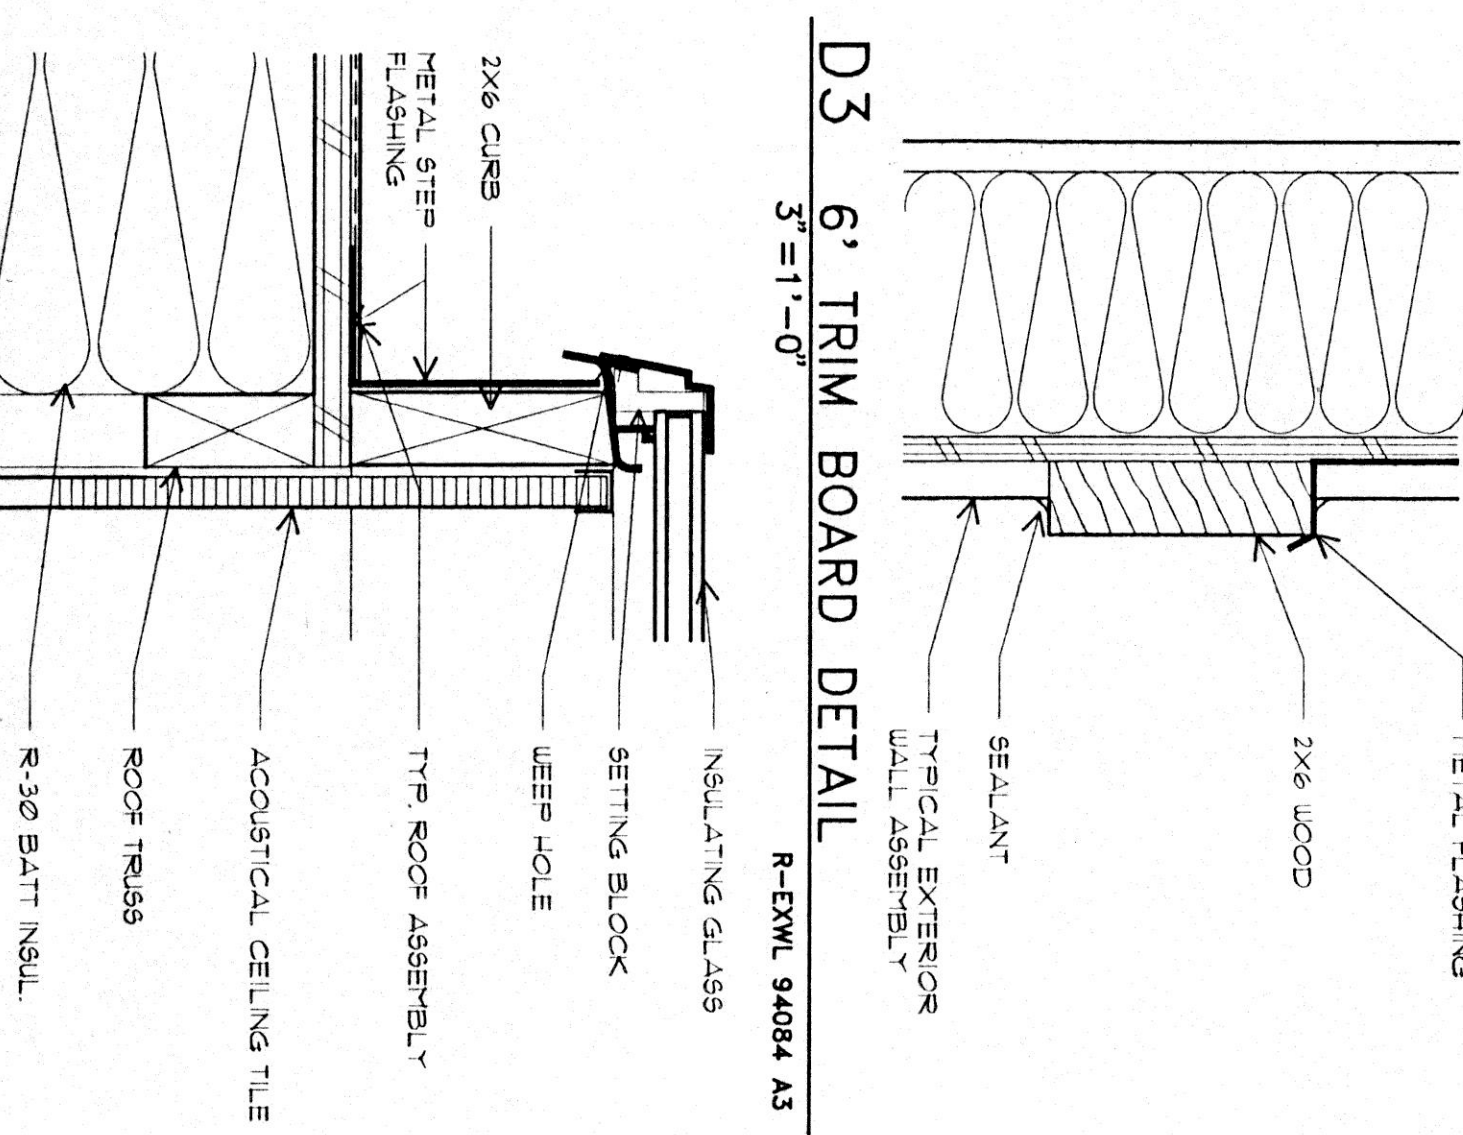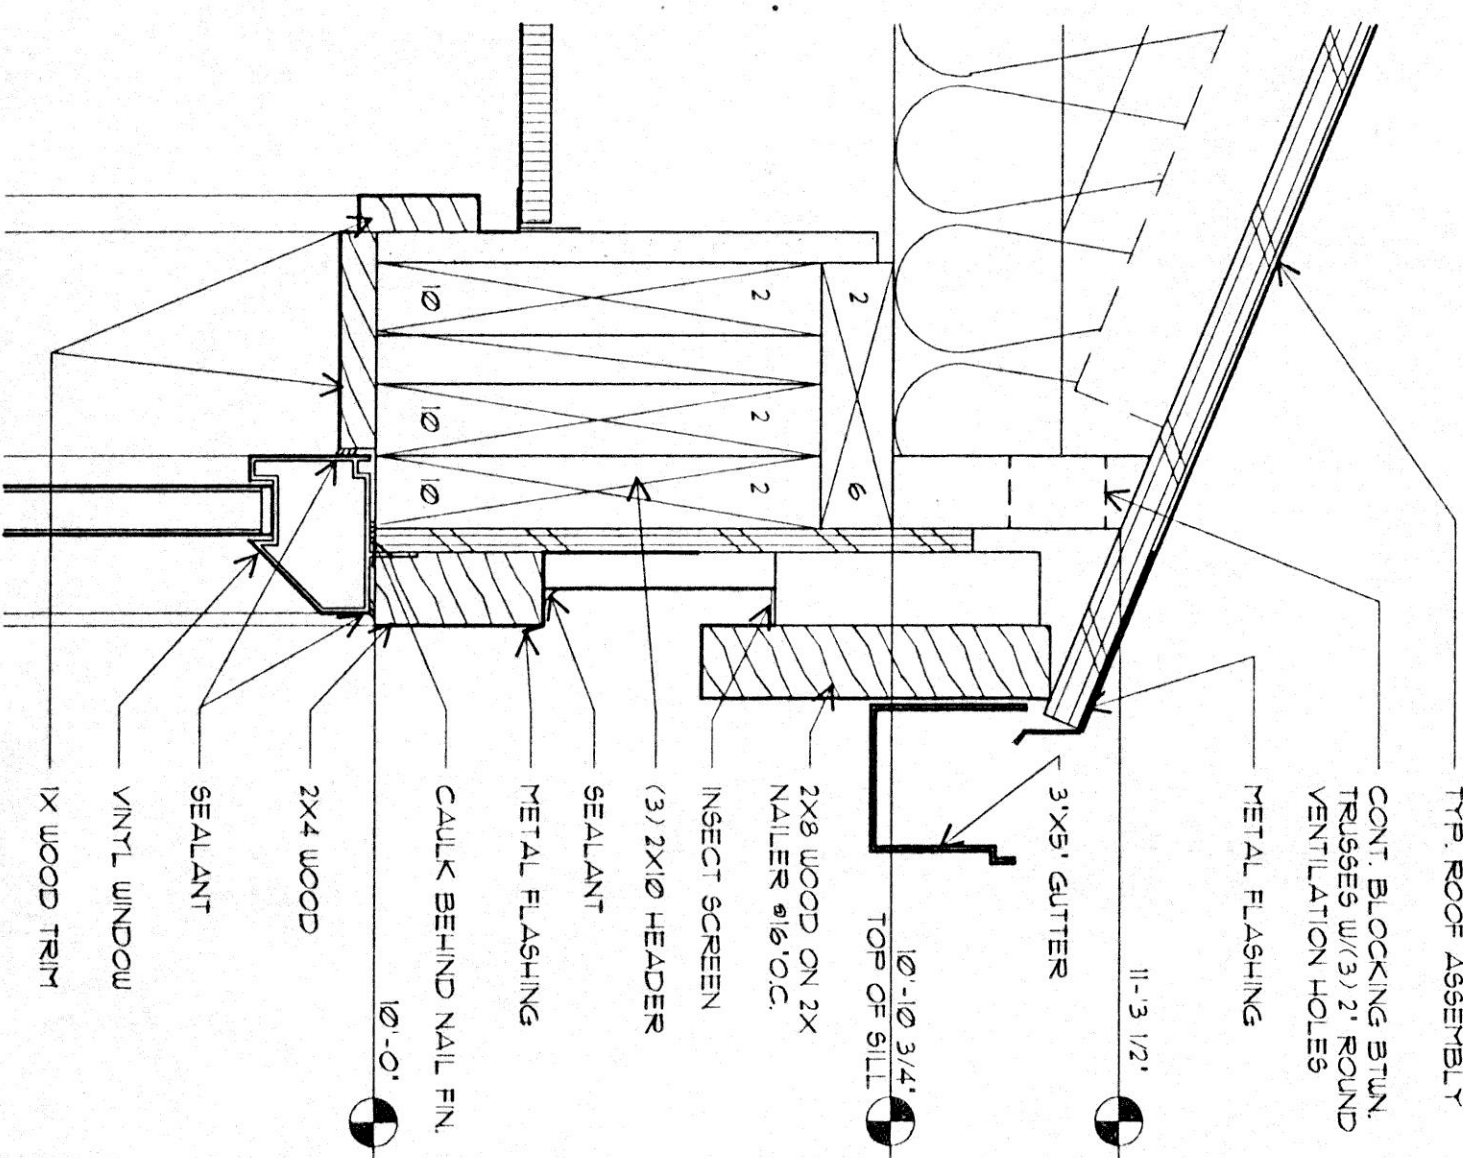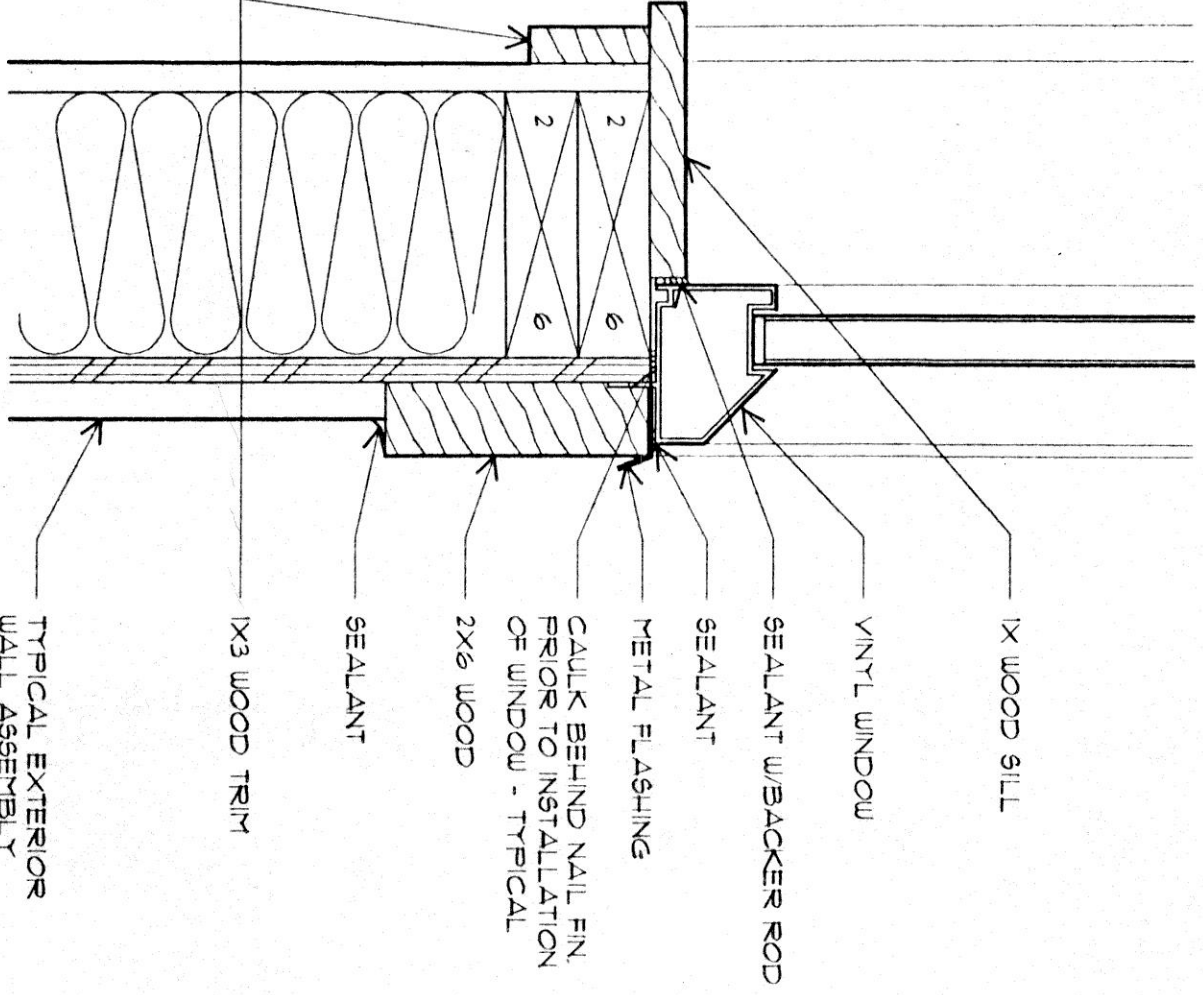

E1 WINDOW SILL
R-EXWL 94084 A3
3'-1'-0"

E2 WINDOW HEAD AND EAVE DETAIL
R-ROOF 94084 A3
3'-1'-0"

E3 SKYLIGHT DETAIL
R-ROOF 94084 A3
3'-1'-0"

E4 ROOF PLAN
R-ROOF 94084 A3
1/16"=1'-0"



MCM
ARCHITECTS

A PROFESSIONAL CORPORATION
1022 SOUTHWEST SALMON SUITE 350
PORTLAND, OREGON 97205-2447 USA
TELEPHONE 503 222 9757 FAX 503 241 1514


HEAD START
CENTER

WARRENTON/ASTORIA


PROJECT NO. 94084
FILE NO. A3.dwg
DATE: JUNE 15, 1995
BY: [Signature]
REVISIONS: [Table]
DESCRIPTION: [Table]

ROOF PLAN
& EXT. DETAILS


SHEET NO. A3

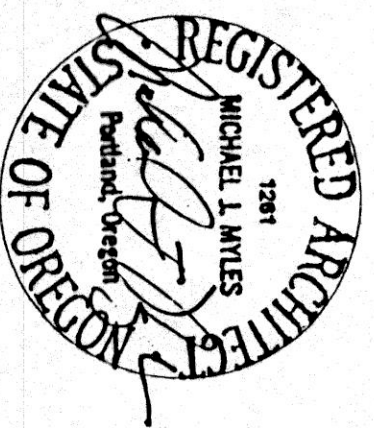


A1 NORTH ELEVATION
1/8" = 1'-0"

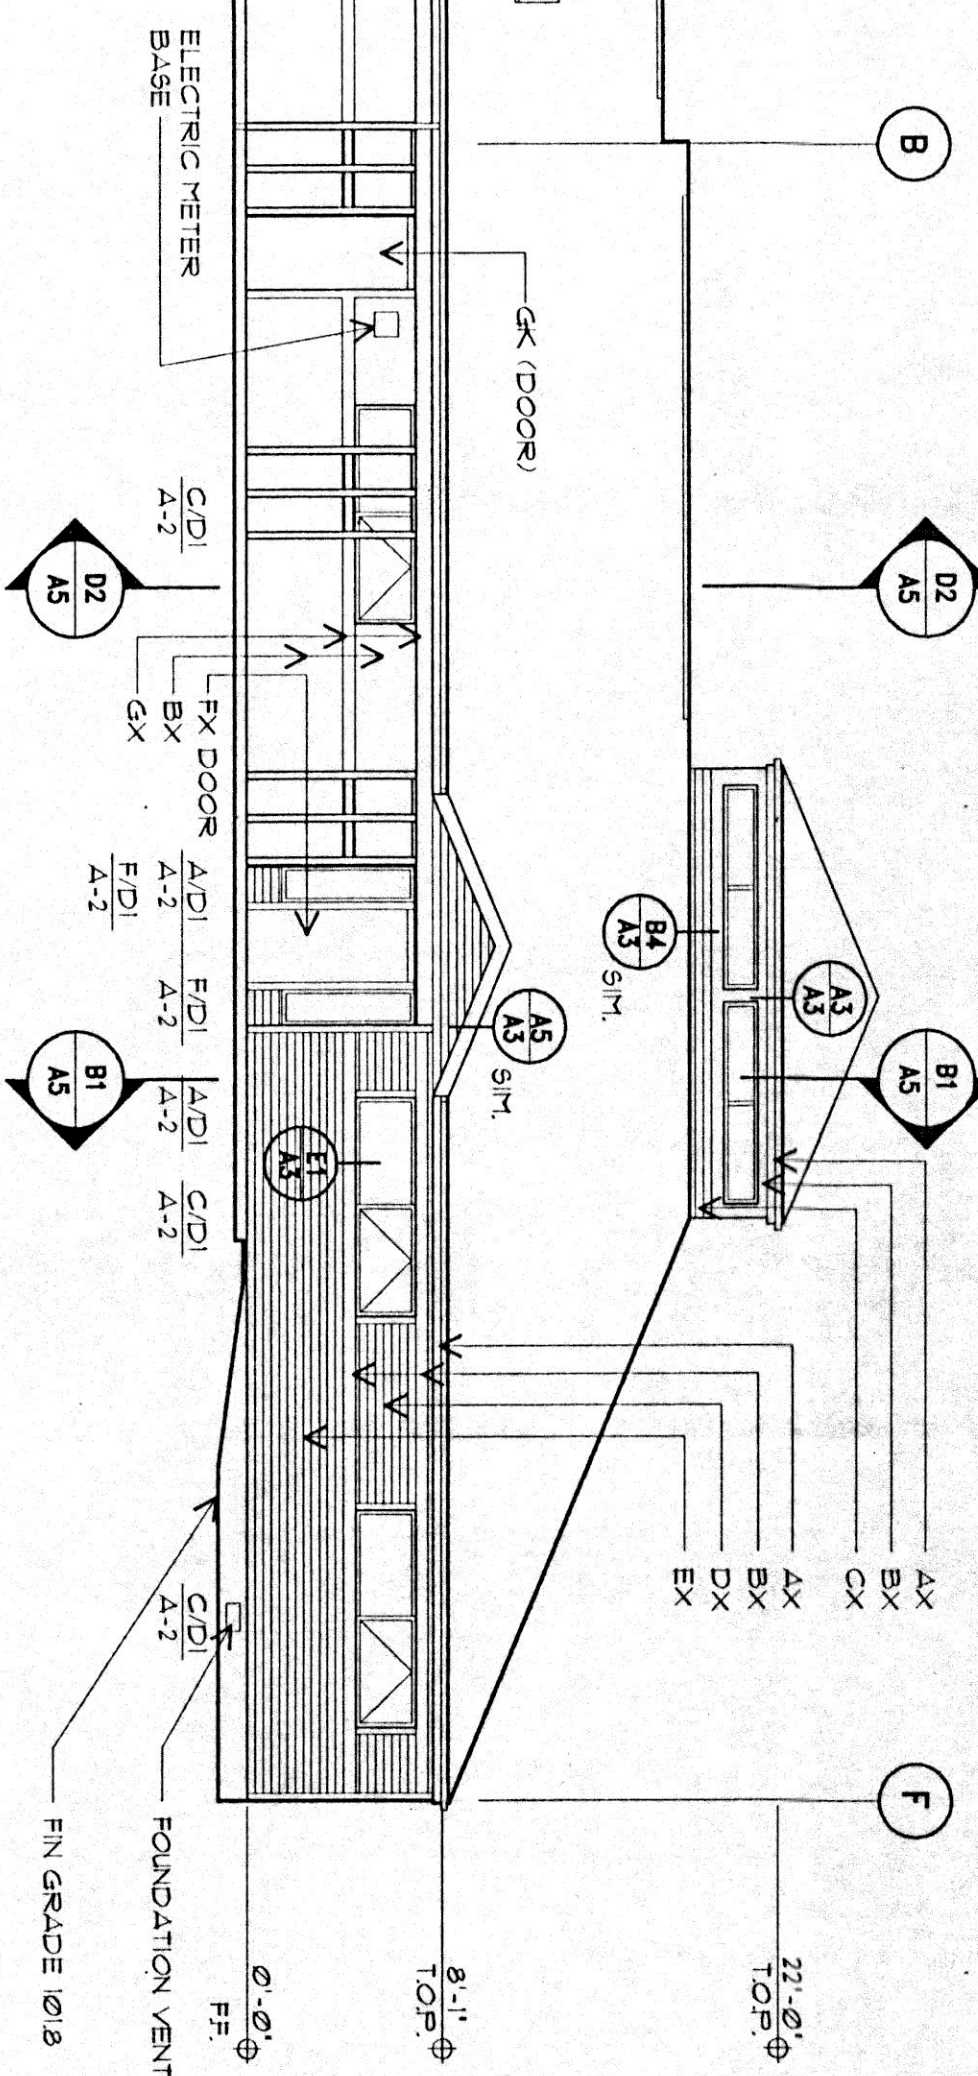


B1 WEST ELEVATION
1/8" = 1'-0"

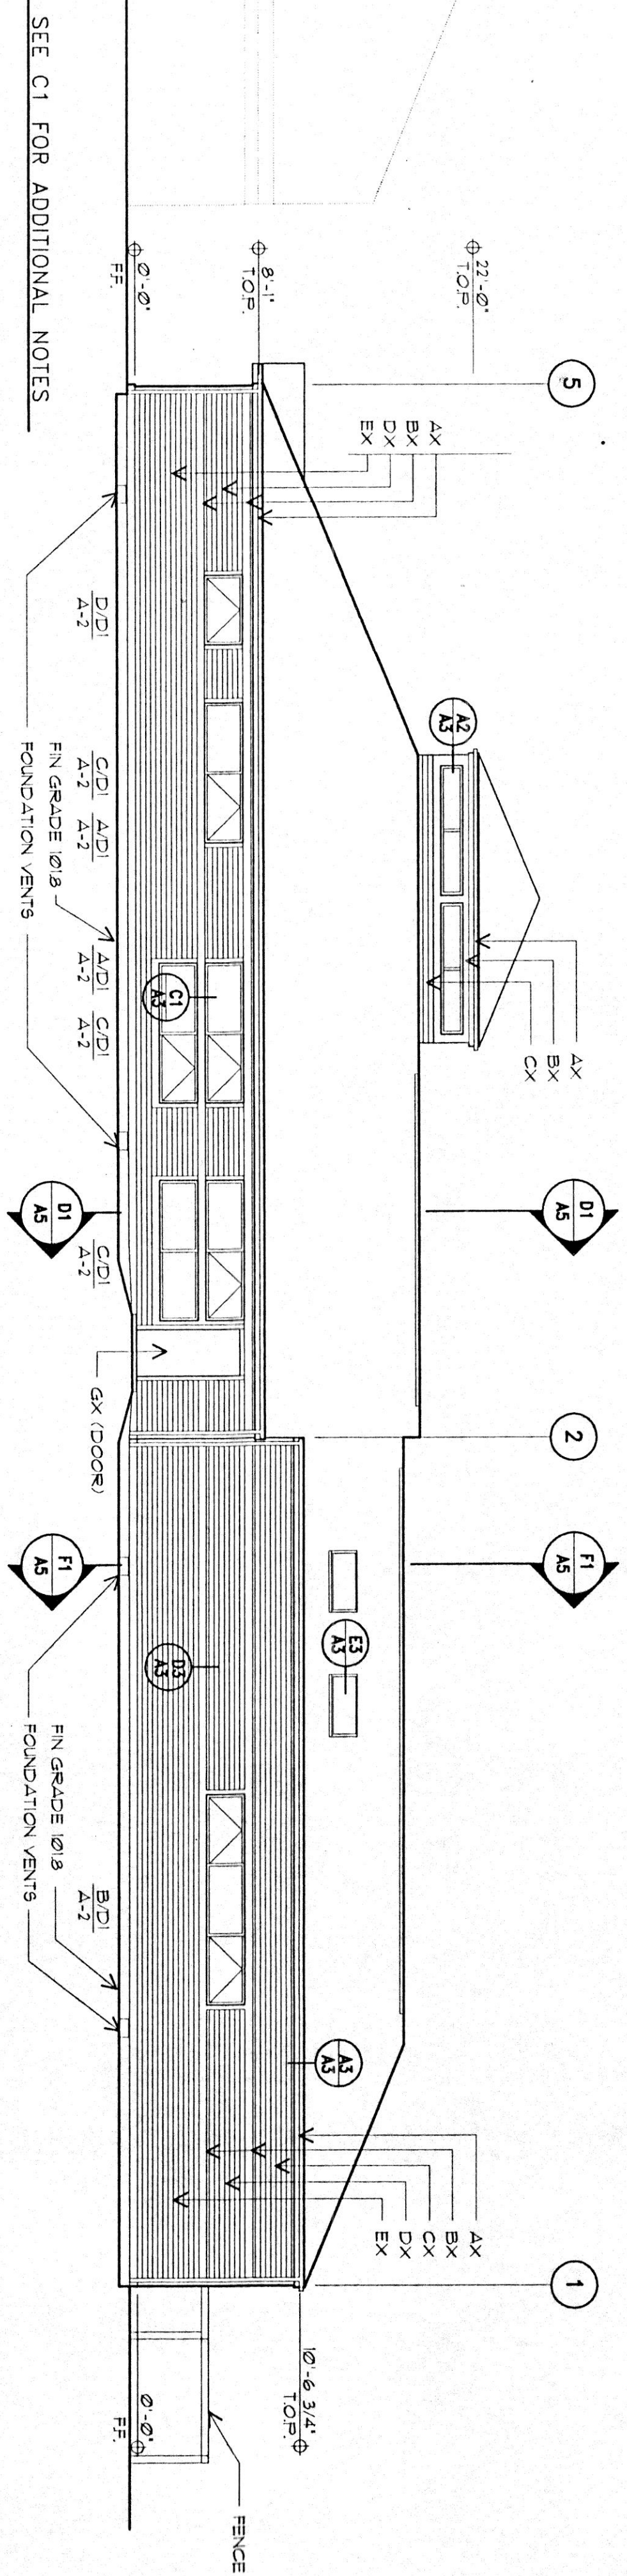

C1 SOUTH ELEVATION
1/8" = 1'-0"

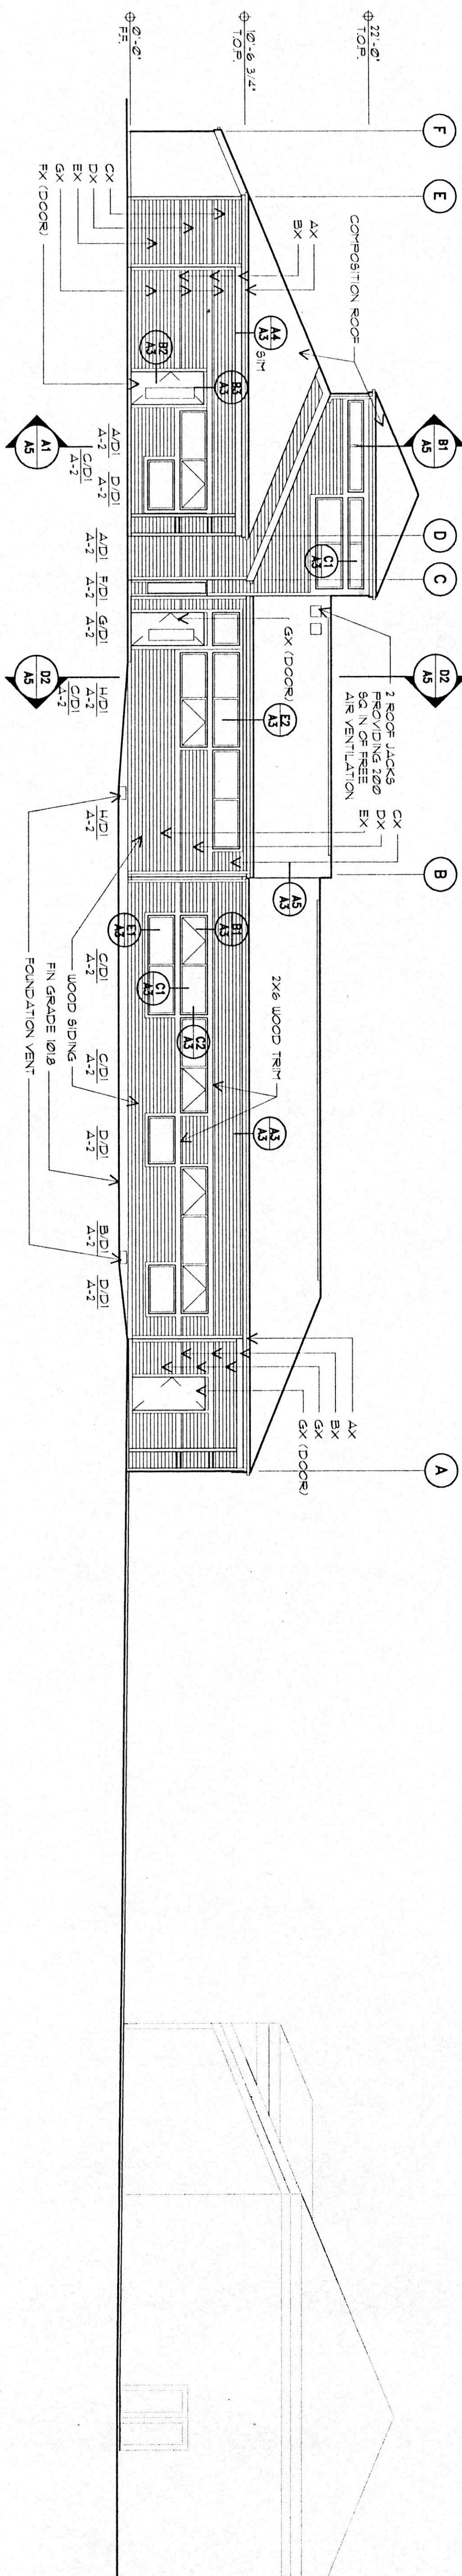

D1 EAST ELEVATION
1/8" = 1'-0"

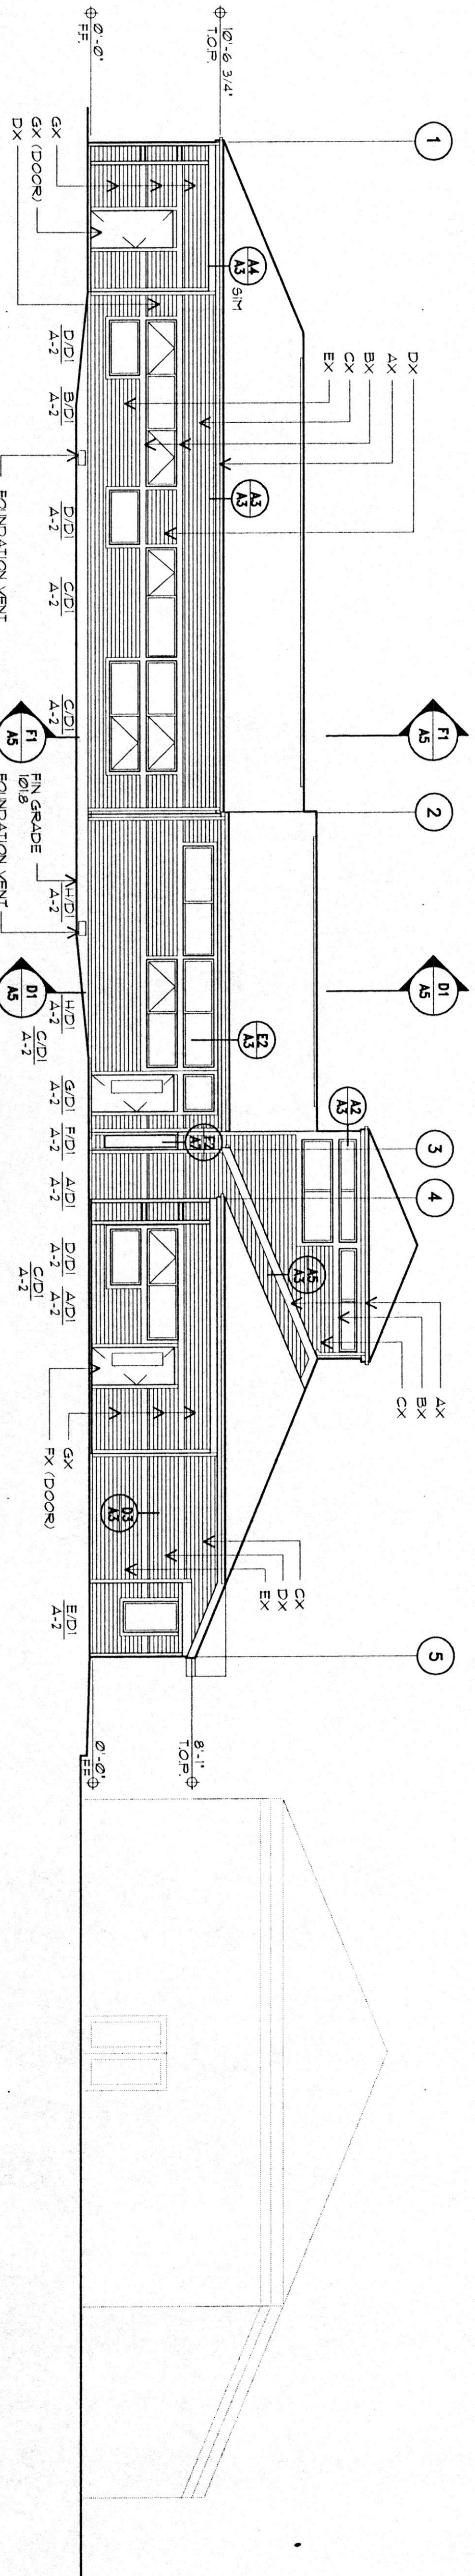

EXTERIOR COLORS
(SHERWIN WILLIAMS NUMBERS)
AX GOLDEN BLUFF 2331
BX IMPRESSIVE IVORY 2333
CX BAYSIDE 2387
DX SWAN LAKE 2388
EX LA JOLLA BLUE 1484
FX RED BARN 2307
GX RIVERA WATER 2386

NOTE: ALL TRIM & DOWNSPOUTS
TO BE (EX)

MCM
ARCHITECTS
A PROFESSIONAL CORPORATION
1022 SOUTHWEST SALMON SUITE 350
PORTLAND, OREGON 97205-2447 USA
TELEPHONE 503 222 5757 FAX 503 241 1514

PROJECT
**HEAD START
CENTER**

WARRENTON/ASTORIA


PROJECT NO. 84084
FILE NO. A4.dwg
DATE: JUNE 15, 1995
REVISIONS: [] DATE: [] DESCRIPTION: []

SHEET TITLE
**EXTERIOR
ELEVATIONS**


SHEET NO. **A4**




F1 SECTION
1/4" = 1'-0"

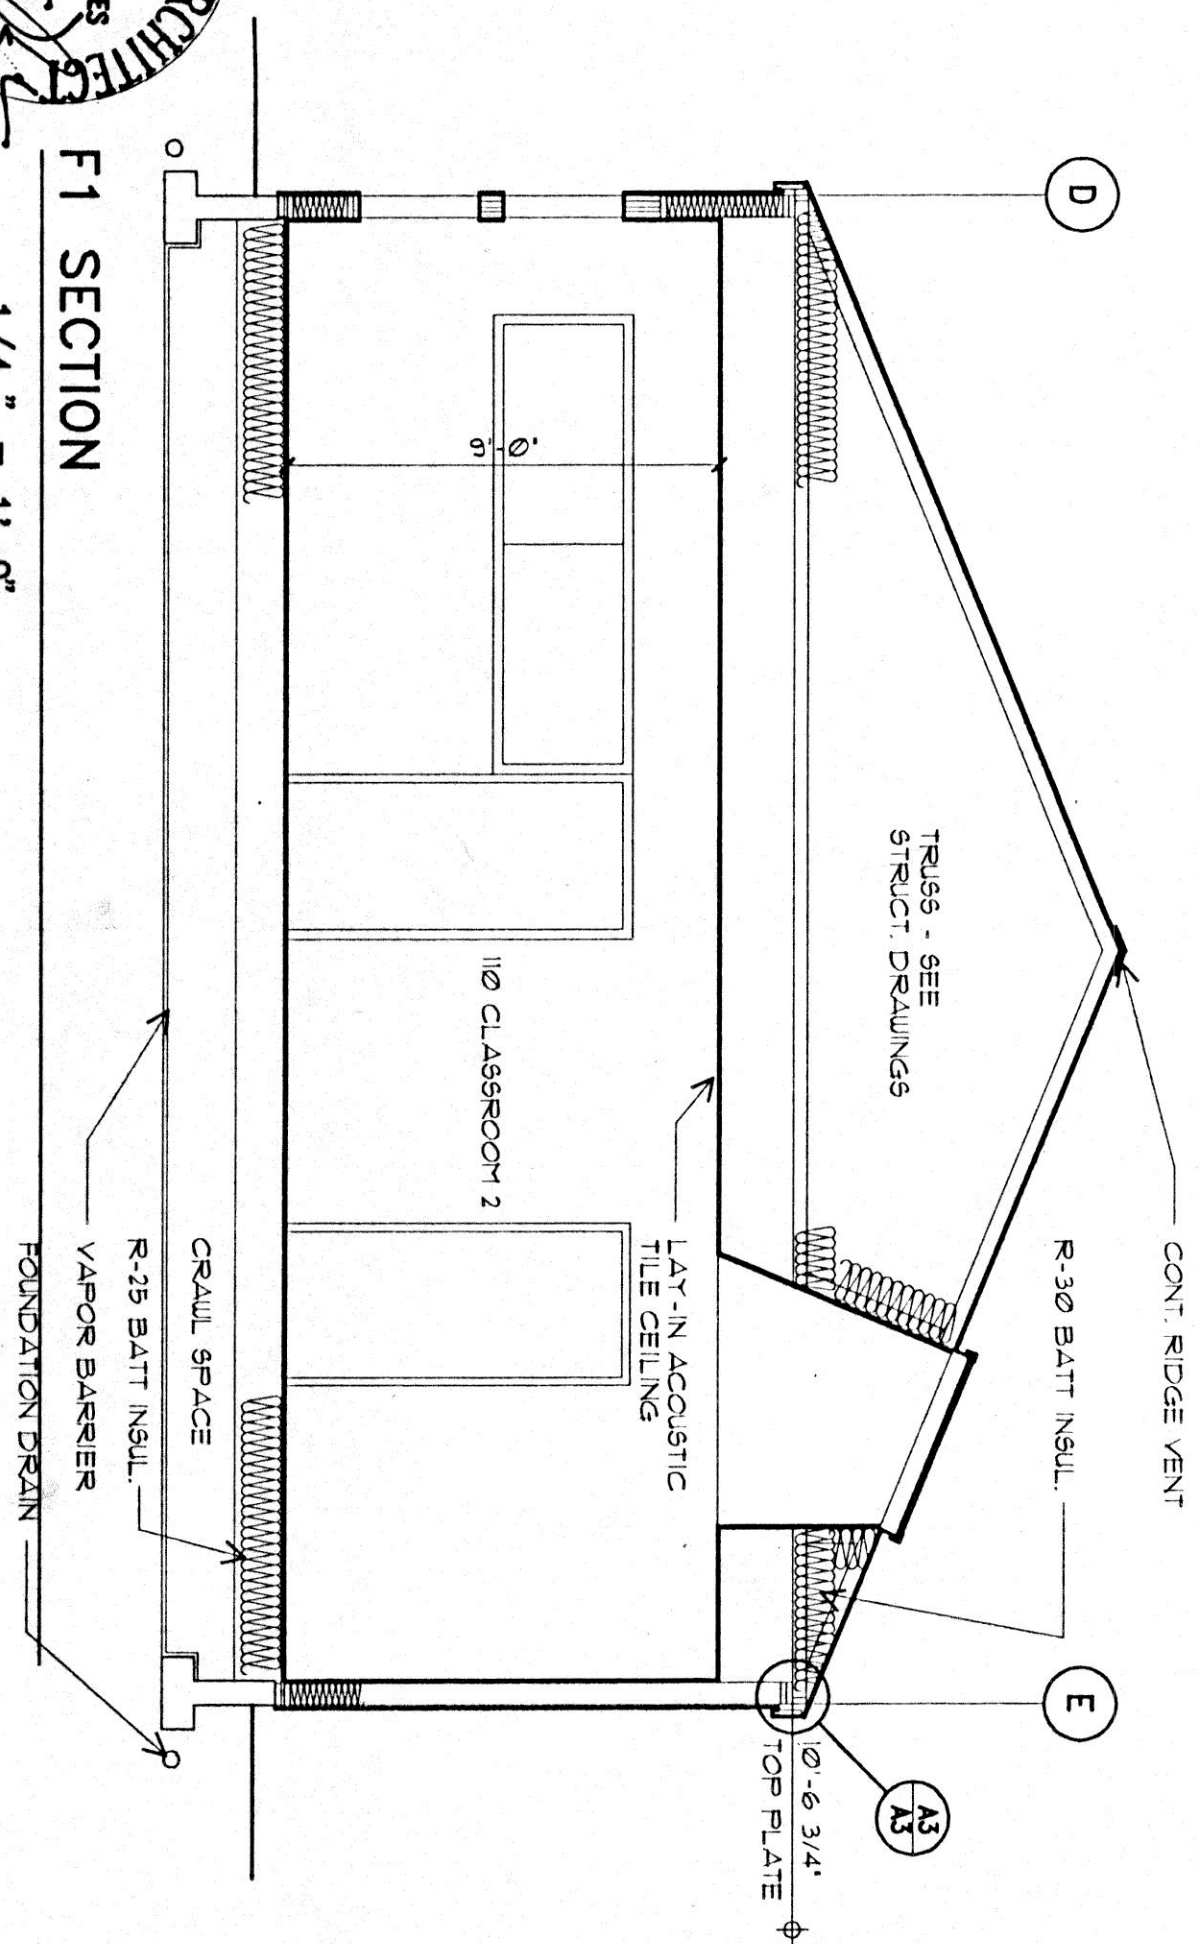


D1 SECTION
1/4" = 1'-0"

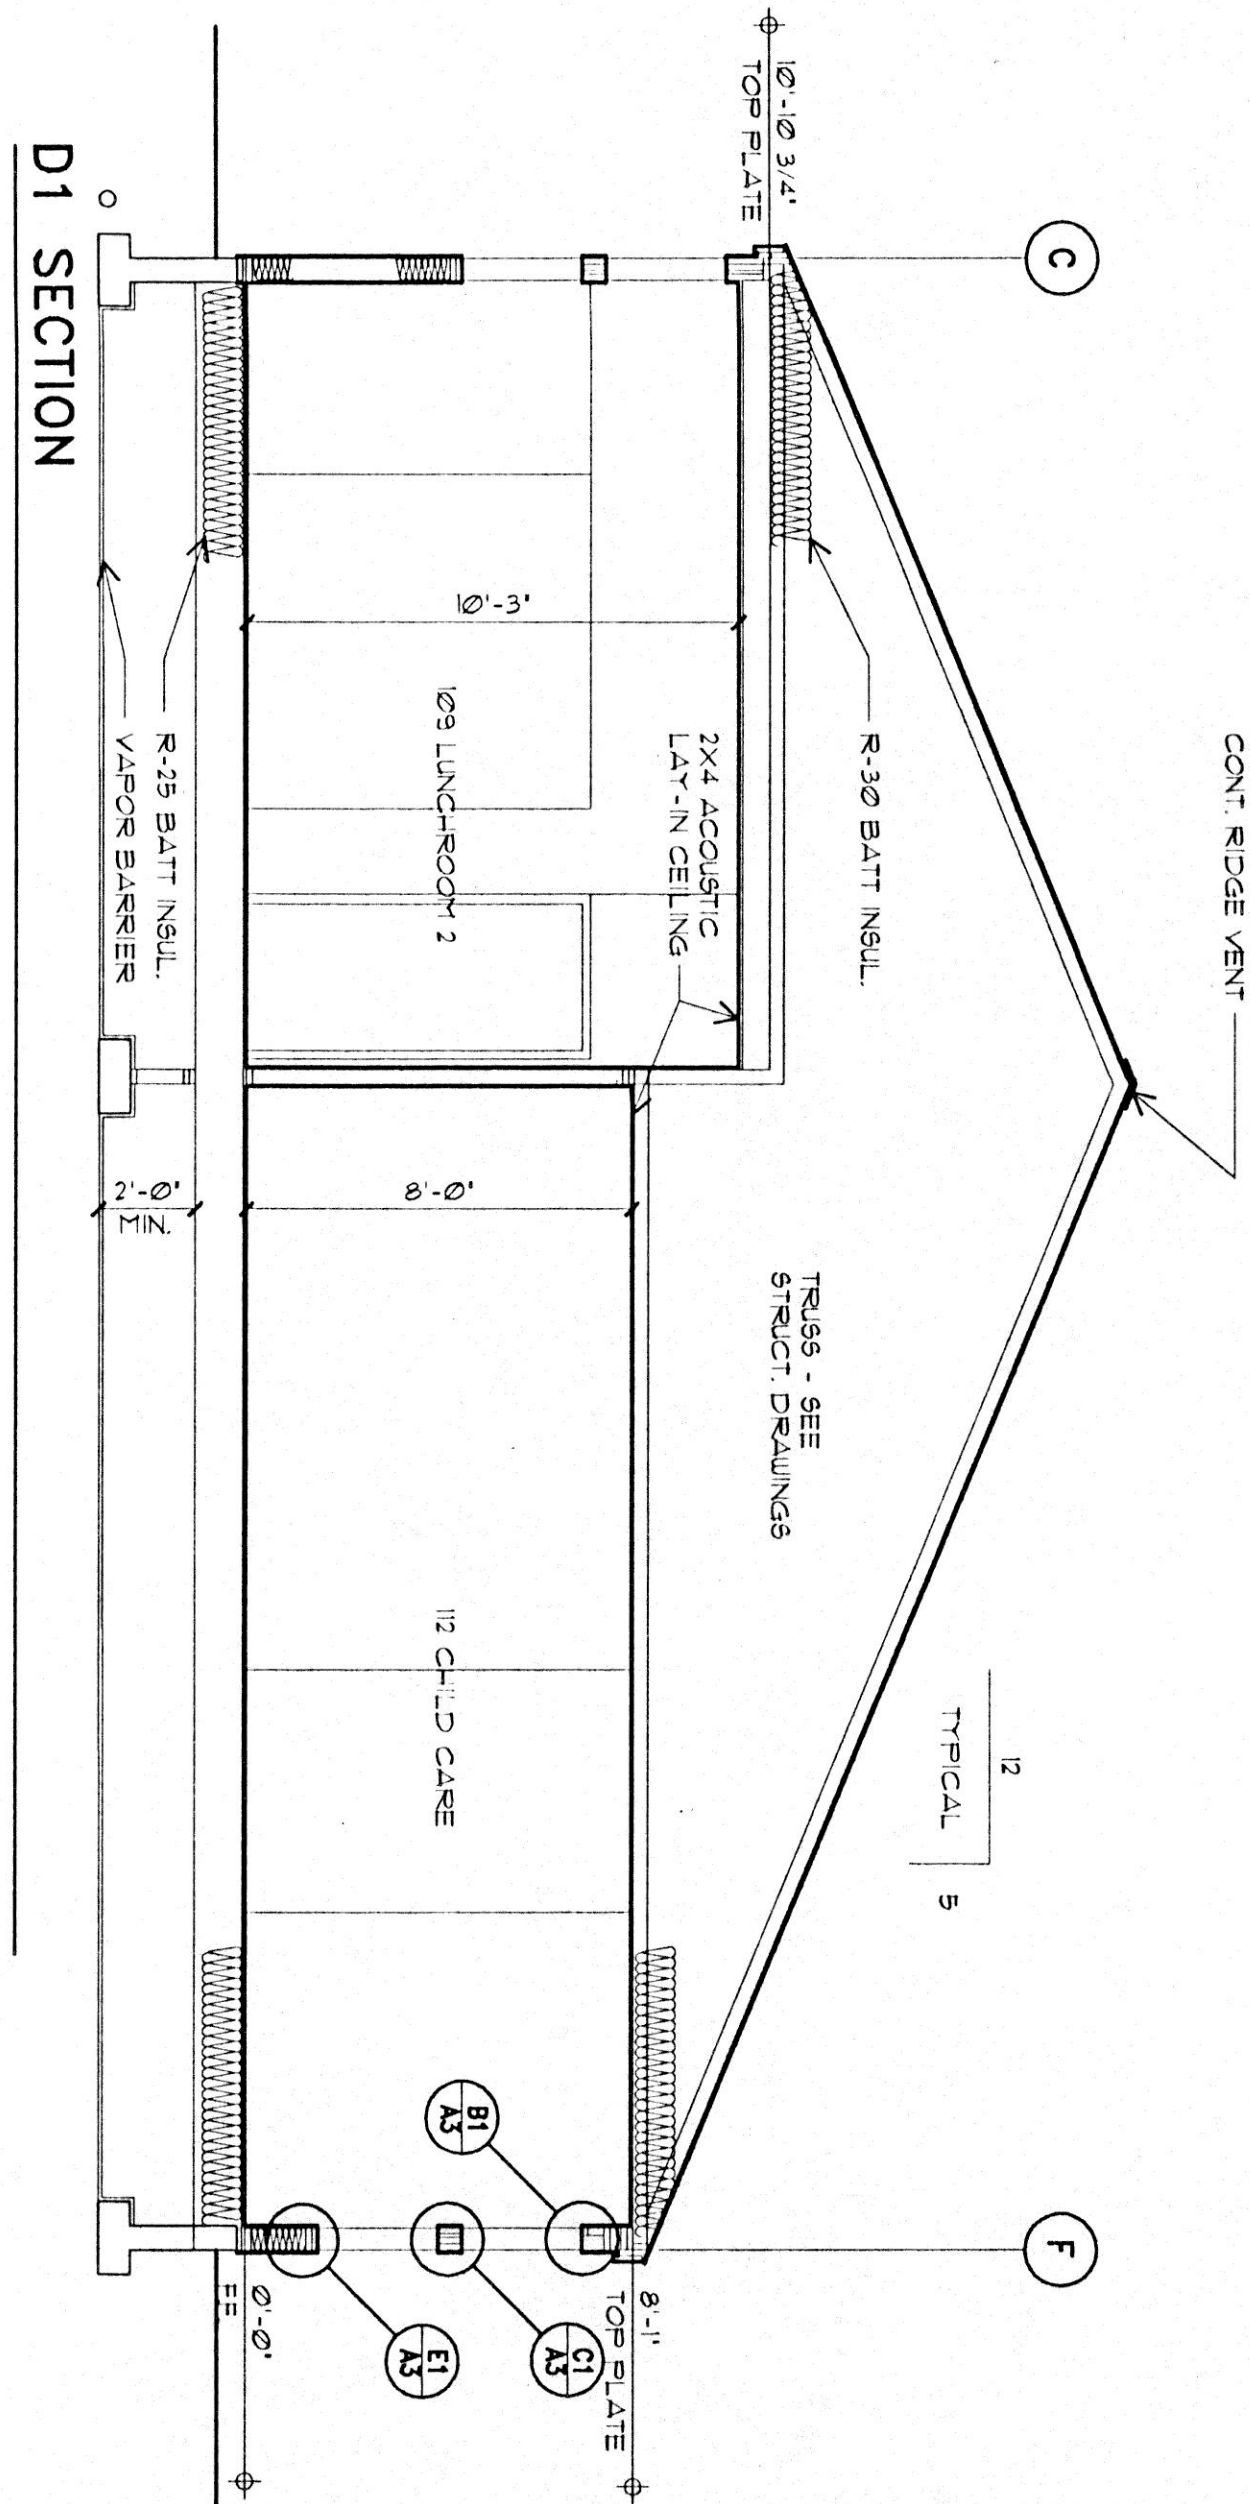


D2 SECTION
1/4" = 1'-0"


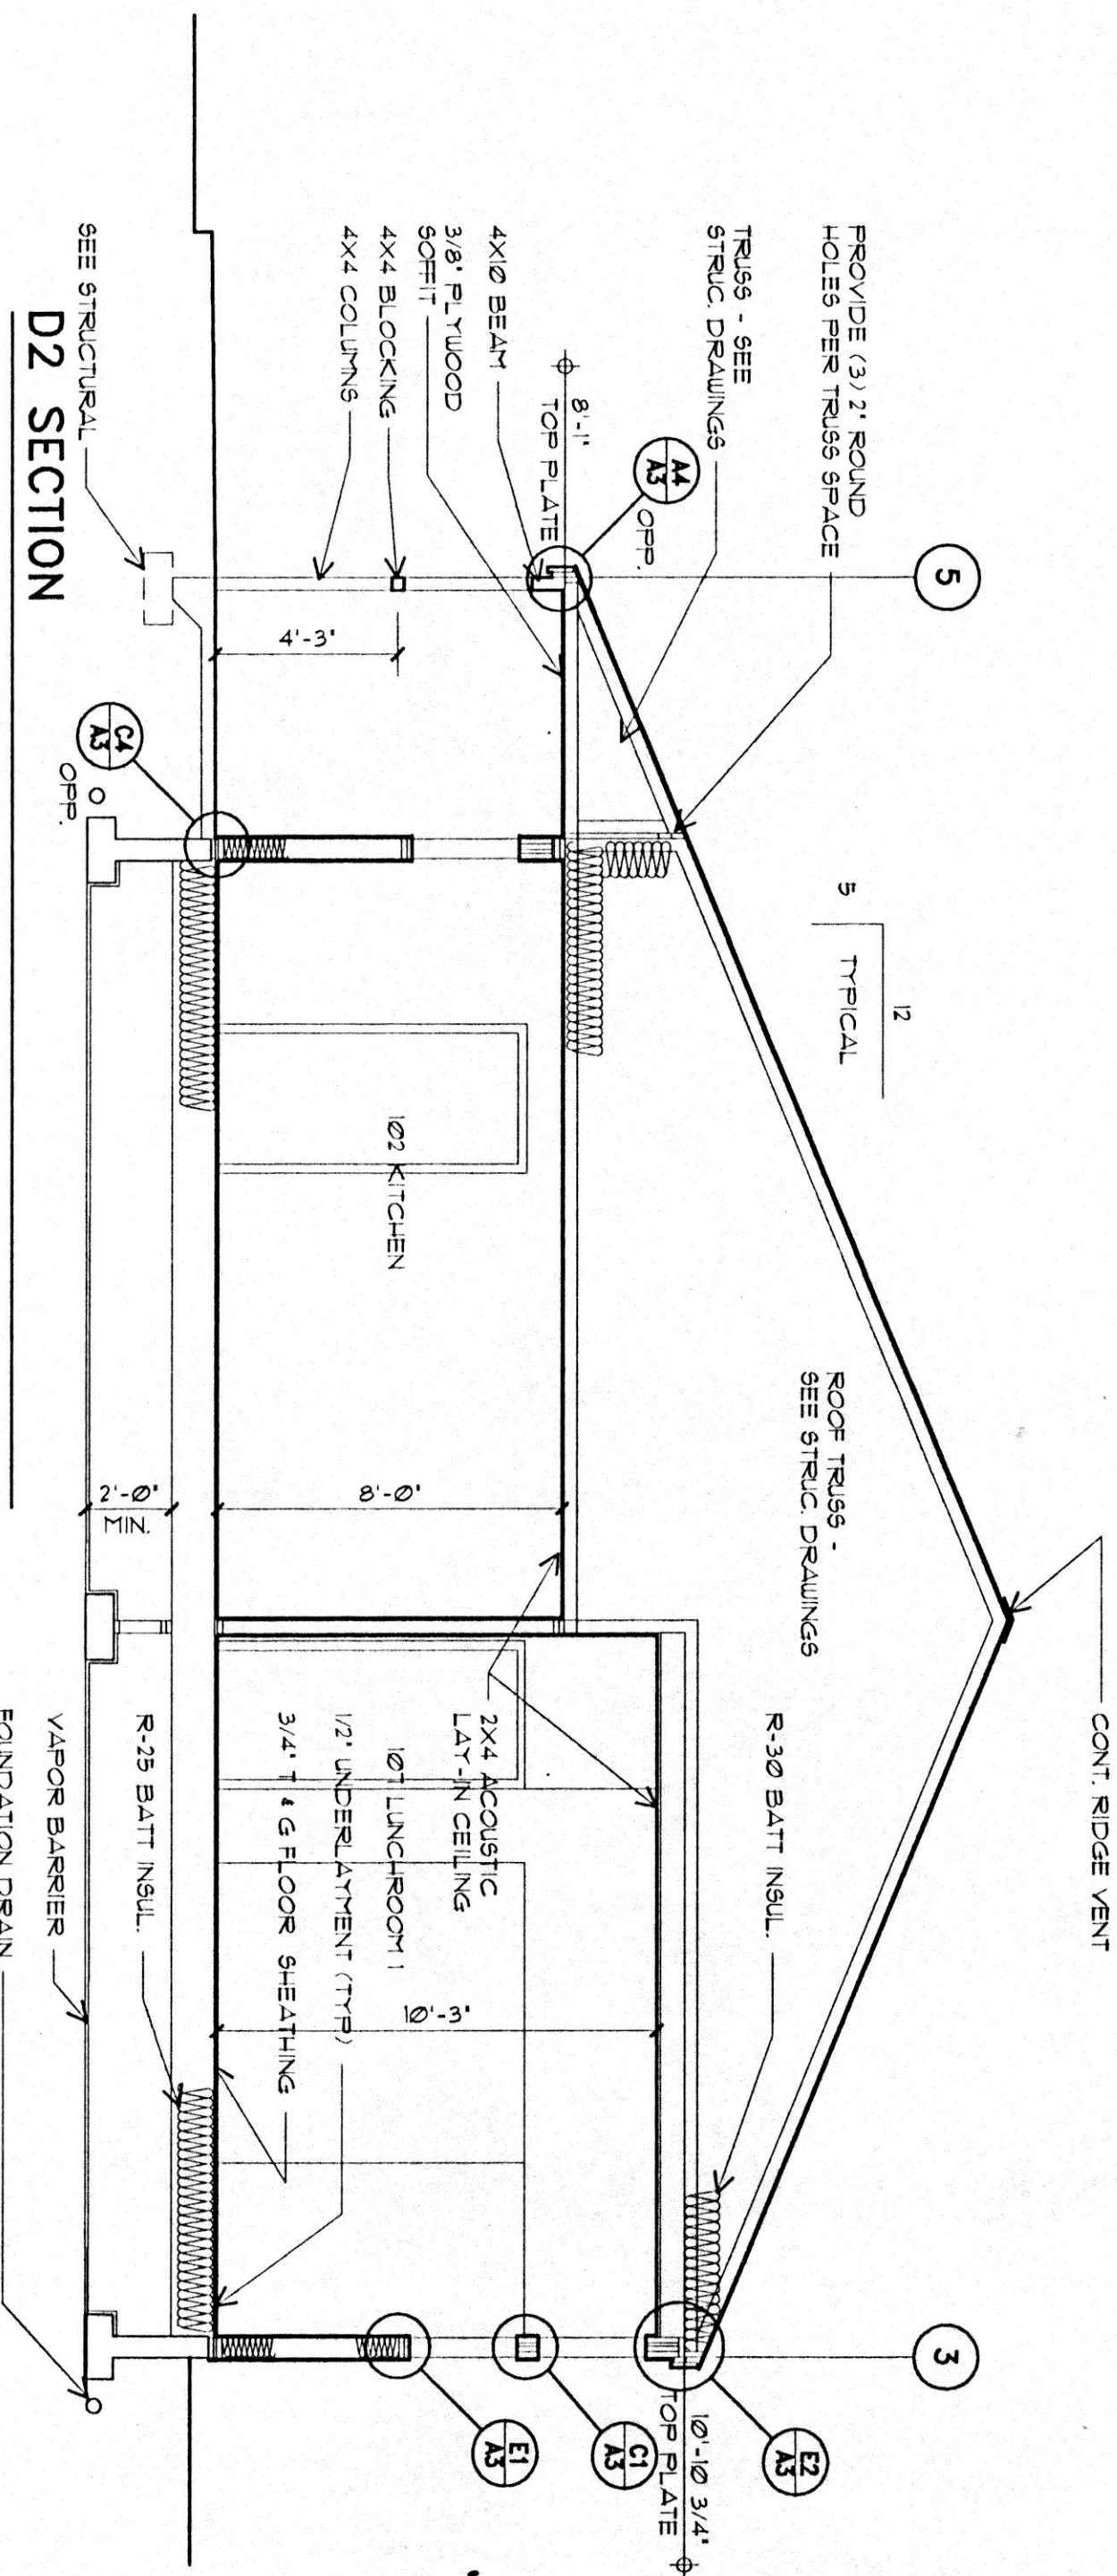


B1 SECTION
1/4" = 1'-0"

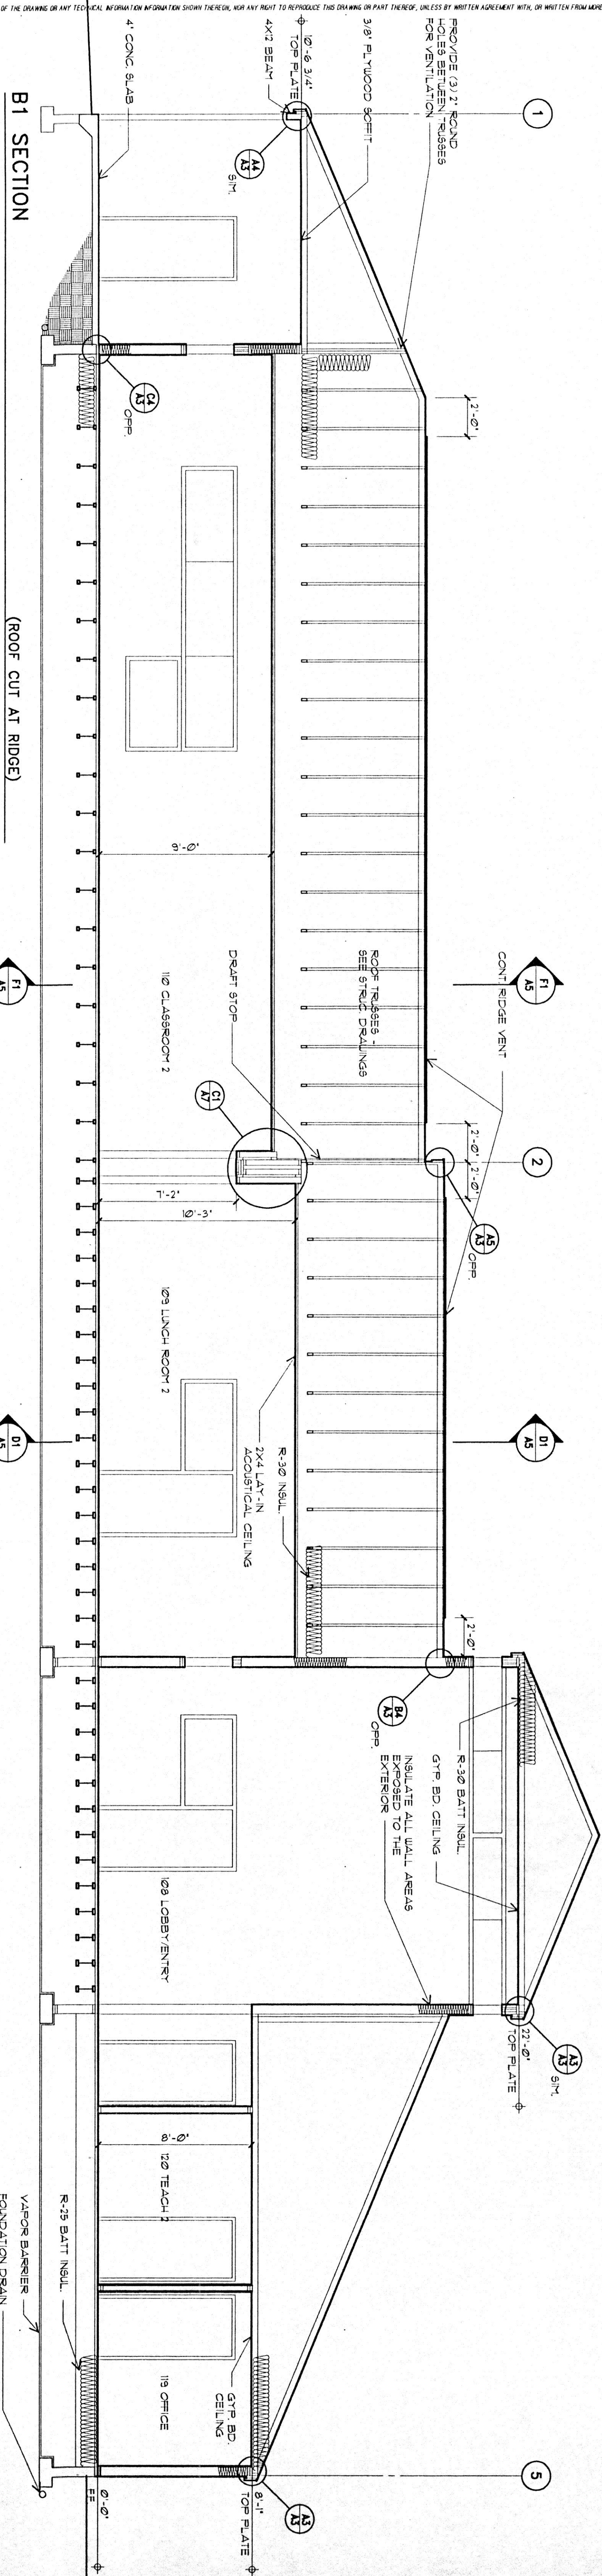


F2 HEADER @ LOBBY WINDOW
1 1/2" = 1'-0"

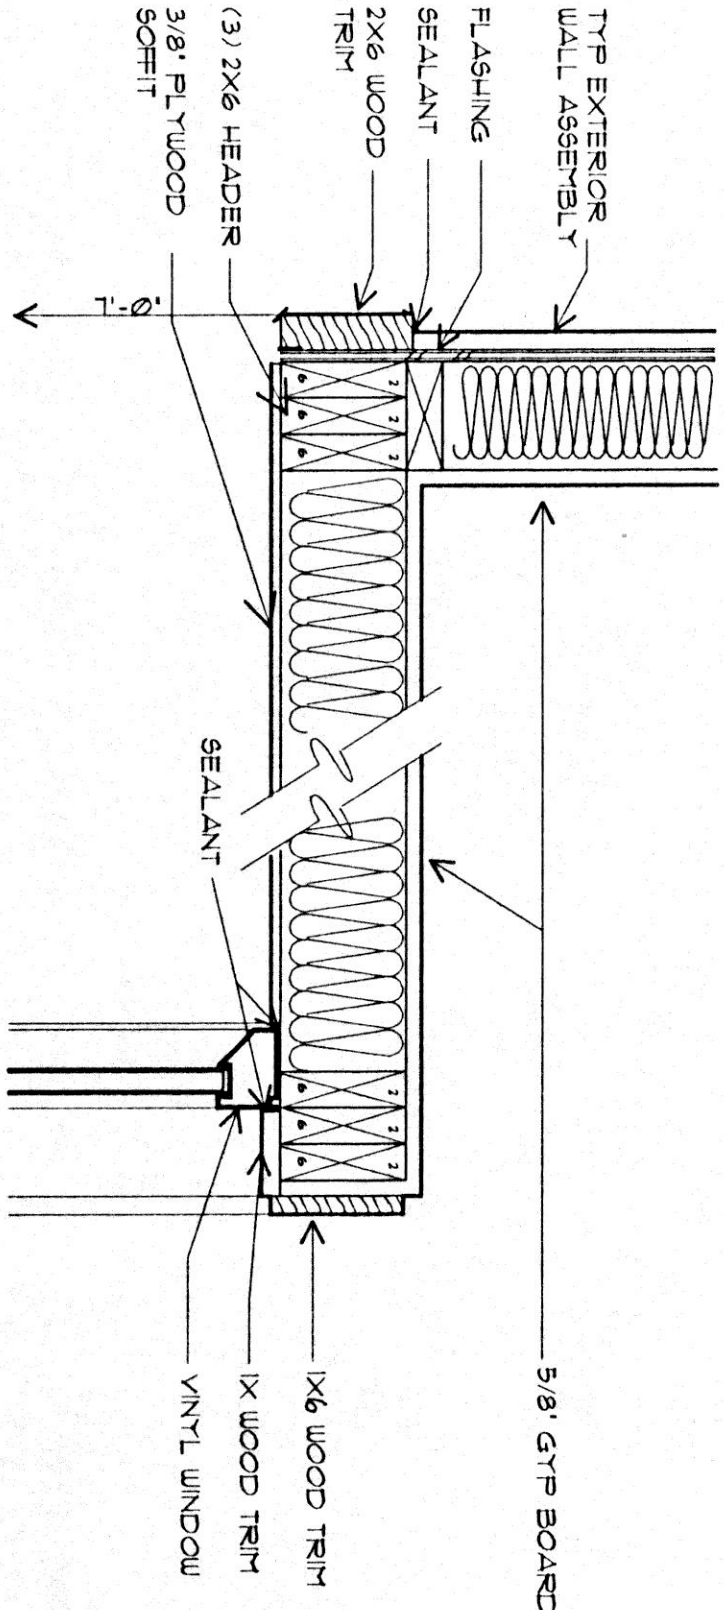


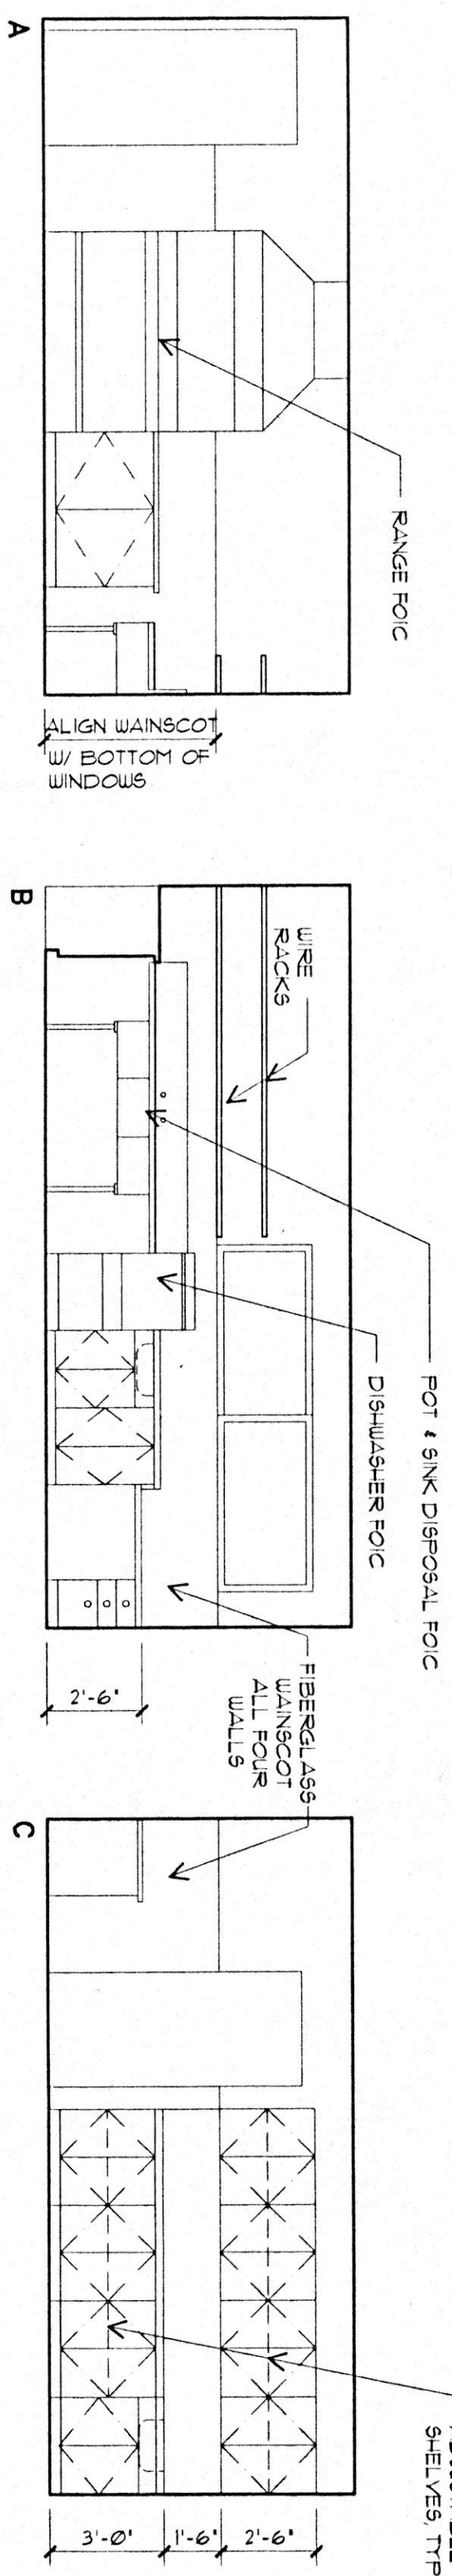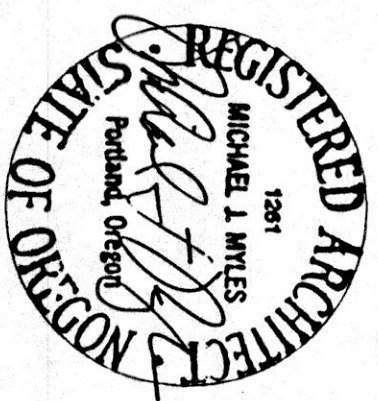


A1 102 KITCHEN
1/4"=1'-0"

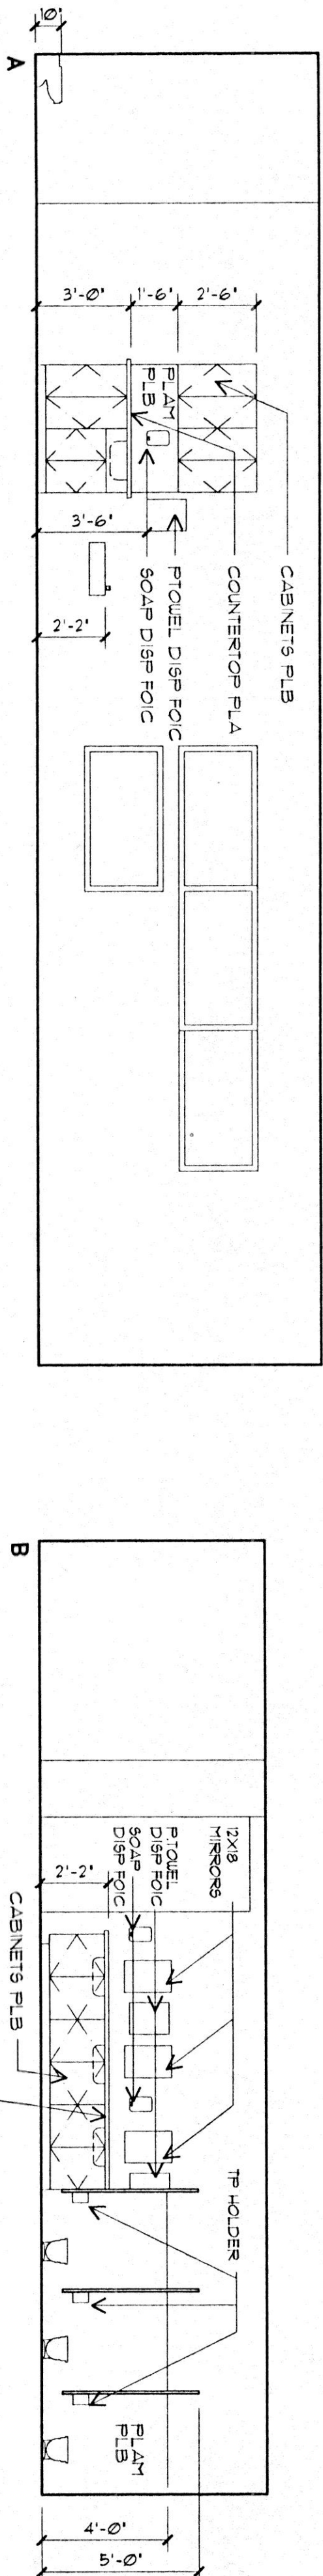


B1 105 CLASSROOM
1/4"=1'-0"

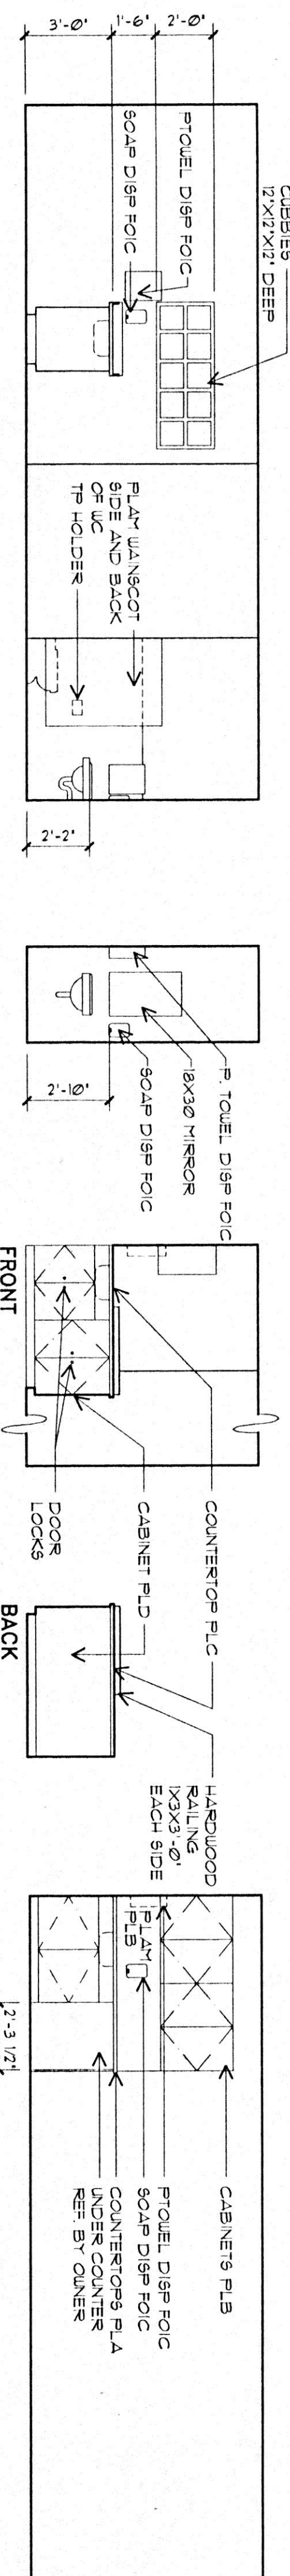

C1 112 CHILD CARE
1/4"=1'-0"

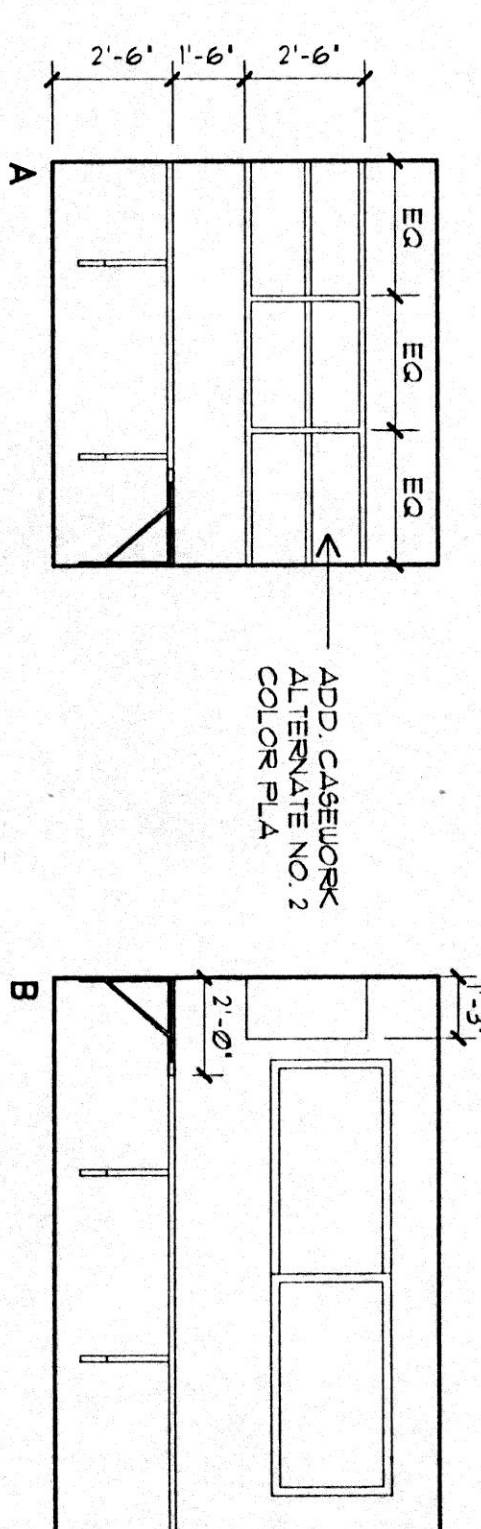


C4 115 THERAPY
1/4"=1'-0"

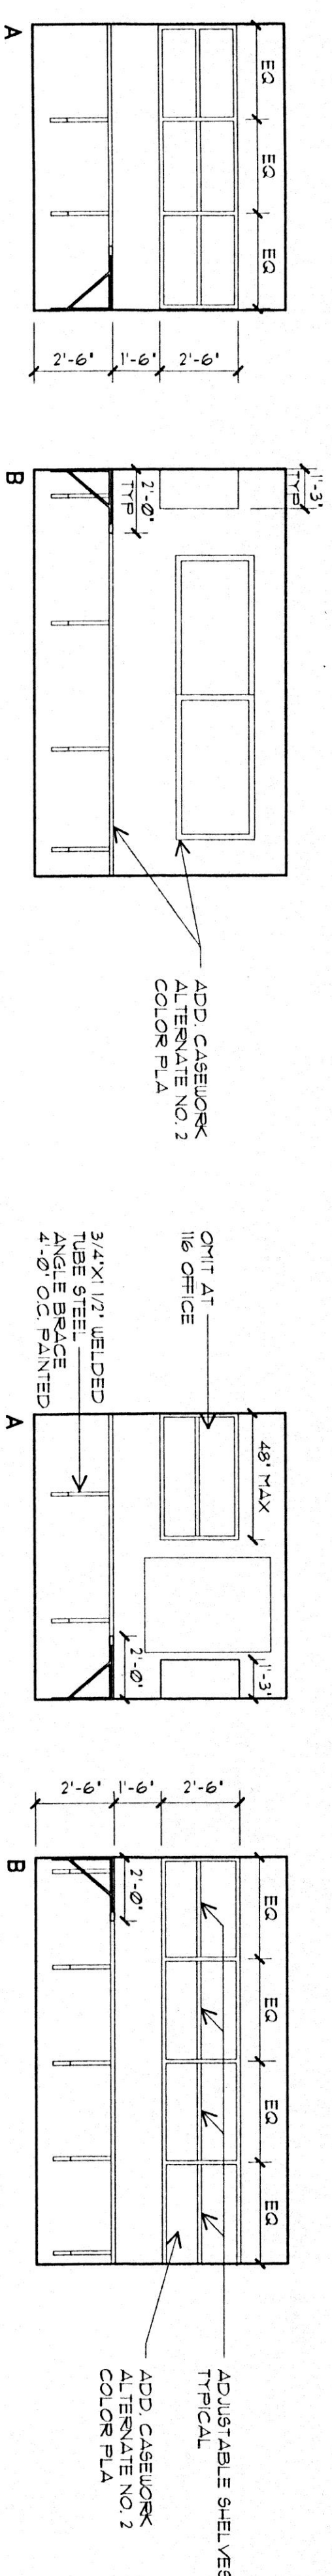


D1 117 TEACHER
1/4"=1'-0"


D2 120 TEACHER - 116 OFFICE (SIMILAR)
1/4" = 1'-0"

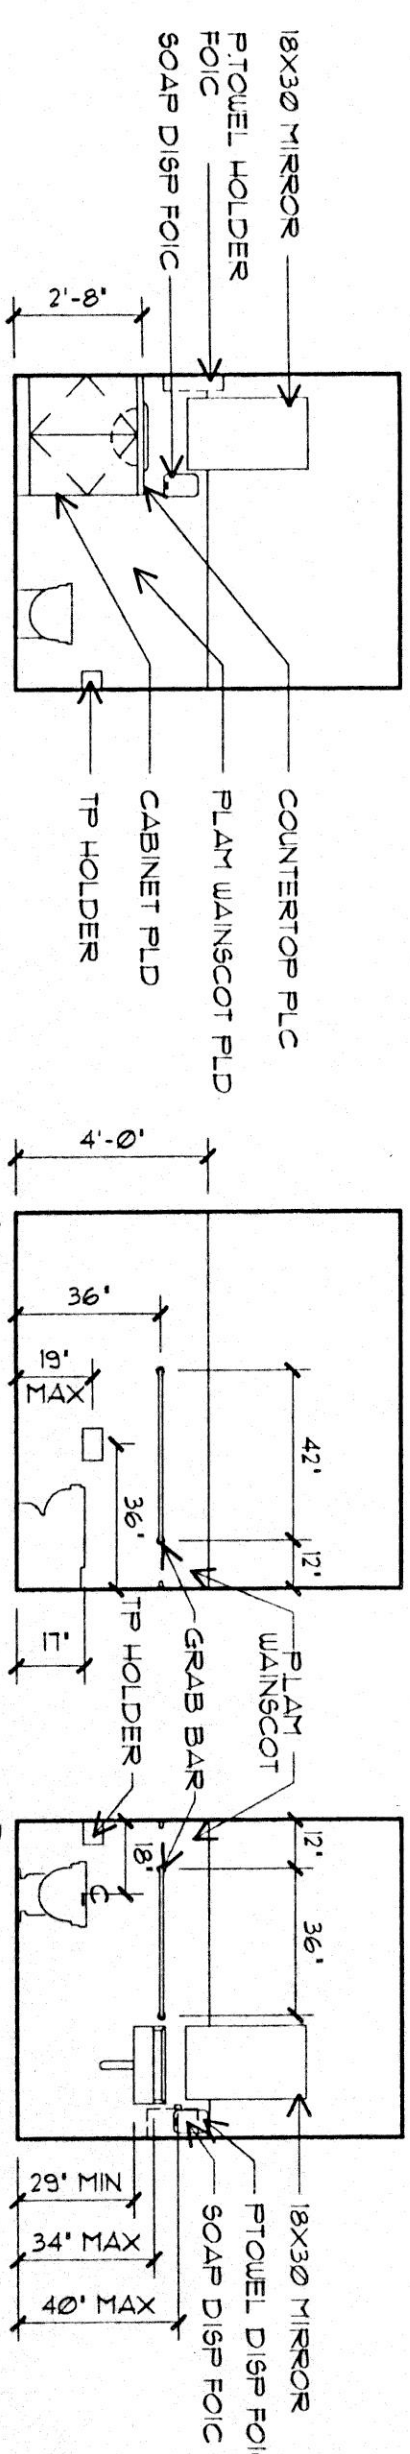

E1 121 MC
1/4"=1'-0"

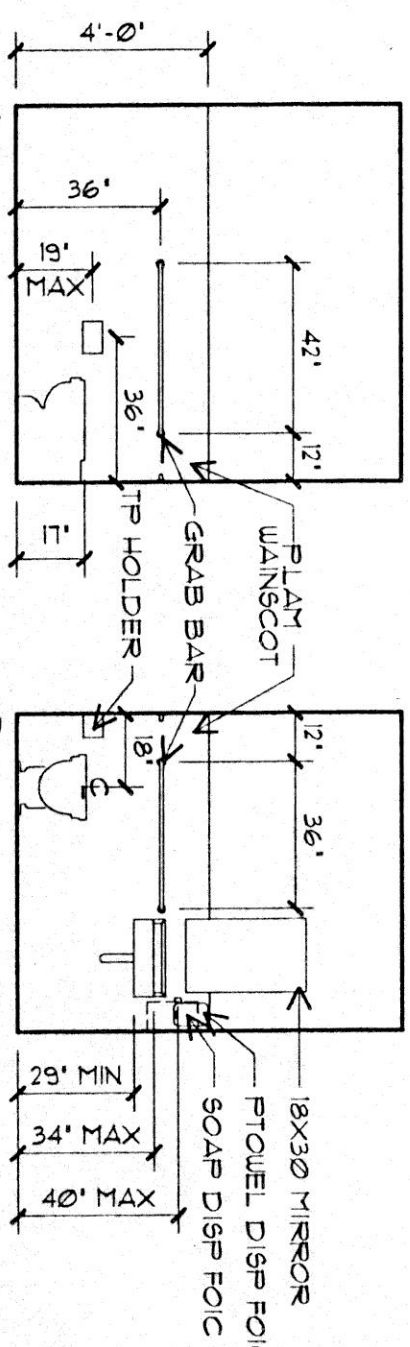


E2	122 HC WC
	1/4"=1'-0"

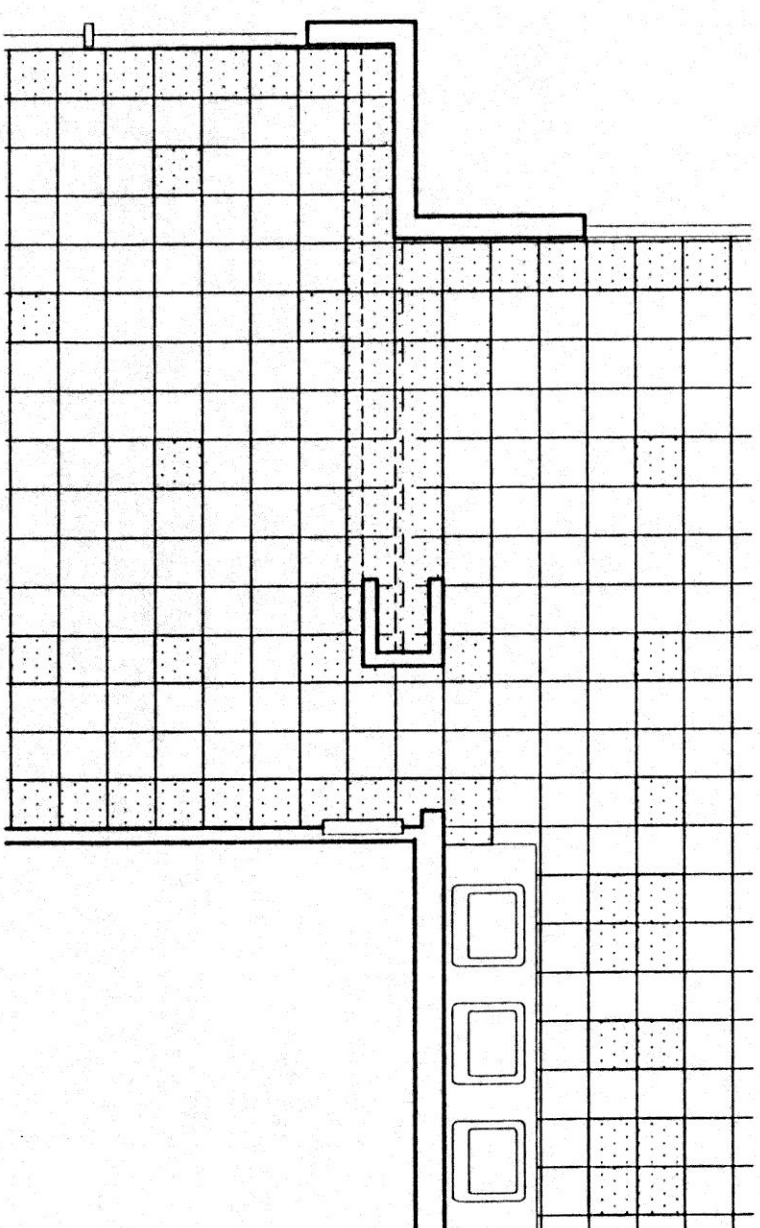

LEGEND

	TARGETT 'SIGNAL S'
	COLOR 3513 'FURNISHING WHITE'
	TARGETT 'SIGNAL S'
	COLOR 5522 'AQUA' 'RED WUP'

INSTALLER TO SUBMIT
LAYOUT DRAWING FOR
REVIEW AND APPROVAL
PRIOR TO INSTALLATION

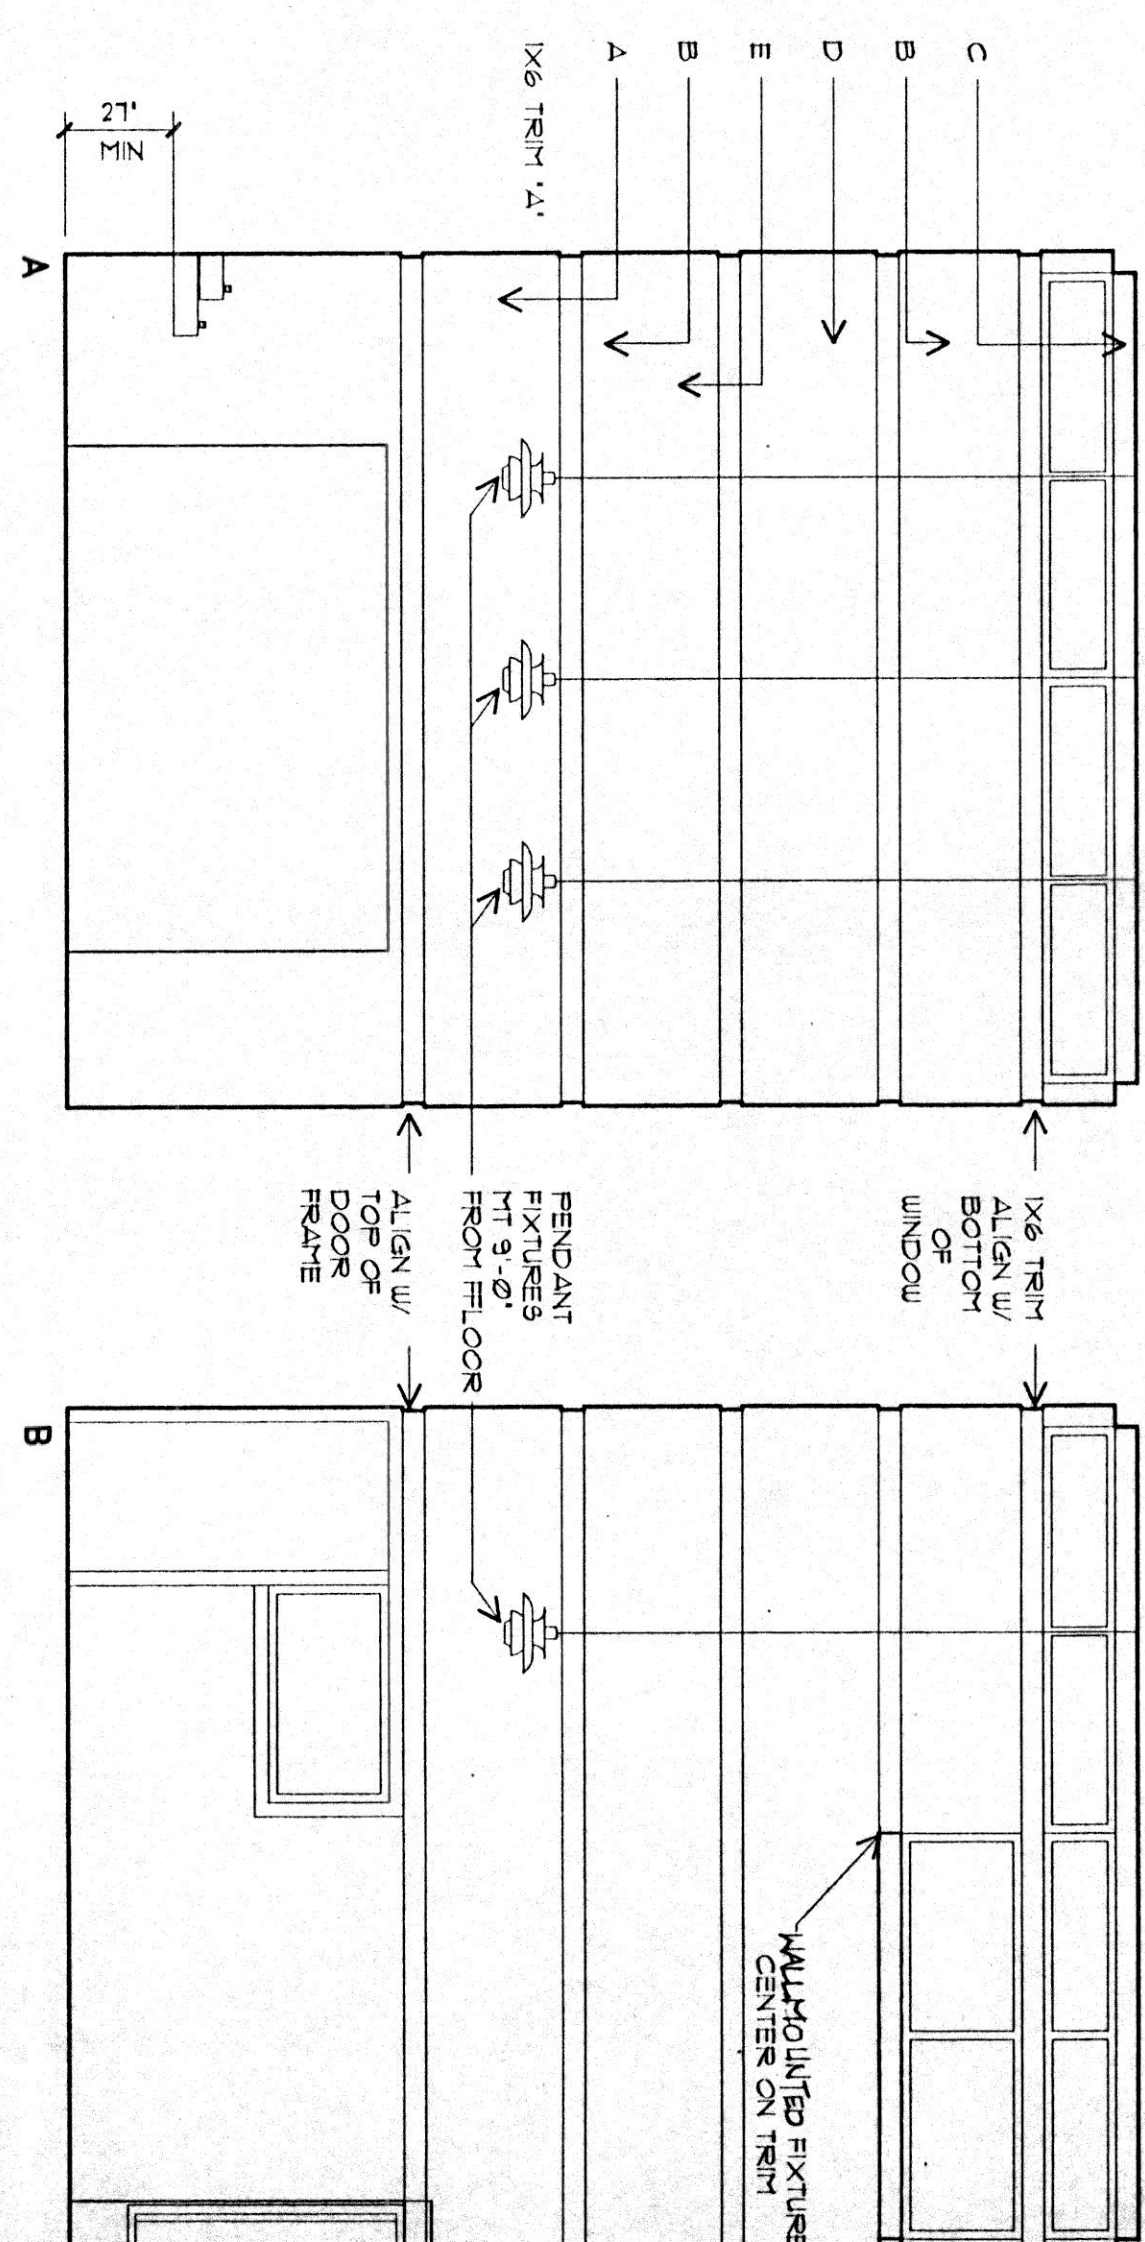

B4 108 ENTRY/LOBBY
1/4"=1'-0"

INTERCOLLARS

ALL PAINT COLOR SELECTIONS BASED ON SHEERIN
WILLIAMS COLORS. PLASTIC LAMINATE COLORS ARE
BASED ON PIONTE BRAND COLORS

[illegible]

NOTE: ALL INTERIOR WALLS & WOOD TRIM ARE 'A' UNLESS OTHERWISE NOTED. ALL INTERIOR DOORS ARE 'B' UNLESS OTHERWISE NOTED.

WARRENTON/ASTORIA

PROJECT NO. :	94084
FILE NO. :	A6.dwg
DATE :	JUNE 15, 1995
REVISIONS :	DATE : DESC :

SHEET TITLE ,
INT ELEVATIONS
& DETAILS



A6

MCM
ARCHITECTS



A PROFESSIONAL CORPORATION
1022 SOUTHWEST 94LAWN SUITE 350
PORTLAND, OREGON 97205-2447 USA
TELEPHONE 503 222 5757 FAX 503 241 1514

A PROFESSIONAL CORPORATION
1022 SOUTHWEST SALMON SUITE 350
PORTLAND, OREGON 97205-2447 USA
TELEPHONE 503 222 5757 FAX 503 241 1514


HEAD START CENTER

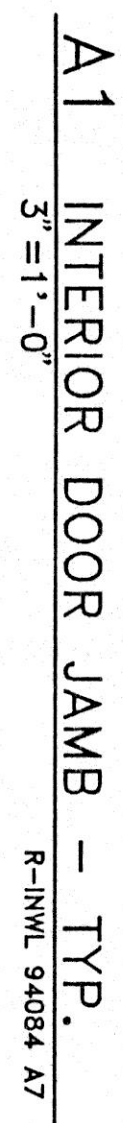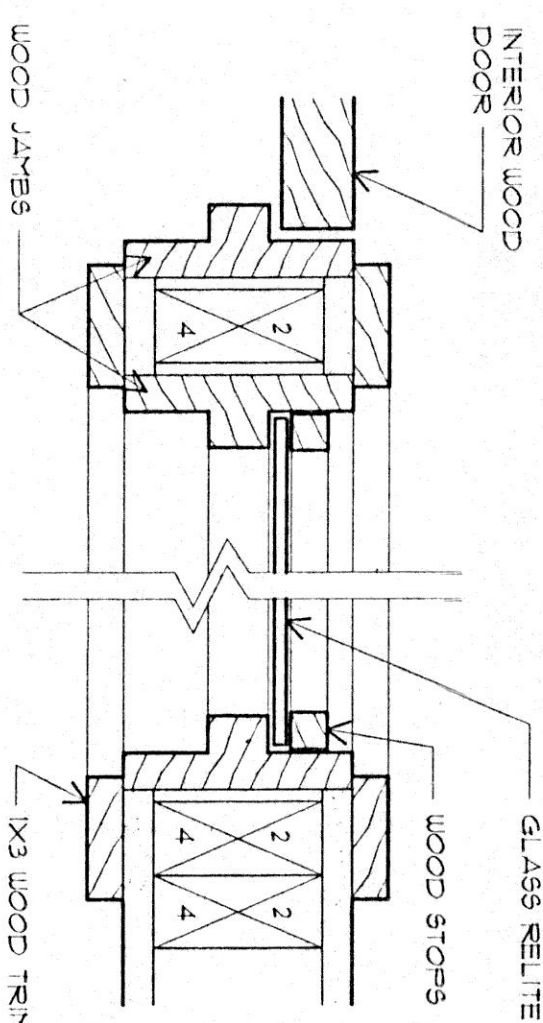


A2 INTERIOR RELITE JAMBS - TYP.
3"=1'-0" R-INWL 94084 A7

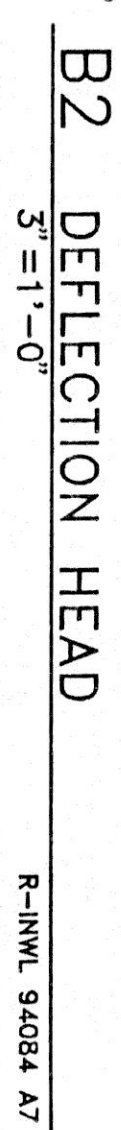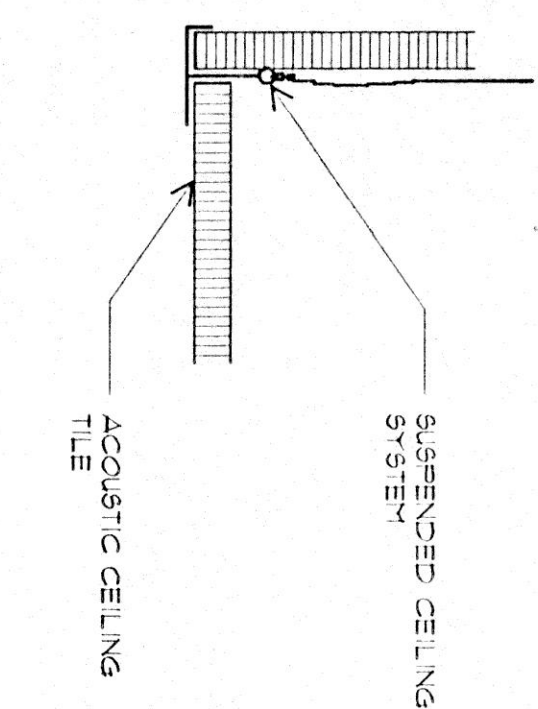



B3 SUSP. CEILING DETAIL
3"=1'-0" R-CELL 94084 A7

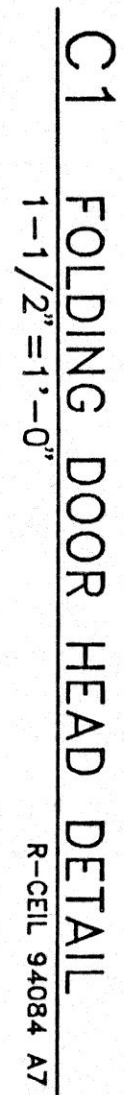

C2 SUSPENDED CEILING BRACING
1/4" = 1'-0"
R-CELL 94084 A7

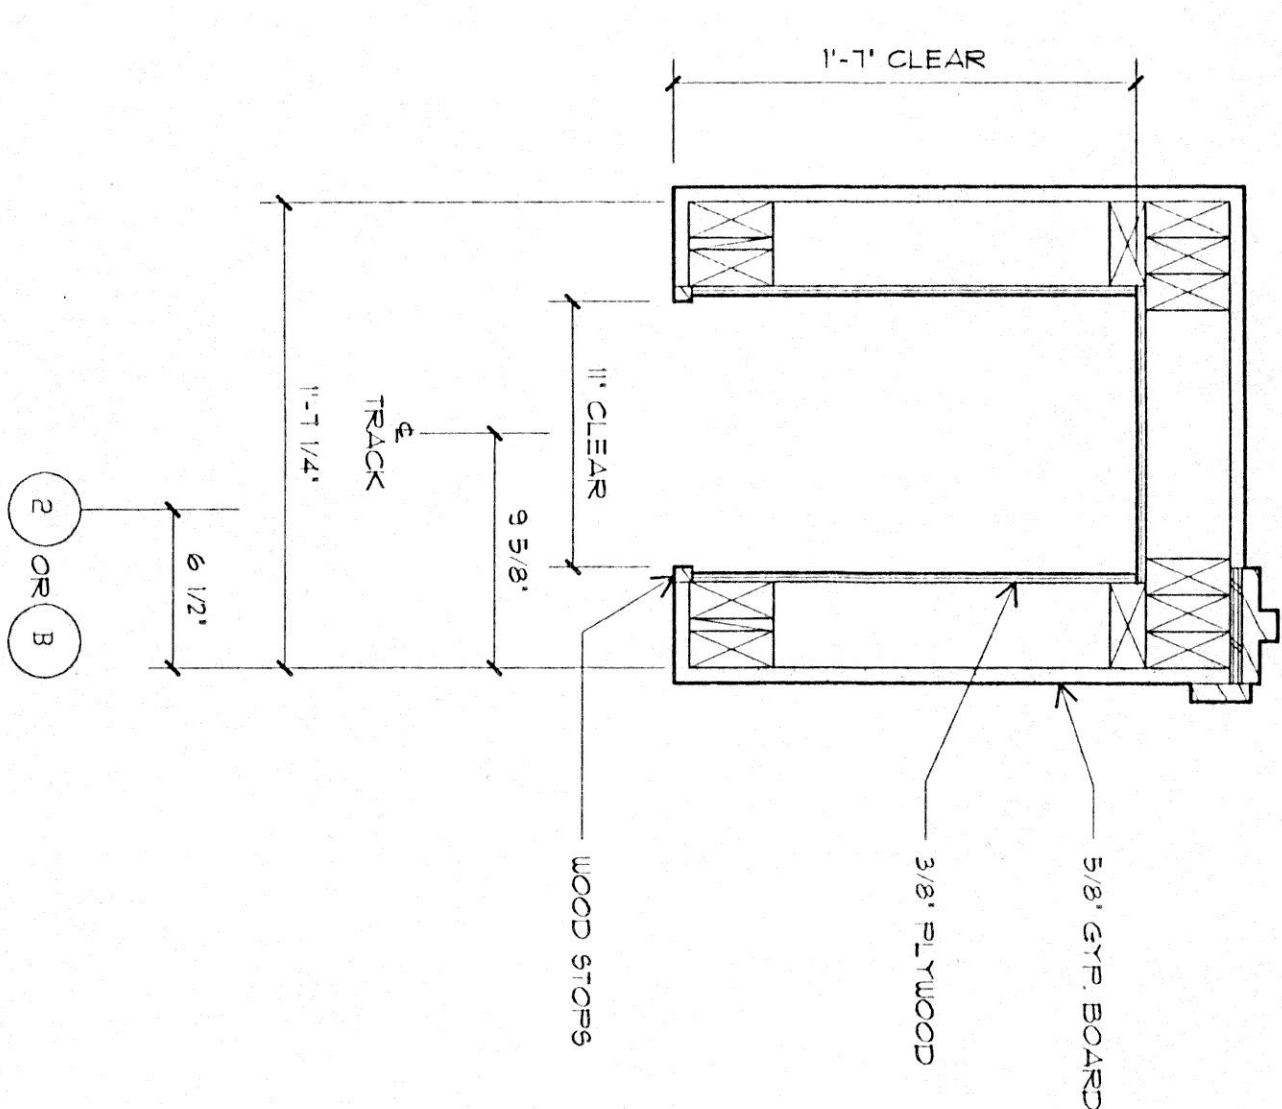

E1 FOLDING DOOR POCKET
1-1/2"=1'-0" R-INWL 94084 A7

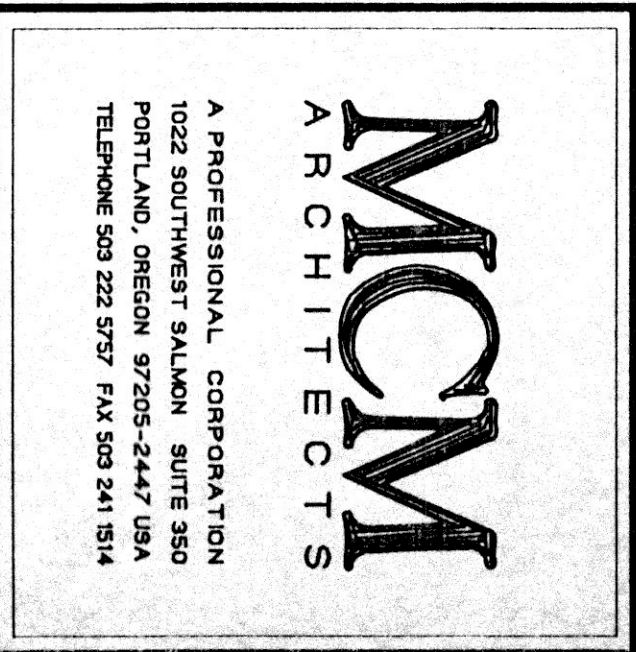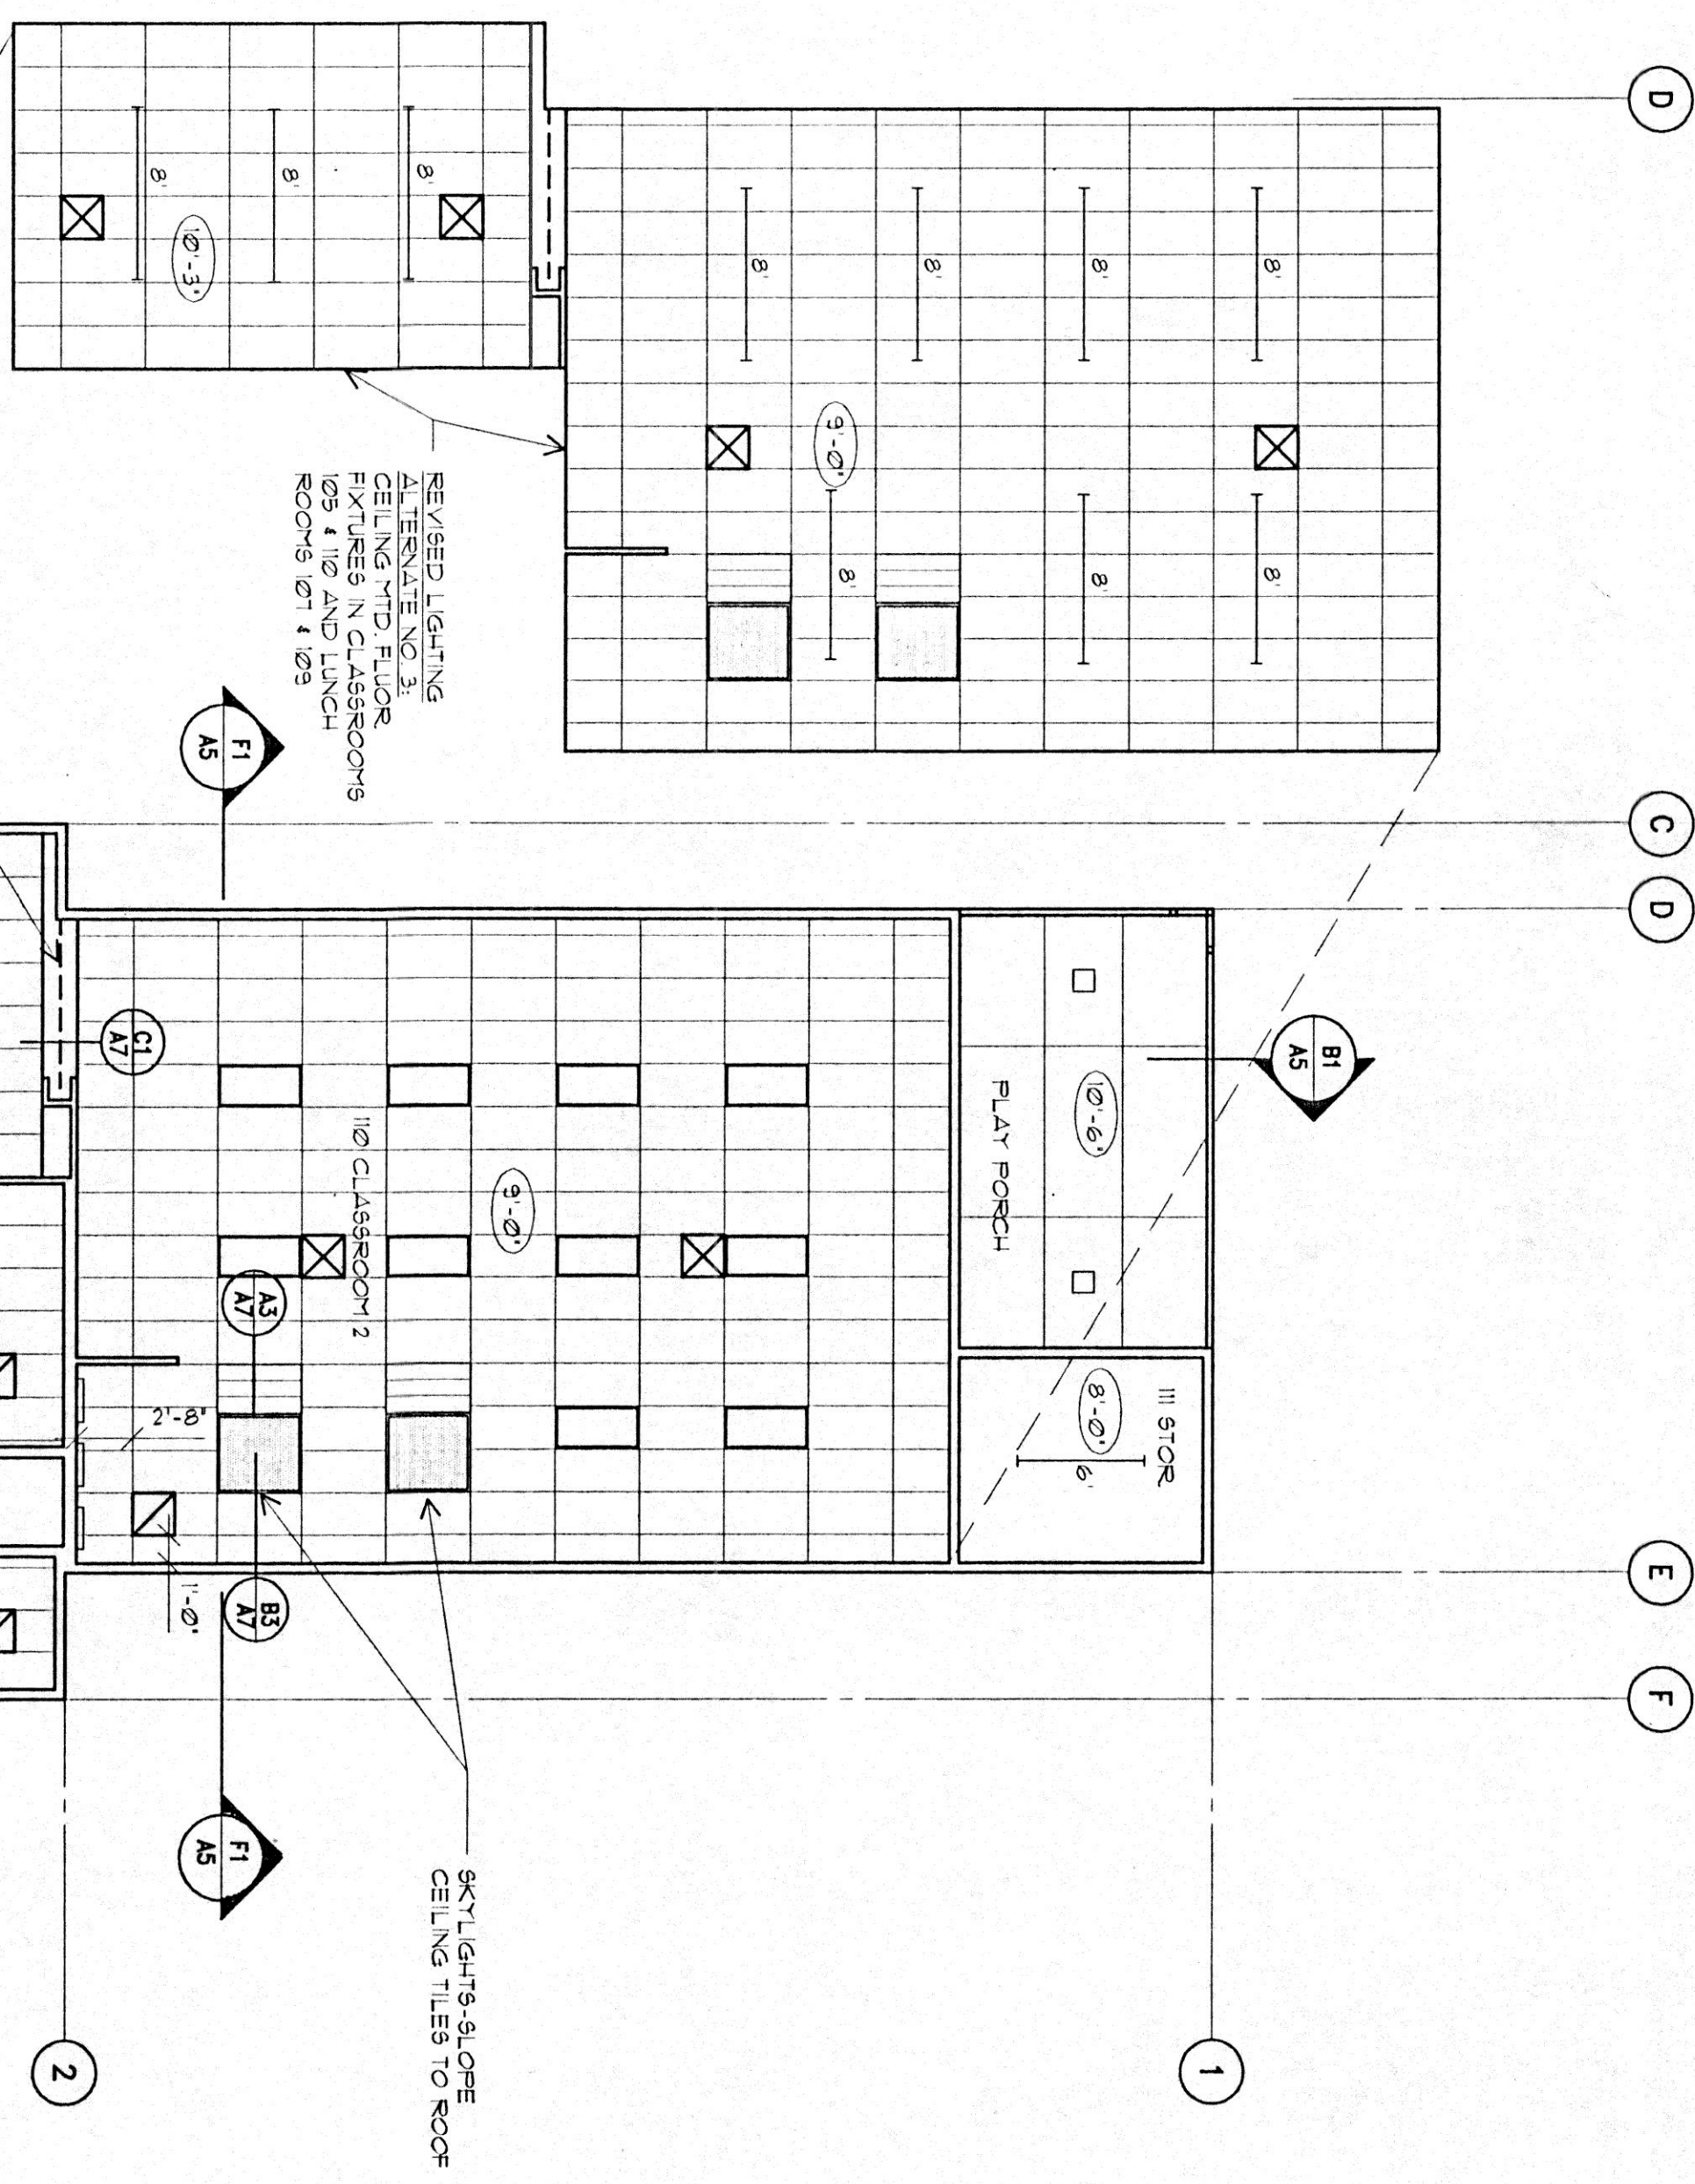

PROJECT HEAD START CENTER

WARRENTON/ASTORIA

PROJECT NO. :	94084
FILE NO. :	A7.dwg
DATE :	JUNE 15, 1985
REVISIONS :	DATE : DESCRIPTION


SHEET TITLE ,
REFLECTED
CEILING PLAN

A7
SHEET NO. 1

GENERAL NOTES


- GENERAL**
- These notes set minimum standards for construction. The drawings govern over the General Notes or when shown.
 - The General Notes or when shown.
 - Coordinate locations of openings through floors, roof and walls with architectural, mechanical and electrical plans. Notify design agency of any discrepancies.
 - Contractor shall provide all necessary temporary support prior to completion of structure.
 - First floor shall be permanently attached in walls prior to back filling against structure.
 - Where reference is made to ASTM, AISC, ACFI or other standards, the latest issue shall apply.
 - Design shall be in strict compliance with the Uniform Building Code as amended by the State of Oregon and all other state and local codes and building requirements that apply.
 - Design Criteria:
 - Basic Roof Load (snow) 25#/sq ft. (snow build up load analysis)
 - Floors 40#/sq ft.
 - Roof Deck 20#/sq ft.
 - Wind 80 mph Exposure "B"
 - Seismic Zone 3
 - Mechanical equipment, mechanical and sprinkler piping larger than 2" diameter or other items producing a longer load over 50# shall be hung by a system approved by the engineer.
 - Where reference is made to transfer these loads to the main structural frame or walls unless otherwise approved.
 - Shop drawings shall be required on reinforcing steel, plate laminated members, deflected joints, metal plate connected trusses and shall be reviewed prior to fabrication.
- FOUNDATIONS**
- Design soil pressure assumed to be 2400 psf LL, plus DL (per soils engineer)
 - All footings to bear on approved compacted fill (minimum 18" below final grade. Notify design agency before proceeding if any unusual conditions are encountered in the footing excavations.
 - Do not excavate closer than 2' slope below footings.
 - Excavations may be made under continuous footings for pipes. Backfill to be approved by engineer.
 - The foundation investigation report showing logs of borings and other pertinent data is available at the architect's office for inspection by all qualified bidders.
- CONCRETE**
- Average concrete strength as determined by job cast lab cured cylinders at 28 days (plus increase depending upon the plant's standard deviation as specified in ACI 308.2R) to be 4000 psi for all uses.
 - Minimum Mix Requirements:
 - Slump: 2 to 4 inches. Deviation from design slump +/-2" to -1".
 - Concrete content per yard: 5 sacks @ 3400 psi
 - Air Entrainment: Per ACI at exterior slabs.
 - Temperature correction: Per ACI (see manual) for all slabs.
 - Place and cure all concrete per ACI codes and standards.
 - Provide control joints in all slabs on grade at 20' +/- o.c. each way maximum unless otherwise shown on plans. Provide heavy (3/4") isolated joints at 5' +/- o.c. and 12" precast expansion joints at 30' +/- o.c. in all exterior walls and slabs.
- REINFORCING**
- Reinforcing steel for concrete shall conform to U.B.C. standards No. 26-4.76 and ASTM A615 grade 60 for all uses.
 - All welded reinforcing steel shall conform to ASTM A706.
 - Fabricate and install reinforcing steel according to the Manual of Standard Practice for Reinforcing Steel Institute, Portland Cement Association, Standard 13.3.
 - Provide 2" +/- o.c. concrete (minimum 18" below final grade) under horizontal reinforcing in walls and footings at all corners and intersections.
 - Splices in wall and slab reinforcing shall be lapped 30 diameters and shall be staggered at least 4' at alternate bars.
 - Reinforcing steel shall be placed at top and bottom of all walls unless noted otherwise on plan.
 - Provide dowels from footings to match all vertical wall, pierce, and column reinforcing. Lap 30 diameters or 2' +/- minimum.
 - Lap all bars in intersecting footings 2' +/- or 30 diameters, whichever is greater.
 - All welded reinforcing steel shall conform to U.B.C. standards No. 26-4.76 and ASTM A706.
 - All wire fabric shall be supplied and laid in flat sheets and shall be clamped to proper position in slabs.
 - Reinforcing shall not be bent or displaced for the convenience of other trades unless approved by the engineer.
 - Minimum cover over reinforcing steel shall be:
 - 1" U/L from top in slabs on grade
 - 3" U/L to bottom of footing
 - Center of wall
 - Reinforcing steel shall be placed near center of slab.

SHEAR WALL SCHEDULE		
MARK		TYPICAL
A	1" FLUID, INDEX 24# (BLOCK EDGES) w/ 10d # 4 o/c EDGES 10d # 6 o/c FIELD	EXTERIOR

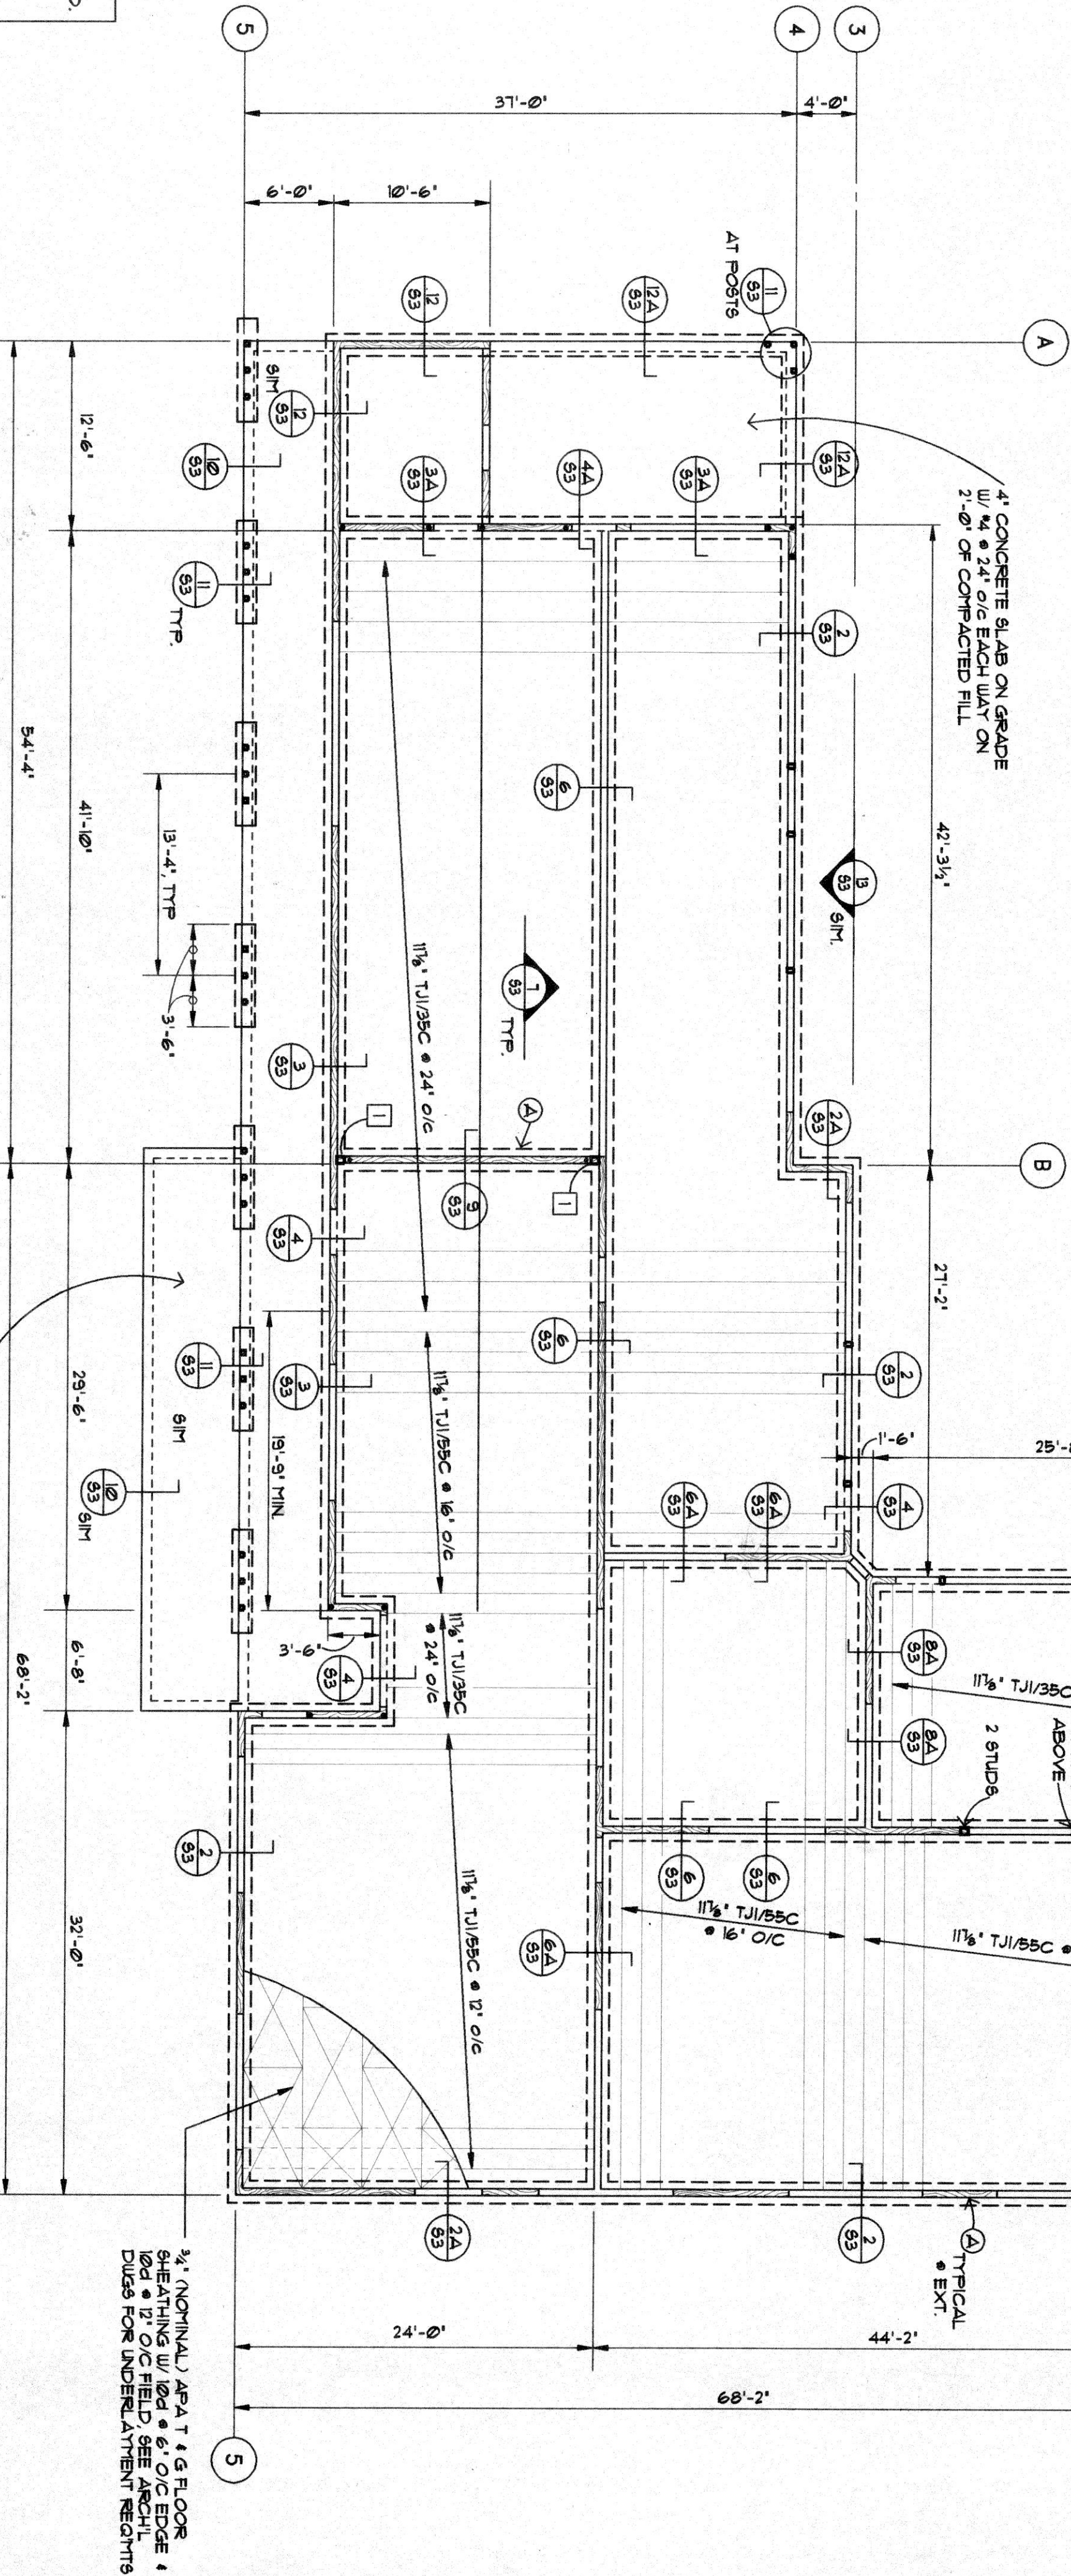

- PREFABRICATED FLOOR JOISTS**
- All roof and floor members shall be manufactured by Trus Joist Manufacturing Corp.
 - All joists shall conform to all provisions of the 1991 Uniform Building Code.
 - Joists shall not exceed a live load deflection of (L/360) or the working stresses as specified in U.B.C. standards for appropriate materials for the loads indicated on the drawings.
 - Just manufacturer shall furnish complete engineering shop drawings with Oregon registered professional engineer's seal.
 - Manufacturer shall furnish all end and intermediate stiffeners.
 - Blocking and/or shear panels and metal bracing assemblies as required to provide a complete floor or roof structural system.
 - All bracing, blocking, hardware, blocking, hangers, etc. that connect to the joists shall be specified on the drawings.
 - Manufacturer to inspect all trusses after they have been erected and sheathing blocking laterally. Provide lateral bracing as necessary.
 - Manufacturer to provide complete erection care during erection of joists to prevent them from buckling laterally.
 - Manufacturer to submit certificate to engineer that the inspection was made and that the joists meet the manufacturer's design and installation requirements.

- NOTES:**
- 6x6 POST WITH SIMPSON HDA HOLDDOWN - SEE 85

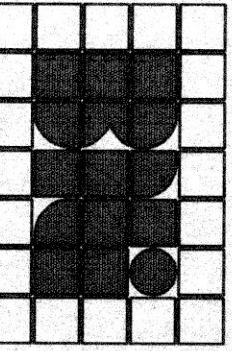


BERRY-HORDLING ENGINEERS, INC.
701 SE ALLEN STREET
PORTLAND, OREGON 97202
PHONE (503) 253-0777
FAX (503) 253-0778

HEAD START

WARRENTON / ASTORIA



PROJECT NO. 84-080
DATE: 06/01/95
DRAWN BY: JUNE K. SMOG
CHECKED BY: JUNE K. SMOG
SCALE: 1/8" = 1'-0"

FOUNDATION / FIRST FLOOR FRAMING PLAN

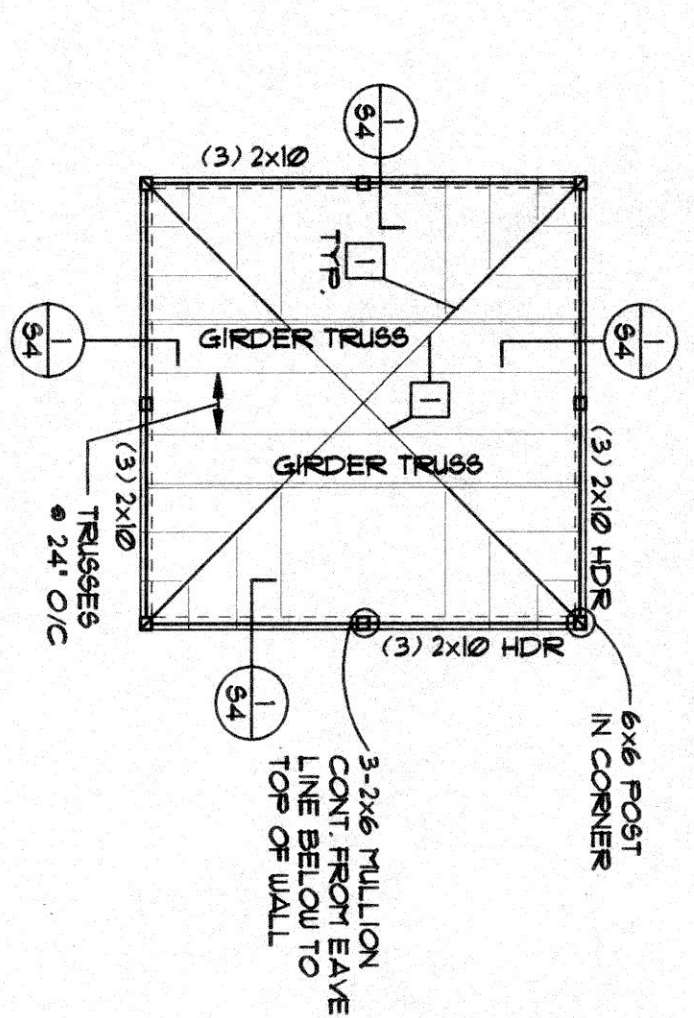

52


- NOTES:
- 1 PROVIDE 2x4 FLAT BLOCKING AT ALL HIP AND VALLEY'S. EDGE NAIL FLATWOOD TO BLOCKING.
 - 2 SHADING INDICATES OVERBUILT AREA. ADD 5 PSF TO TOP CHORD LOADING.
 - 3 ALL GULLY AT BEAMS SHOWN HAVE ZERO CAMBER (C=0).
 - 4 UNLESS NOTED OTHERWISE.
 - 5 HEADER - 4x6.
 - 6 SHORE THIS CORNER UNTIL WALL ABOVE HAS BEEN SHEATHED.
 - 7 SKYLIGHTS - SEE ARCH'L.

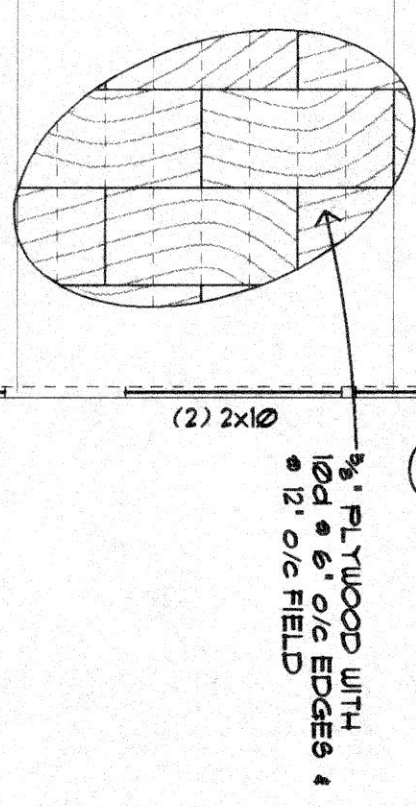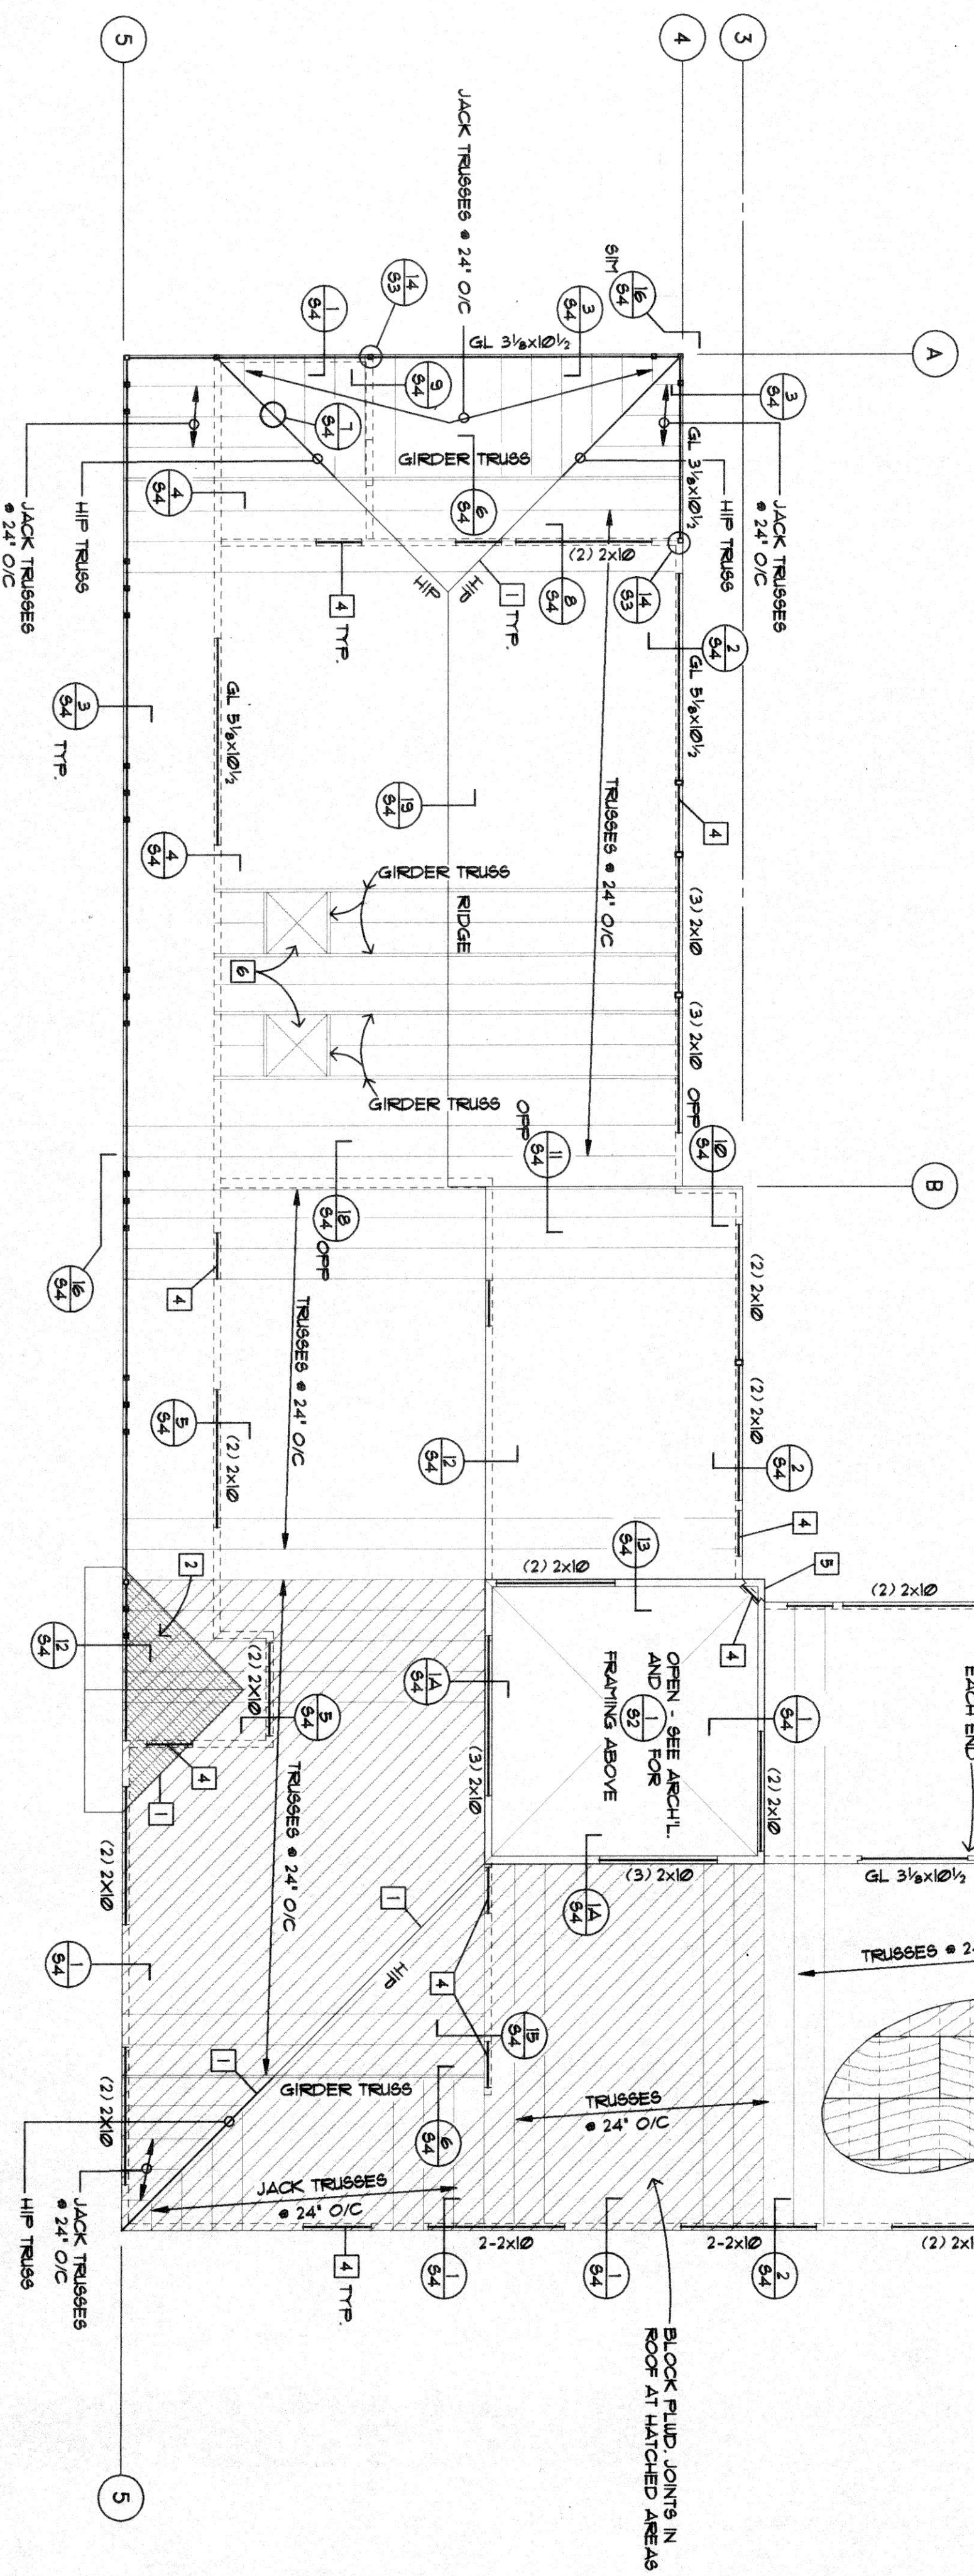

ROOF TRUSS DESIGN LOADS:
TOP CHORD 25 PSF LIVE LOAD
10 PSF DEAD LOAD
BOTTOM CHORD 5 PSF DEAD LOAD

ROOF FRAMING PLAN

1/8" = 1'-0"

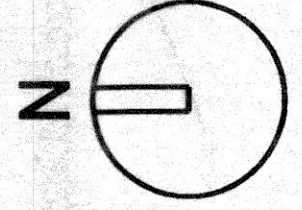


BERRY-HORLING ENGINEERS, INC.
701 SE ALLEN STREET
PORTLAND, OREGON 97202
PHONE (503) 255-0777
FAX (503) 255-0778

HEAD START CENTER

WARRENTON / ASTORIA

PROJECT NO. 84-400
DATE: 88, PMO
JUNE 15, 1988
REVISIONS / DATE: 10/25/88
DESIGNER: JON J.

ROOF FRAMING PLAN

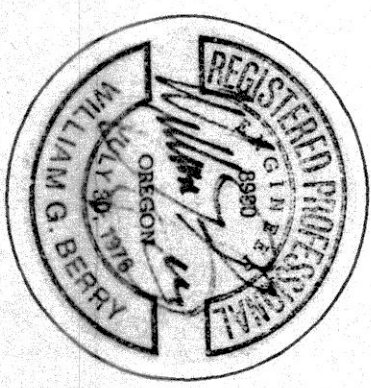

PLUMBING CONNECTION SCHEDULE

MARK	DESCRIPTION	W	V	CW	HU	140 HU	REMARKS
UC-1	WATER CLOSET CHILD USE FLOOR MOUNTED 1/2 GRIFF FLUSH VALVE	4"	2"	1"	-	-	JUNIOR SIZE FIXTURE
UC-2	WATER CLOSET FLOOR MOUNTED 1/2 GRIFF FLUSH VALVE	4"	2"	1"	-	-	
UC-3	HANDICAPPED MOUNTING WATER CLOSET VALVE 1/2 GRIFF FLUSH VALVE FLOOR MOUNTED	4"	2"	1"	-	-	COORDINATE FLUSH VALVE LOCATIONS WITH GRAB BARS
UC-4	WATER CLOSET CHILD USE 1/2 GRIFF FLUSH VALVE	4"	2"	1"	-	-	WITH FIXTURE CARRIER
L-1	LAVATORY CHILD USE COUNTER MOUNTED	2"x1/2"	1/2"	1/2"	1/2"	-	SELF CLOSING FAUCETS WITH 110°F TEMPERATURE LIMIT DEVICE HANDICAPPED TRIM
L-2	LAVATORY HANDICAPPED TRIMMED WALL MOUNTED	2"x1/2"	1/2"	1/2"	1/2"	-	SELF CLOSING FAUCETS WITH 110°F TEMPERATURE LIMIT DEVICE
DF-1	DRINKING FOUNTAIN WALL MOUNTED - SINGLE UNITS	1 1/2"x1/2"	1/2"	1/2"	-	-	WITH FINISH CARRIER MOUNTING PLATE MODEL #10024 WITH ALL-THREAD STUDS. PROTECT STUDS DURING CONSTRUCTION.
DF-2	DRINKING FOUNTAIN HANDICAPPED MOUNTING WALL MOUNTED - DUAL UNITS	(2) 1 1/2"x1/4"	(2) 1/2"	(2) 1/2"	-	-	WITH FINISH CARRIER MOUNTING PLATE MODEL #10024 WITH ALL-THREAD STUDS. PROTECT STUDS DURING CONSTRUCTION.
S-1	TEACHER SINK IN CLASSROOM KITCHEN HANDWASH SINK	2"x1/2"	1/2"	1/2"	1/2"	-	
S-2	DIAPER CHANGE SINK COUNTER MOUNTED	2"x1/2"	1/2"	1/2"	1/2"	-	
S-3	HOP SINK BASIN FLOOR MOUNTED	3"	2"	1/2"	1/2"	-	PROVIDE BACKING FOR FAUCET
S-4	3 COMPARTMENT POT/PAW SINK WITH GARABAGE DISPOSAL AND PRESHASH SPRAY ON RIGHT HAND TUB WITH SPRAY	(3) 1 1/2" 2"x3"	2"	(2) 3/4"x1/2"	(2) 3/4"x1/2"	(2) 3/4"x1/2"	SINK FINISHED BY OWNER INSTALLED BY CONTRACTOR. PROVIDE FAUCETS IN WALL. FOR FAUCETS
S-5	VEGETABLE PREP SINK WITH SPRAY	2x1 1/2"	1 1/2"	1/2"	-	1/2"	
DW	DISH WASHER	2" WU TO FS				3/4" HB	DISHWASHER FURNISHED BY OWNER INSTALLED BY CONTRACTOR. PROVIDE CONNECTIONS & FITTINGS & TUB.
FD	FLOOR DRAIN COORDINATE EXACT LOCATION WITH THE ARCHITECT	3"	2"	1/2"	-	-	PROVIDE TRAP PRINTER WITH ACCESS PANEL. REMOVE BLOCKING & TRAINING FOR DRAIN SUPPORT.
FS	FLOOR SINK WITH 1/2 GRIFF & TRIP FLUSH FINISH FLOOR	3"	2"	1/2"	-	-	COORDINATE EXACT LOCATION WITH KITCHEN CONSULTANT. PROVIDE TRAP PRINTER WITH SHUT OFF VALVE.
HB-1	EXTERIOR HOSE BIBB	-	-	3/4"	-	-	PROVIDE BACKING IN WALL
F-1	WASHER DRYER RECESSED CONNECTION BOX	2"	1 1/2"	1/2"	1/2"	-	PROVIDE GUT GUT RECESSED WASHER DRYER SUPPLY/DRAIN UNIT AND TUB.
H-1	KITCHEN HOOD W/ ANNUL FIRE PROTECTION	-	-	-	-	-	6" LENGTH BY DEPTH APPROPRIATE FOR 6"50 BEL FLOW VALVE CONNECTION

EQUIPMENT SCHEDULE

MARK	MANUFACTURER & MODEL	HEAD	GPM	H.P.	MBTUH	REMARKS
P-1	BELL & GOSSETT BG10049	5	3	1/12		3/4" FLANGE
WH-1	AO SMITH BTG-120				120	75 GALLON

EXHAUST FAN SCHEDULE

MARK	MANUFACTURER & MODEL	CFM	SP7 US	H.P.	TYPE	REMARKS
EF-1	PAGE SCF-57A	375	5	1/8	FC	HORIZONTAL DISCHARGE 4" DRAIN DOWN DISCHARGE BOTTOM ACCESS
EF-2	PAGE SCF-63A	425	5	1/8	FC	HORIZONTAL DISCHARGE 4" DRAIN DOWN DISCHARGE BOTTOM ACCESS
EF-3	PAGE SCF-52A	265	5	1/8	FC	HORIZONTAL DISCHARGE 4" DRAIN DOWN DISCHARGE BOTTOM ACCESS
EF-4	ILG USC H-6	B-60	3/4	7/8	BI	UPPER LIFT GREASE EXHAUST ROOF FAN WITH EXTENDED CURB

LEGEND

SYMBOL	ABBR	DESCRIPTION	SYMBOL	ABBR	DESCRIPTION
	U	SANITARY WASTE OR SOIL LINE		SAD	SUPPLY AIR DRIER (ARROWS REPRESENT NUMBER & DIRECTION OF FLOW)
	V	BANTARY VENT LINE		RAGE	RETURN OR EXHAUST GRILLE
	CW	DOMESTIC COLD WATER LINE		GRS	GRILLE SIZE (NICHES) NO OF BLOW TYPE
	HU	DOMESTIC HOT WATER LINE		FLD	FLEXIBLE LINK DWYER
	RUL	RAIN WATER LEADER		OBD	OFFROAD BLADE DWYER
	UN	NATURAL GAS		VD	VOLUME DWYER
	UN	UNION CONNECTION FITTING		2" L	2" LINED DUCTWORK (SEE SPECIFICATIONS)
	FL	FLANGED CONNECTION		FLEX	FLEXIBLE DUCT
	FL	DIRECTION OF FLOW		UCD	UNDER-CUT DOOR
	DN	PIPE 90° ELBOW UP		EAD	EXHAUST AIR DWYER
	UP	PIPE 90° ELBOW DOWN		OAD	OUTSIDE AIR DWYER
	PA	PIPE ANCHOR		RAD	RETURN AIR DWYER
	PG	PIPE GUIDE		SAD	SUPPLY AIR DWYER
	GC	GAS COOK VALVE		OBD	OFFROAD BLADE DWYER
	BFV	BUTTERFLY VALVE 3/4" AND LARGER		DWC	DISHWASHER WATER CLOSET (TOILET) VENT
	GV/BV	GATE VALVE OR BALL VALVE 1/2" TO 2"		LAV	LAVATORY SINK
	CKV	CHECK VALVE		GD	GARABAGE DISPOSAL
	DV	DRAIN VALVE WITH HOSE NIPPLE		CI	CAST IRON PIPE
	STR	LINE STRAINER		PVC	PLASTIC PIPE
	V	VALVE IN VALVE BOX		VTR	VENT THROUGH ROOF
	HB	HOSE BIBB		AF.F.	ABOVE FINISHED FLOOR ELEVATION
	TP & PRV	TEMP. & PRESSURE RELIEF VALVE		IE.	INVERT ELEVATION
	RBP / BFP	REDUCED PRESSURE BACKFLOW PREVENTER		TYP.	TYPICAL / TYPICAL OF *
	TH	THERMOMETER W/ WELL		RM	ROOM
	SA	PRESSURE AND TEMPERATURE SENSOR		CL	CENTERLINE
	PRV	PRESS. REDUCING VALVE CW OR G		BB	BANTARY BELLIER STORM DRAIN
	WCO	CLEAN-OUT WALL TYPE		DP	DOUBLE-PORT (N/H)
	FFO	CLEAN-OUT FINISH FLOOR TYPE		NMB	NOT IN MECHANICAL WORK
	CO	CLEAN-OUT END OF LINE		QF	QUARTER FURNISHED
	CP	CIRCULATING PUMP (N/LINE)		CFI.	CONTRACTOR FURNISHED & INSTALLED
	FD	FLOOR DRAIN		QFQ.	QUARTER FURNISHED QUARTER NOT IN CONTRACT
	AP	ACCESS PANEL / DOOR		WLS	KEY WALL SWITCH OR TOGGLE SWITCH NOT IN CONTRACT
	RD / OFD	ROOF DRAIN / OVERFLOW ROOF DRAIN		TMV	TEMPERED WATER MIXING VALVE
	CB	CIRCUIT BREAKER			

DRAWING INDEX

SHEET	DESCRIPTION	SCALE
M-1	LEGEND, SCHEDULES & DETAILS	NONE
M-2	FOUNDATION PLAN - MECHANICAL	1/8" = 1'-0"
M-3	FLOOR PLAN - MECHANICAL	1/8" = 1'-0"
M-4	CEILING/ATRIC PLAN - HVAC	1/8" = 1'-0"

NOTES

NUMBER	DESCRIPTION
1.	COORDINATE THE WORK WITH ALL TRADES BUT IN PARTICULAR WITH THE ELECTRICAL AND FINISH TRADES.
2.	REFER TO ARCHITECTURAL & STRUCTURAL PLANS FOR EXACT LOCATIONS.
3.	PLANS ARE TO BE CONSIDERED SUPPLEMENTARY BUT LOCATE WORK AS CLOSE TO WHERE SHOWN WHEN PHYSICALLY POSSIBLE WITHOUT CONFLICT TO OTHER TRADES.
4.	ALL MATERIALS INCLUDING NON-OWNER FURNISHED EQUIPMENT PRIOR TO STARTING WORKING FOR EQUIPMENT.
5.	SEAL ALL PIPE & DUCT PENETRATIONS AS DETAILED AND / OR AS SPECIFIED.
6.	COORDINATE LOCATION OF TOILET ROOM FLOOR DRAINS WITH THE ARCHITECTURAL AND STRUCTURAL PLANS.
7.	PROVIDE ACCESS DOORS FOR ALL VOLUME DWYERS & VALVES ABOVE HARD CEILING.

CHRIS
BILLINGS &
ASSOCIATES
CONSULTING ENGINEERS


4445 S.W. BARBUR BLVD
PORTLAND, OR 97201
PH: (503) 228-0000
FAX: (503) 258-2580

PROJECT /
HEAD START
CENTER


WARRENTON/ASTORIA





















PROJECT NO. 95-0030
FILE NO. HS-M-2-dwg
DATE: JUNE 1, 1995
REVISIONS: DATE: DESCRIPTION:



SHEET TITLE /
LEGEND, SCHEDULES
AND DETAILS
SCALE: 1/8" = 1'-0"
M-1

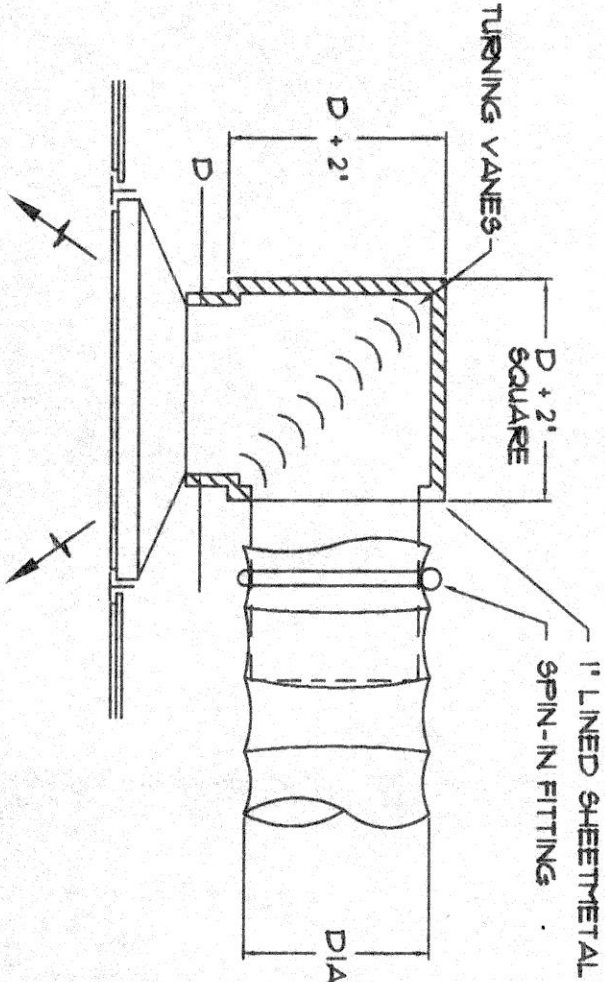


SUPPLY SHOWN RETURN SIMILAR
(W/O TURNING VANES)
2
M-1
DETAIL - SUPPLY / RETURN DIFFUSER
NOT TO SCALE

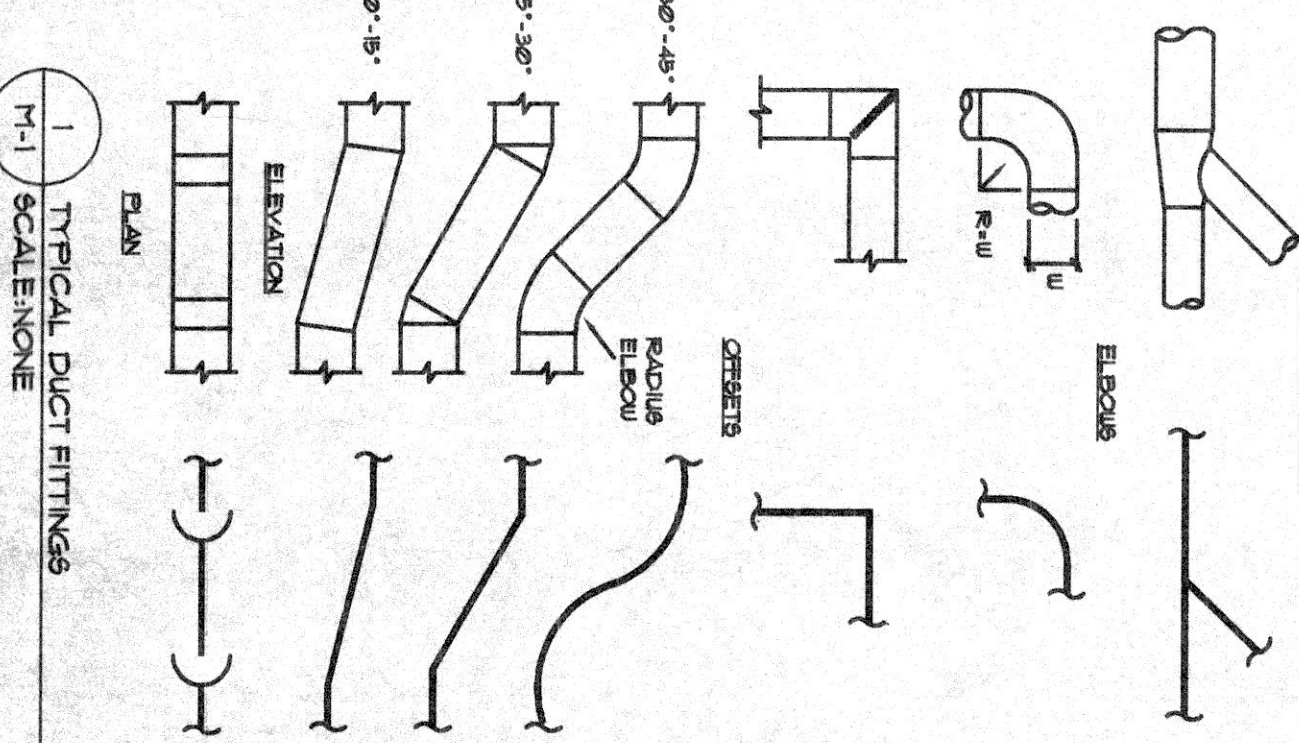

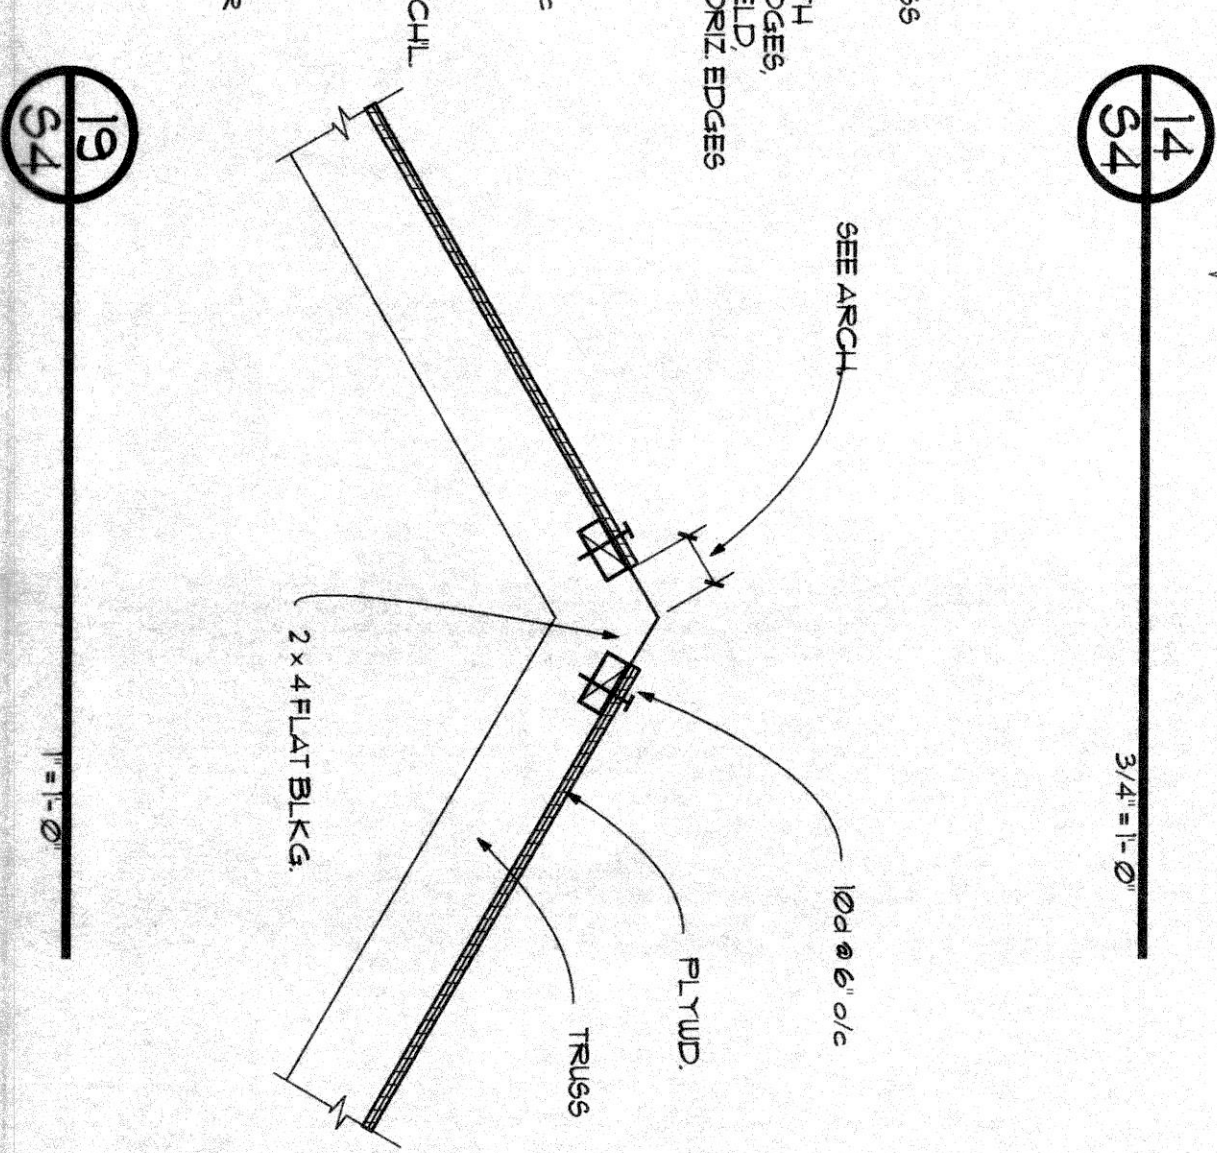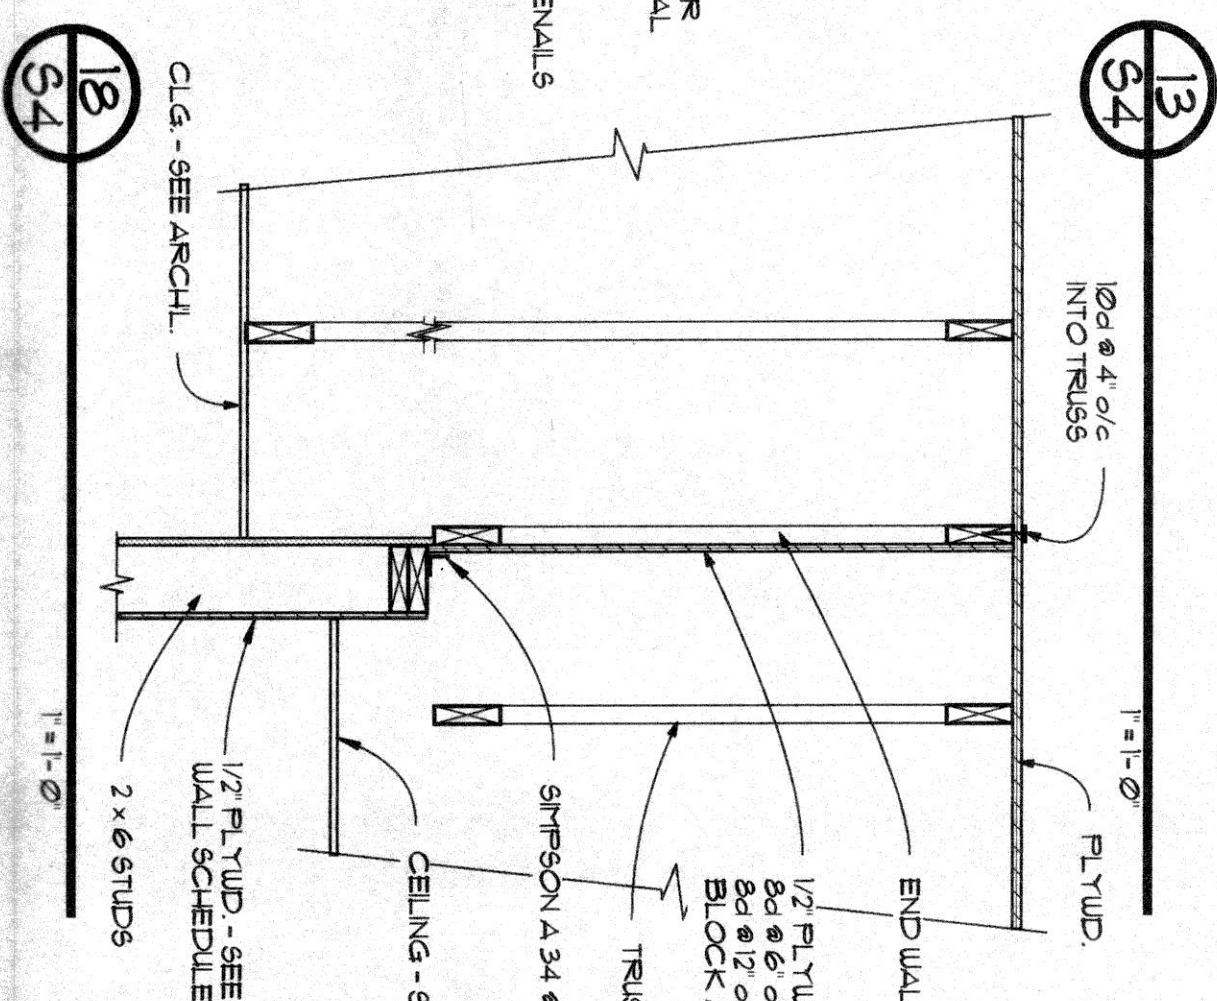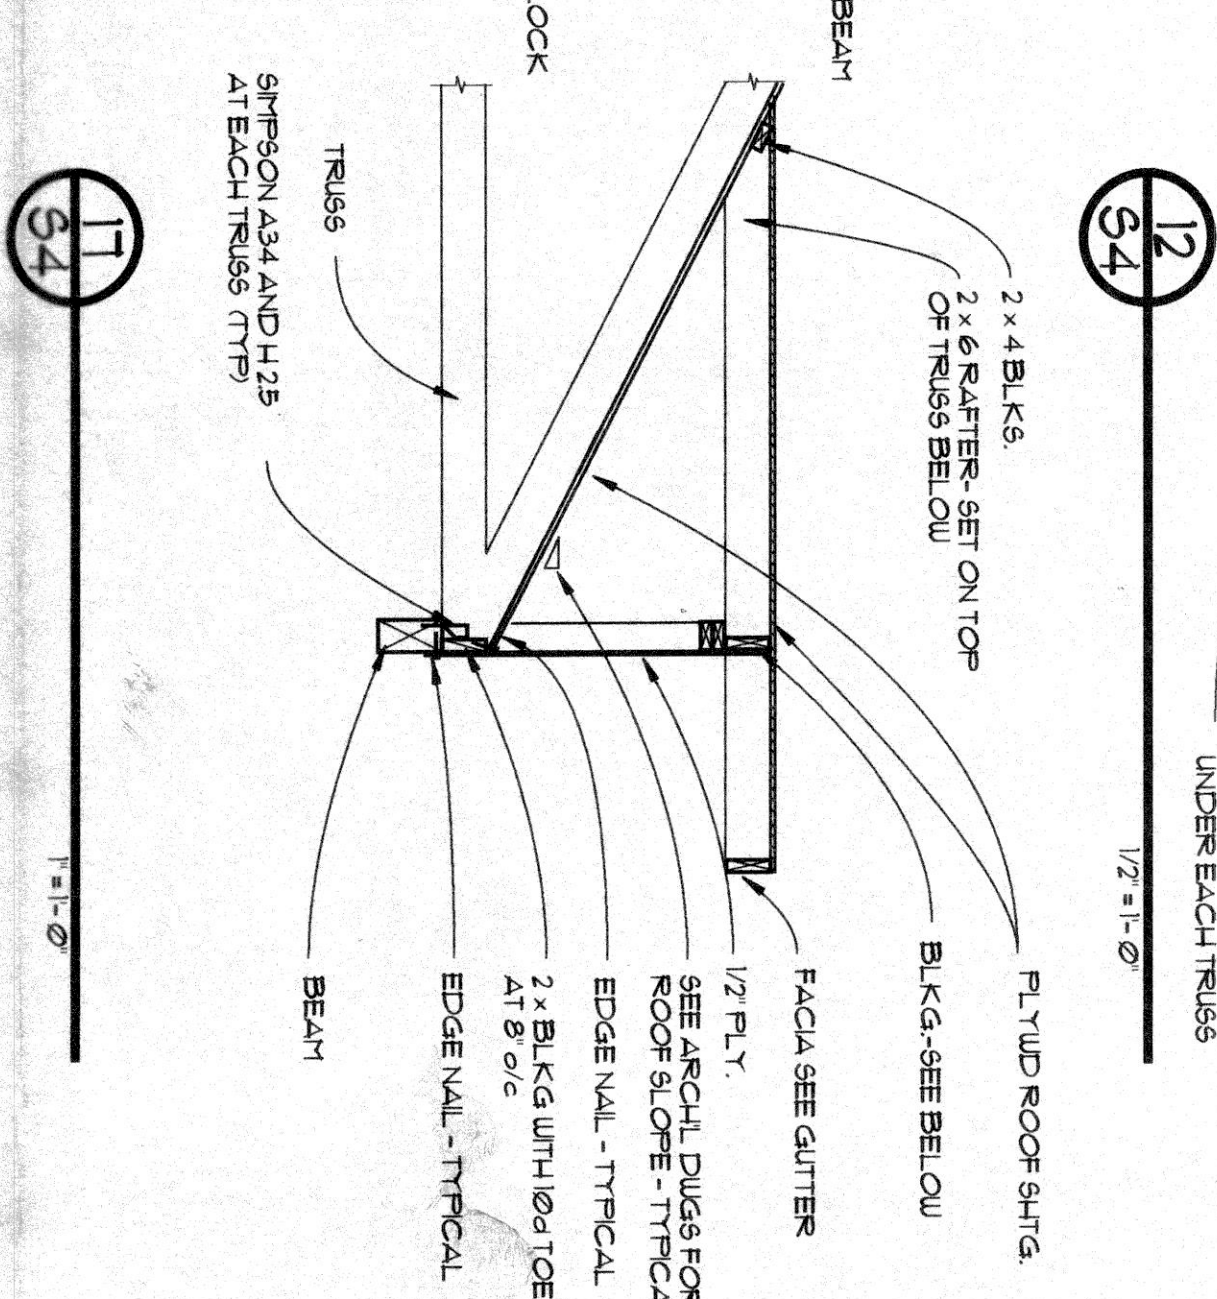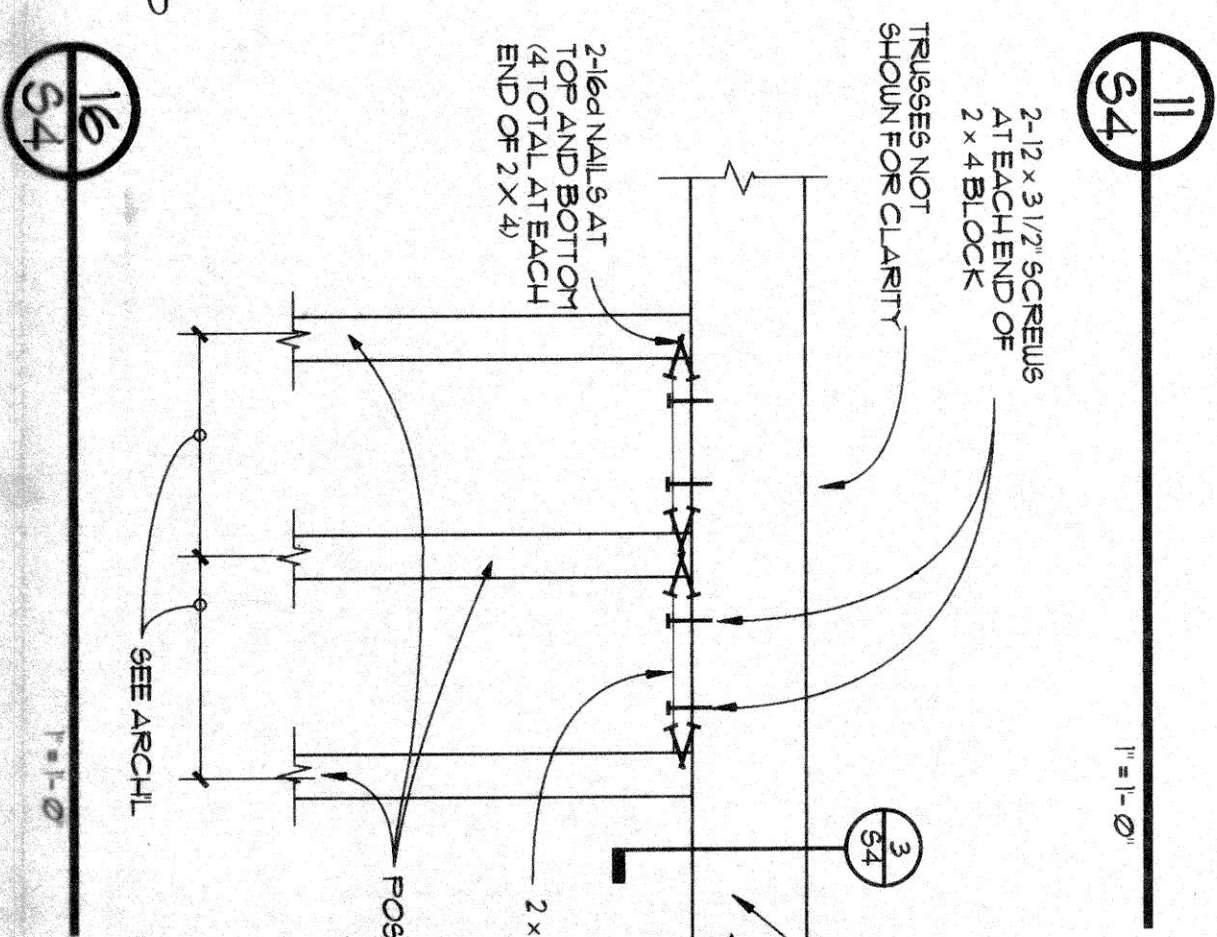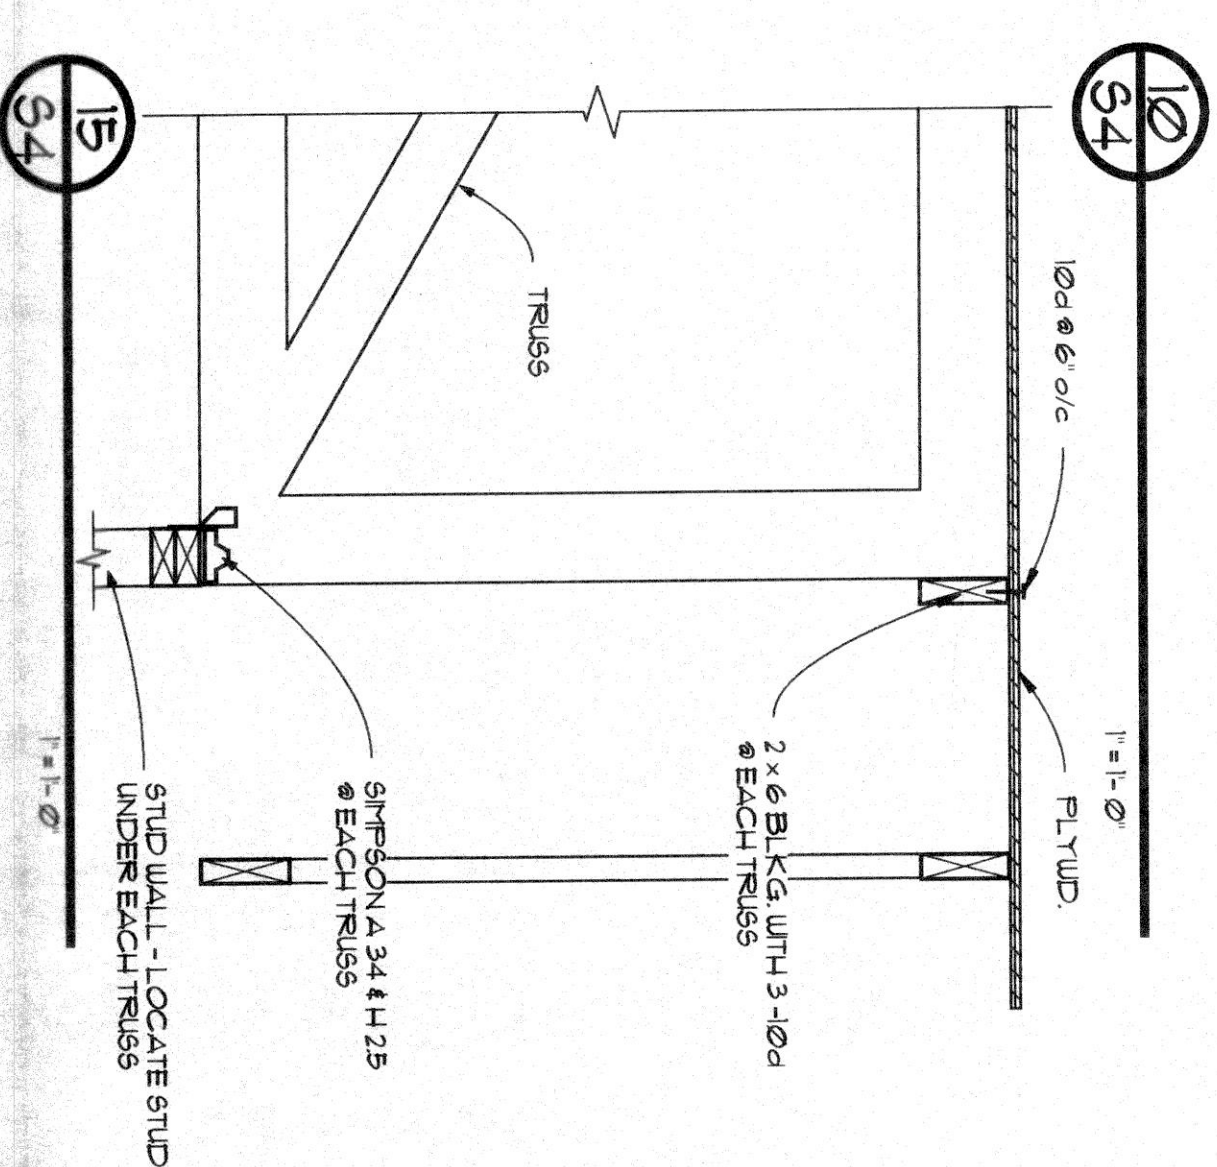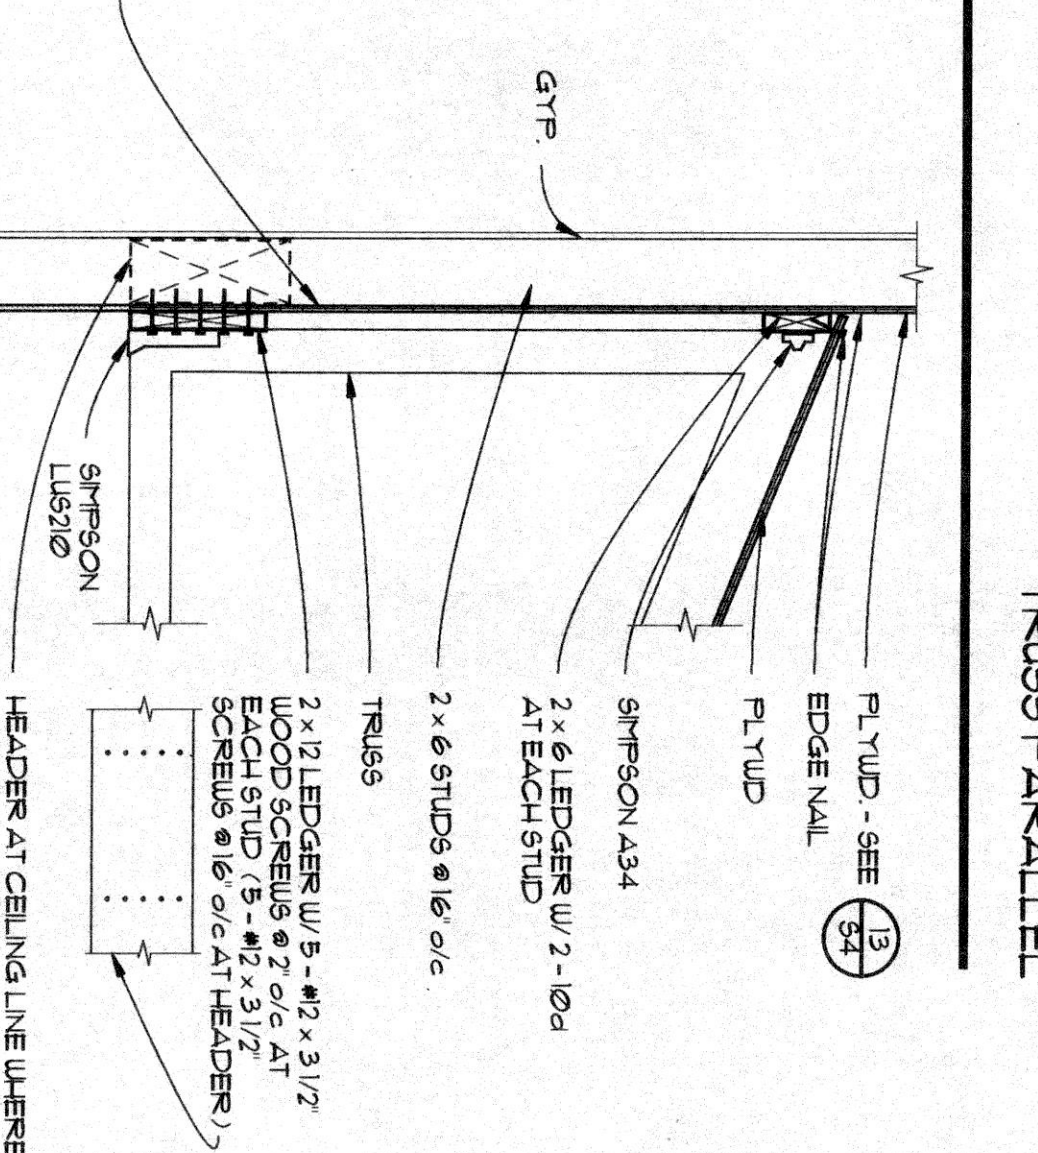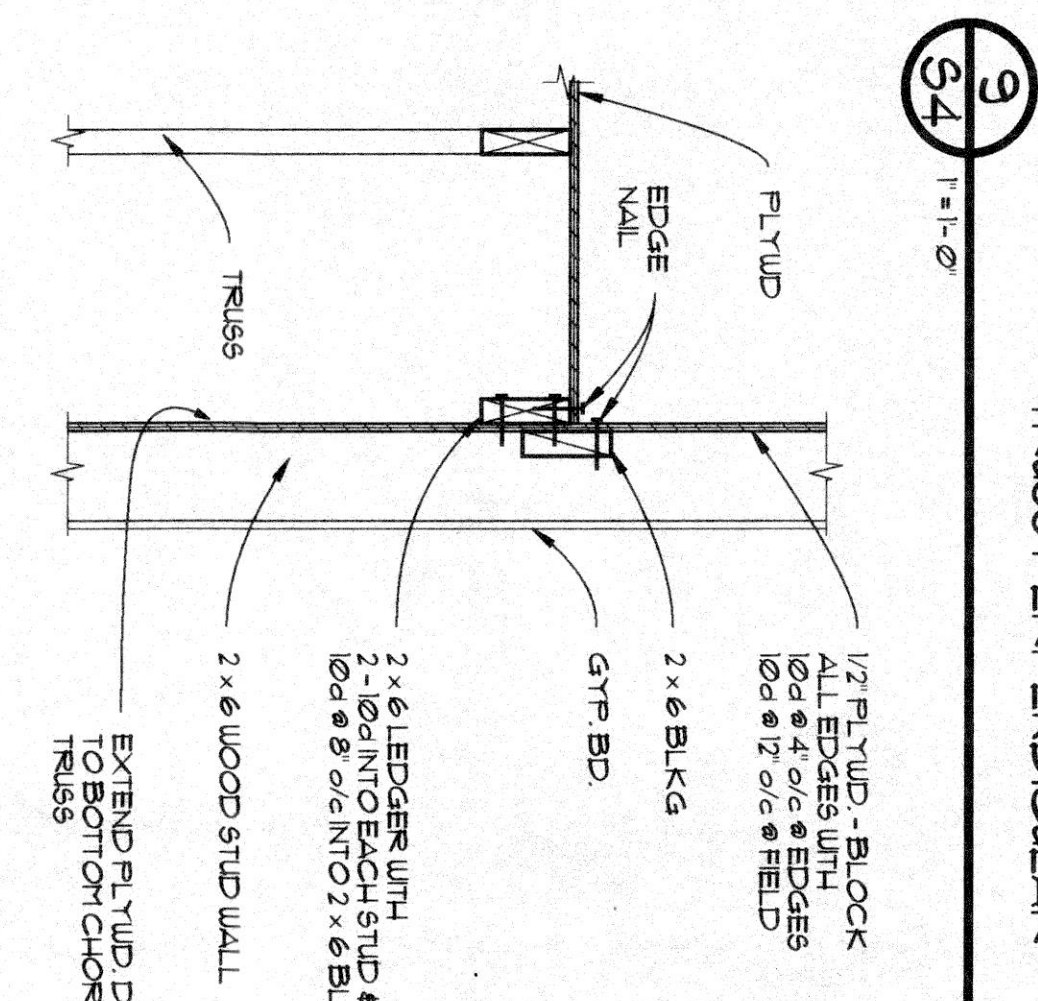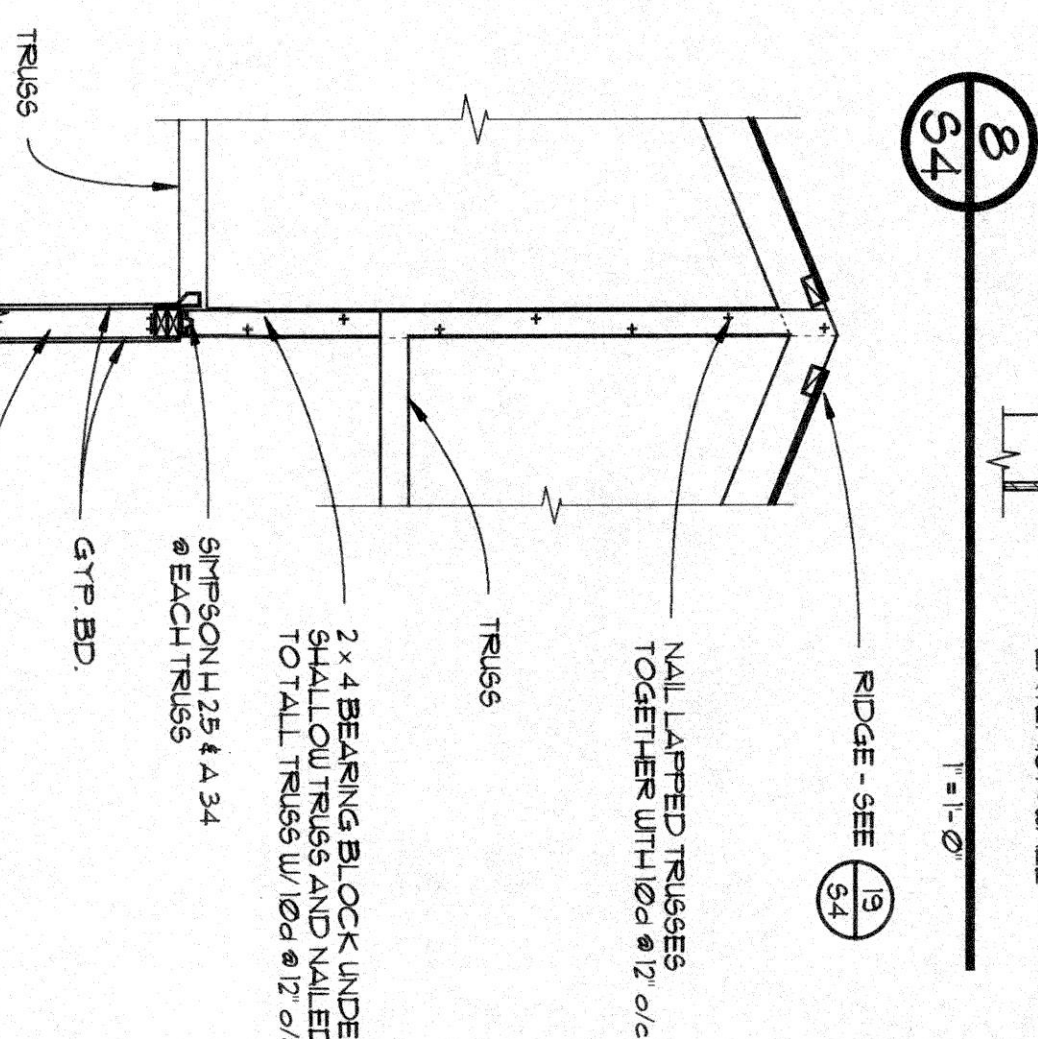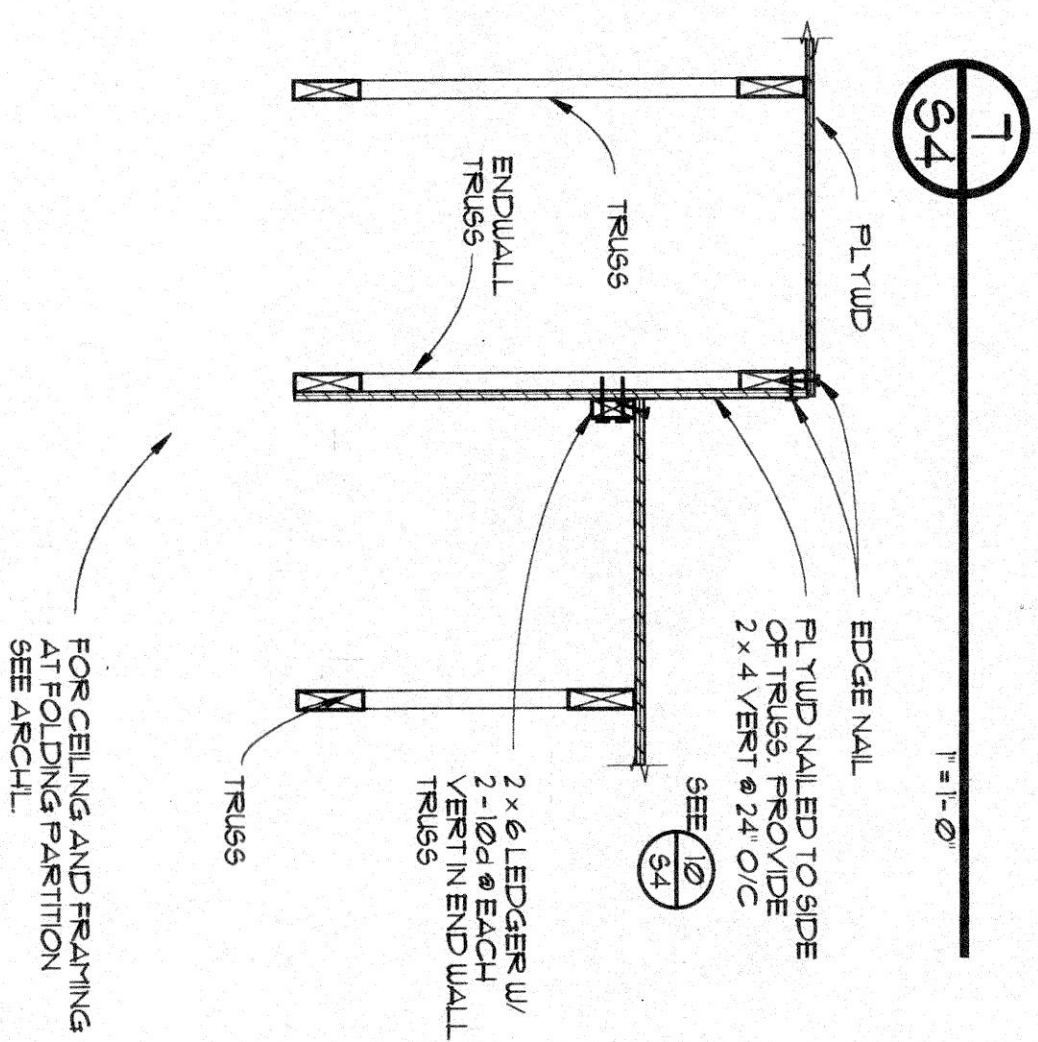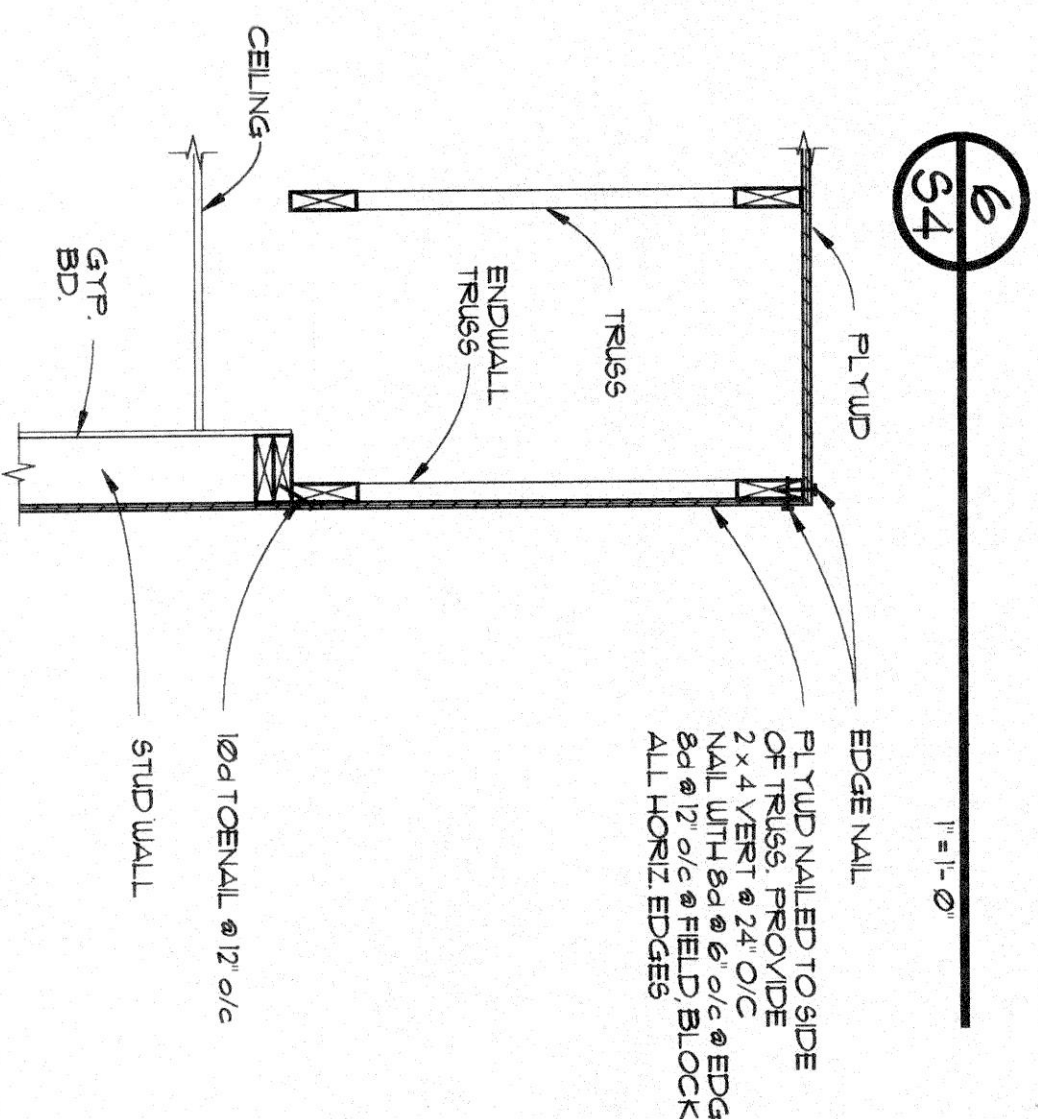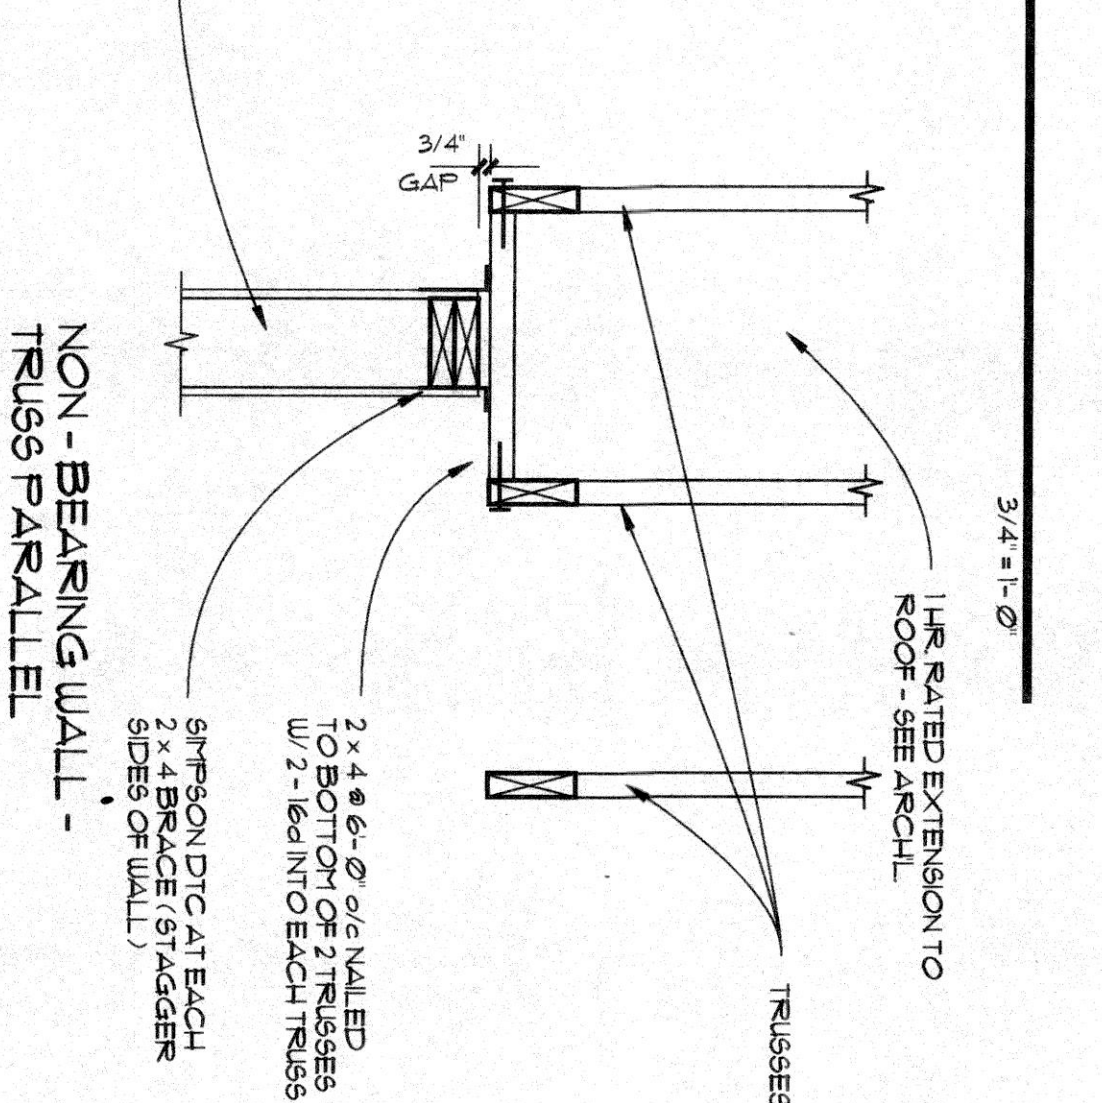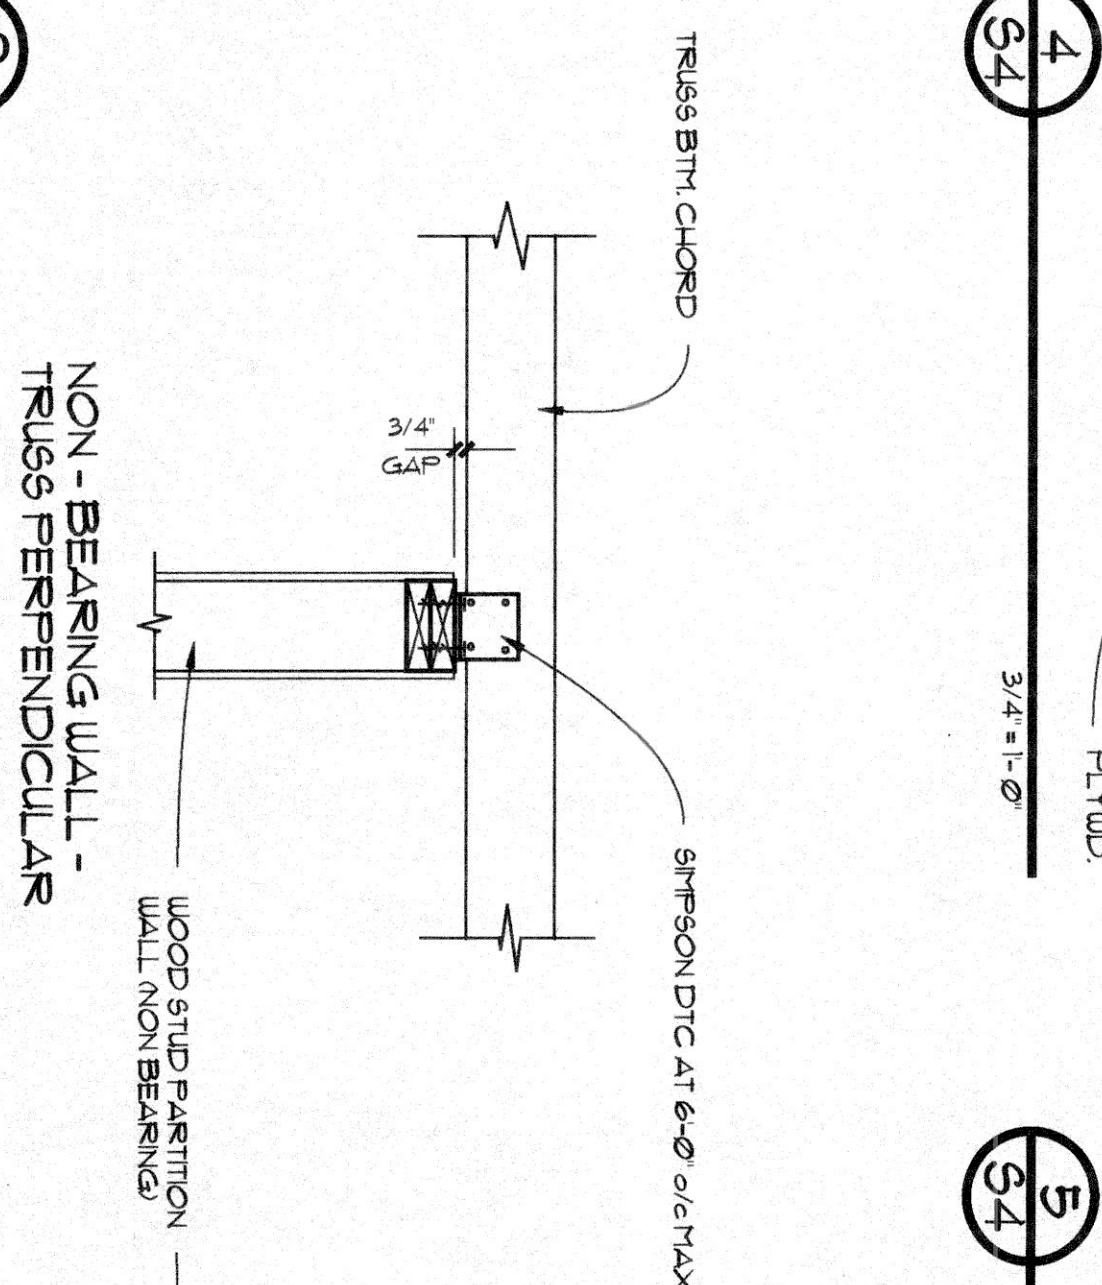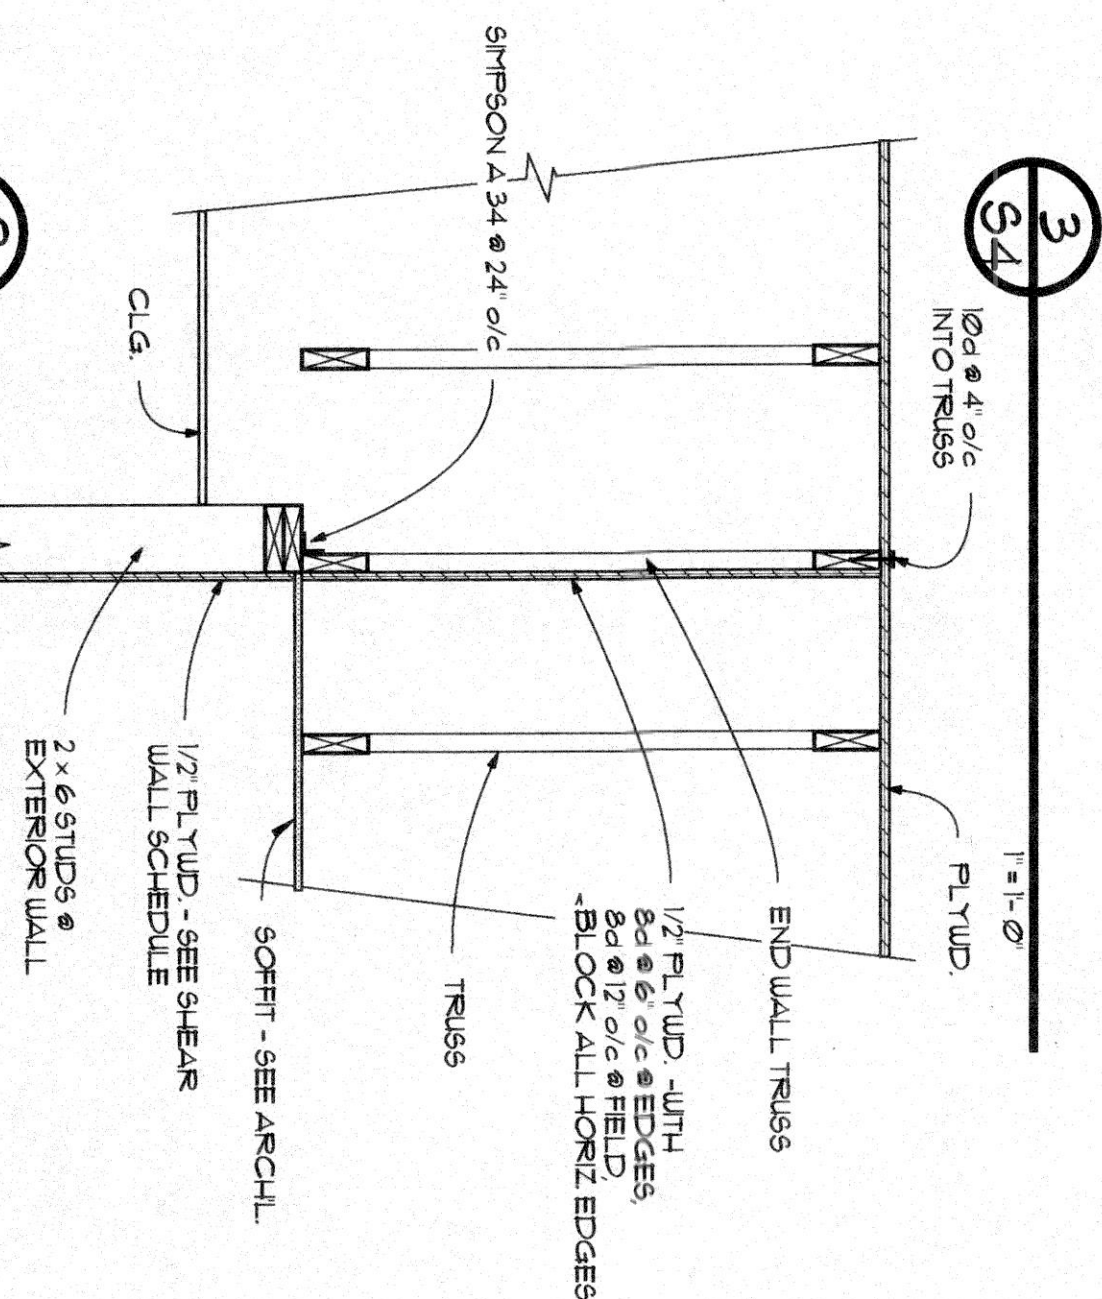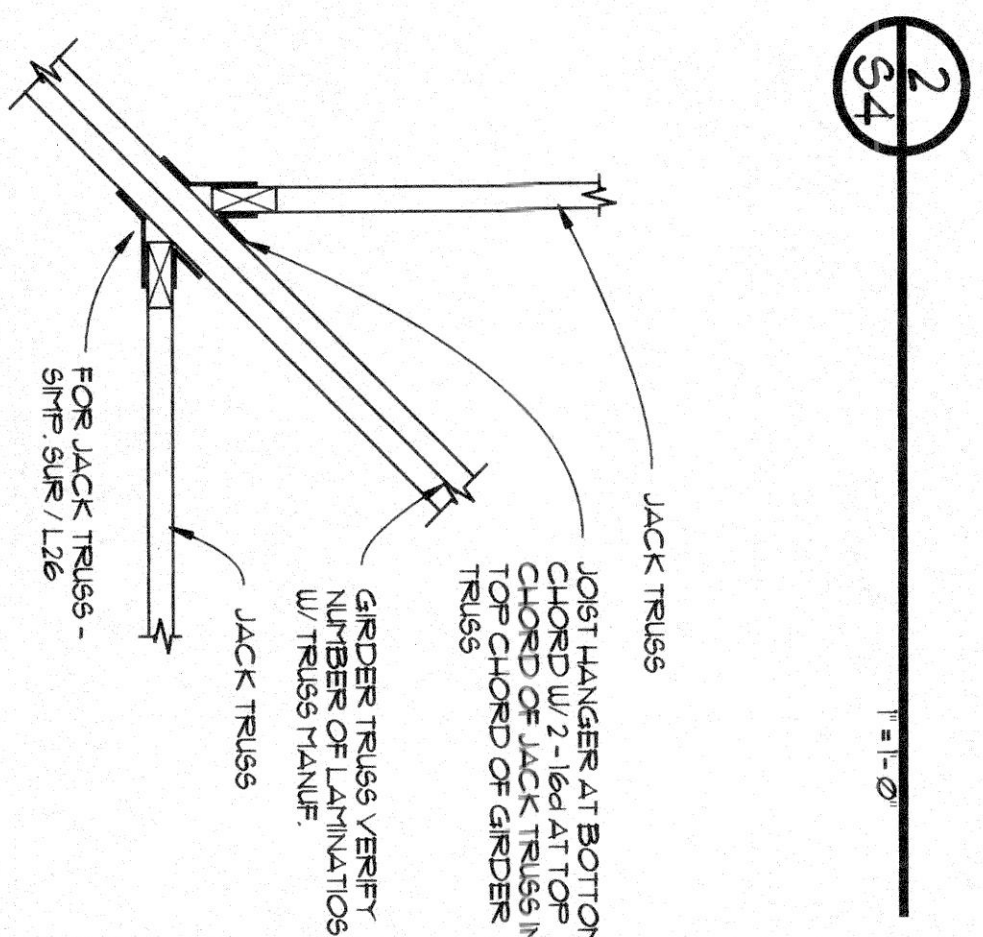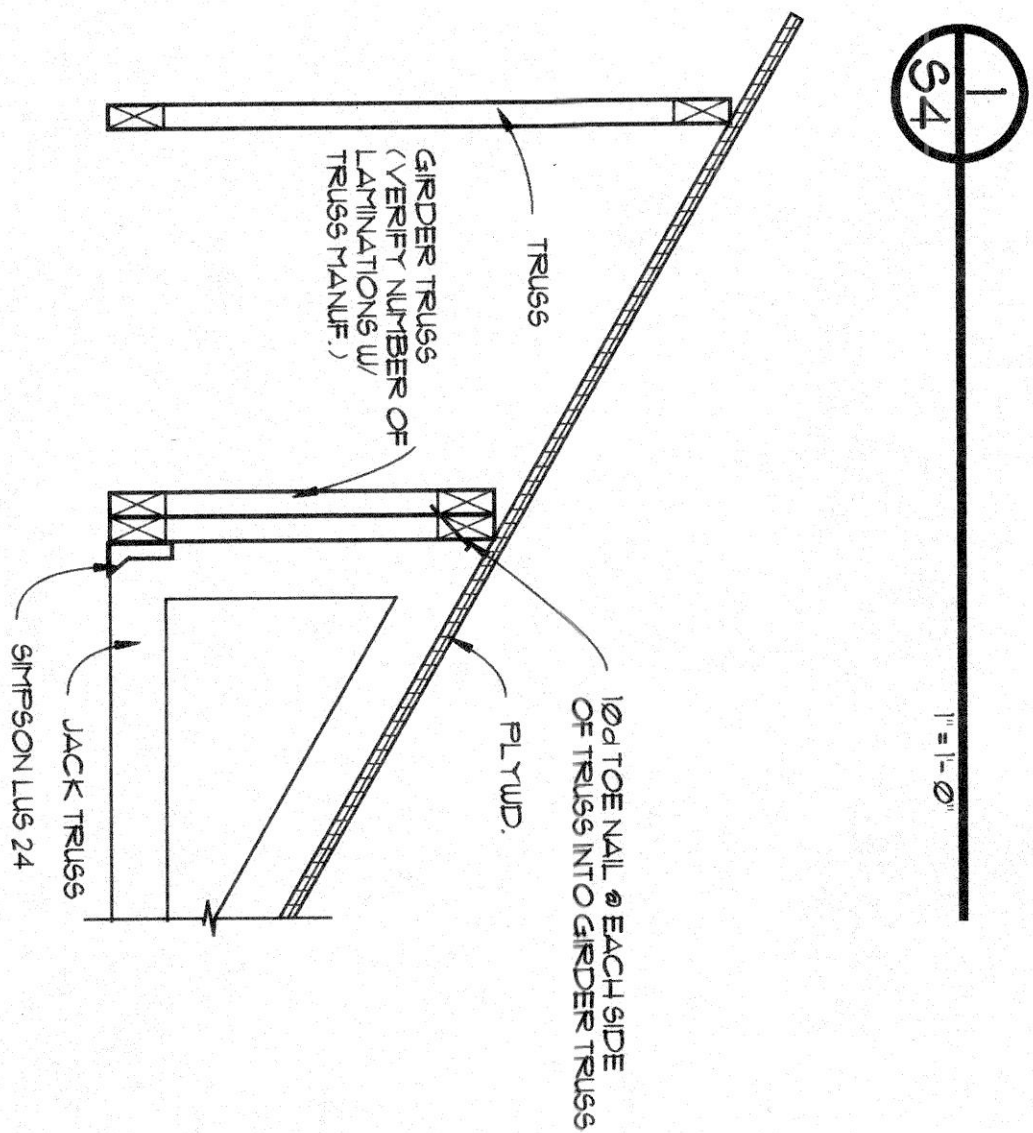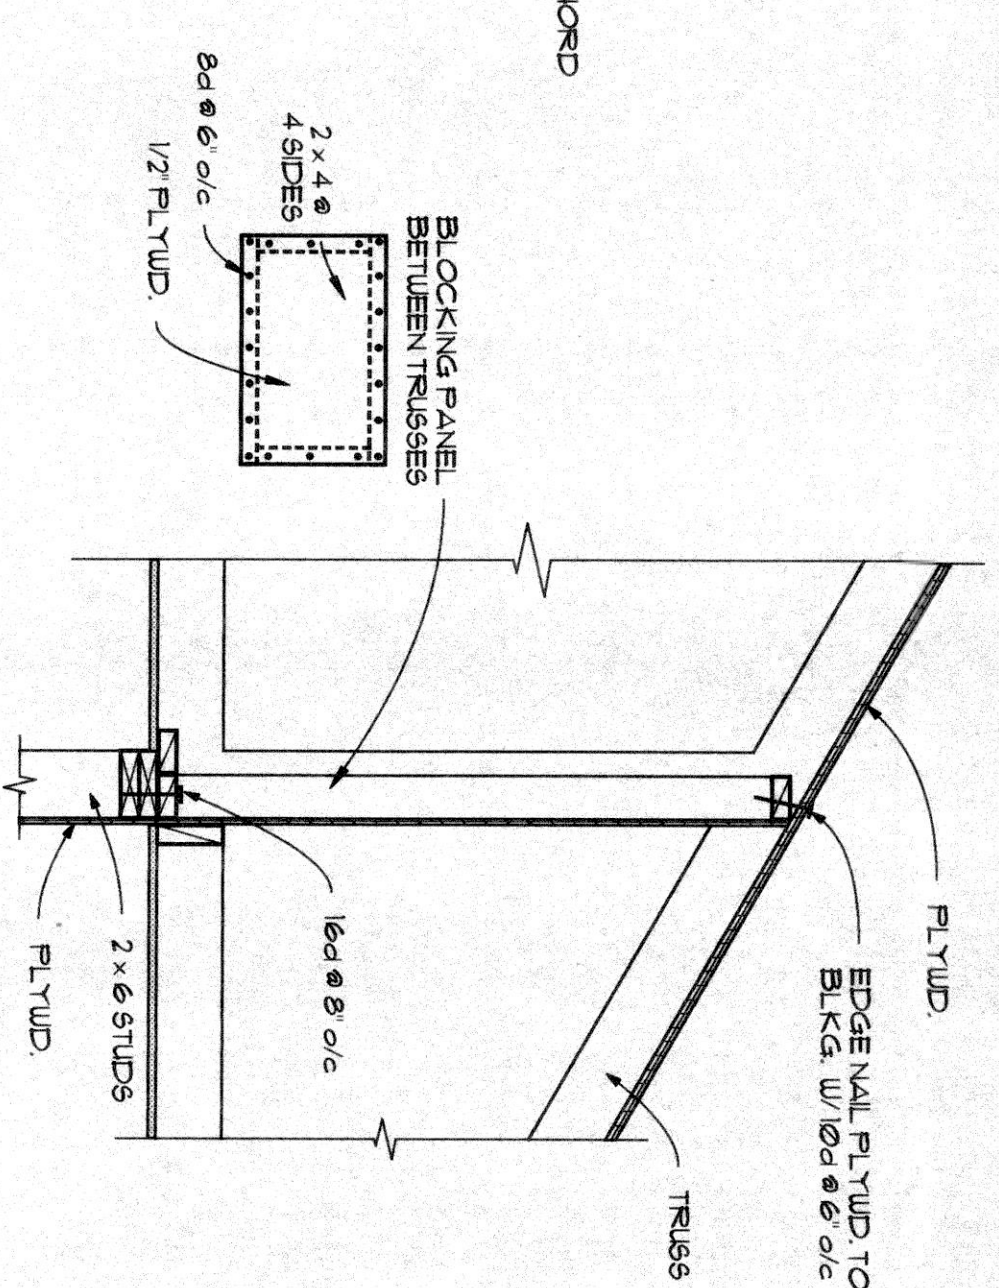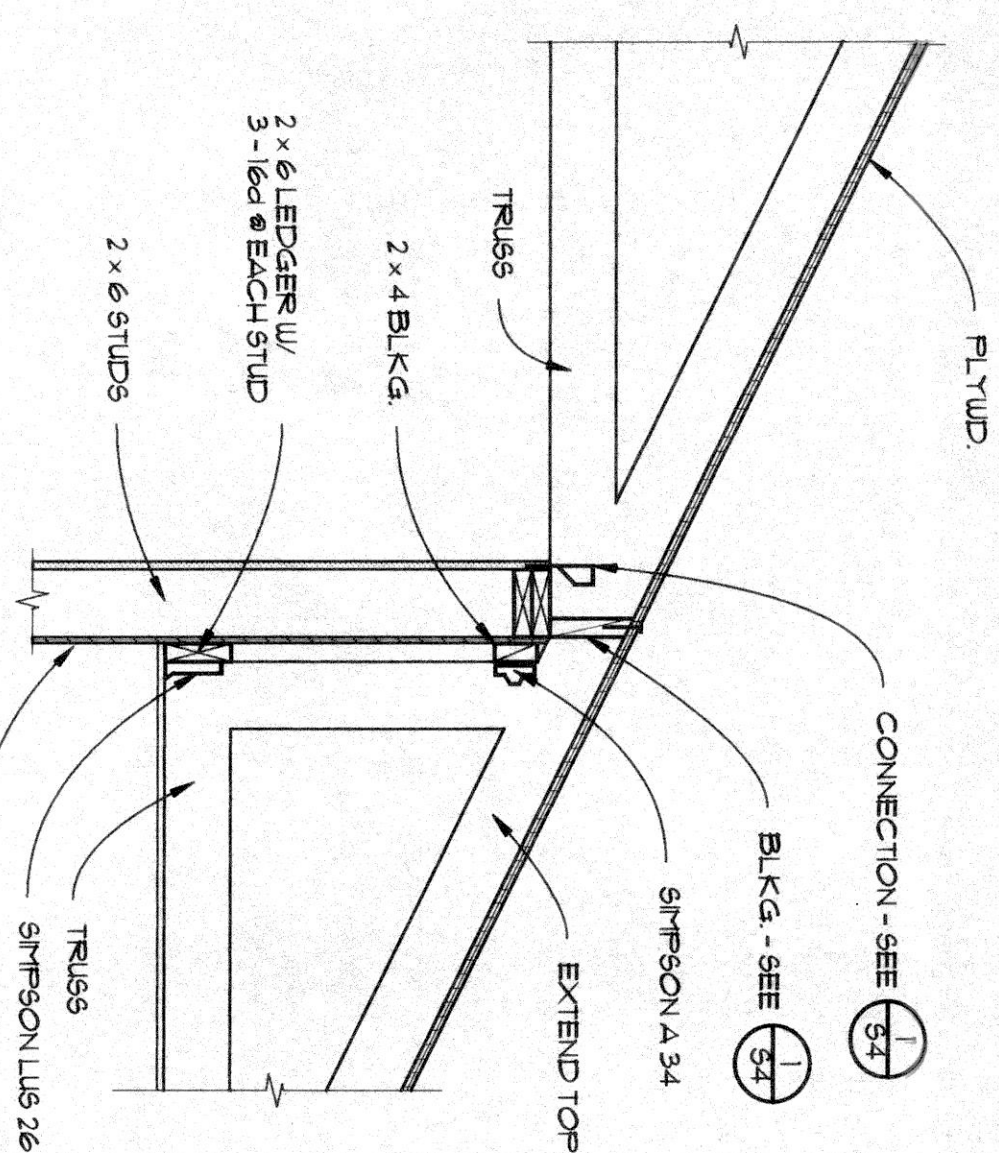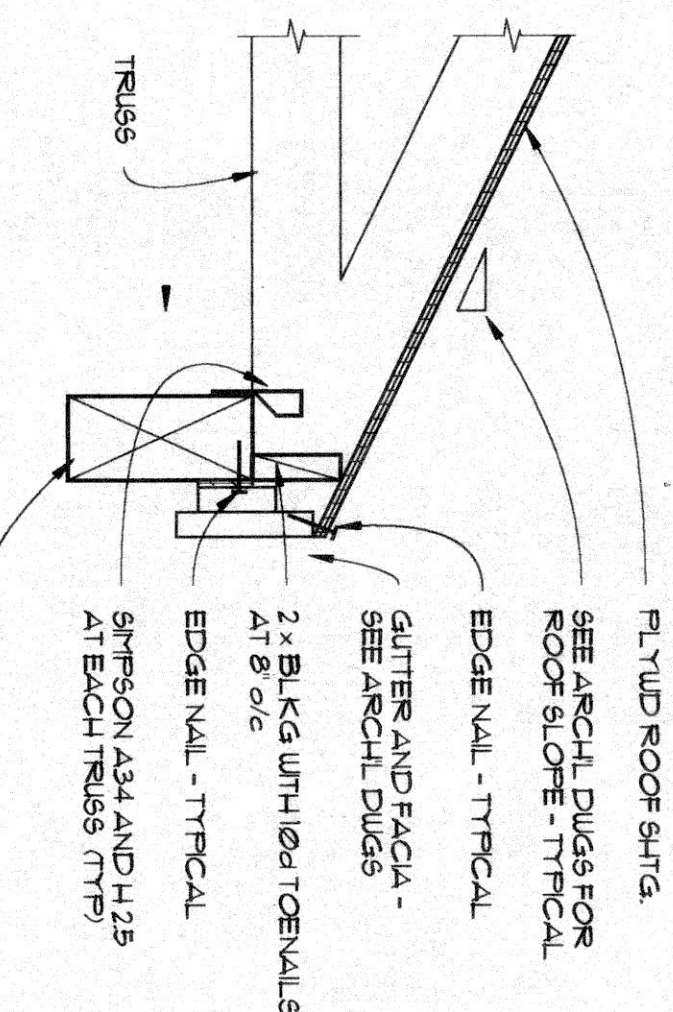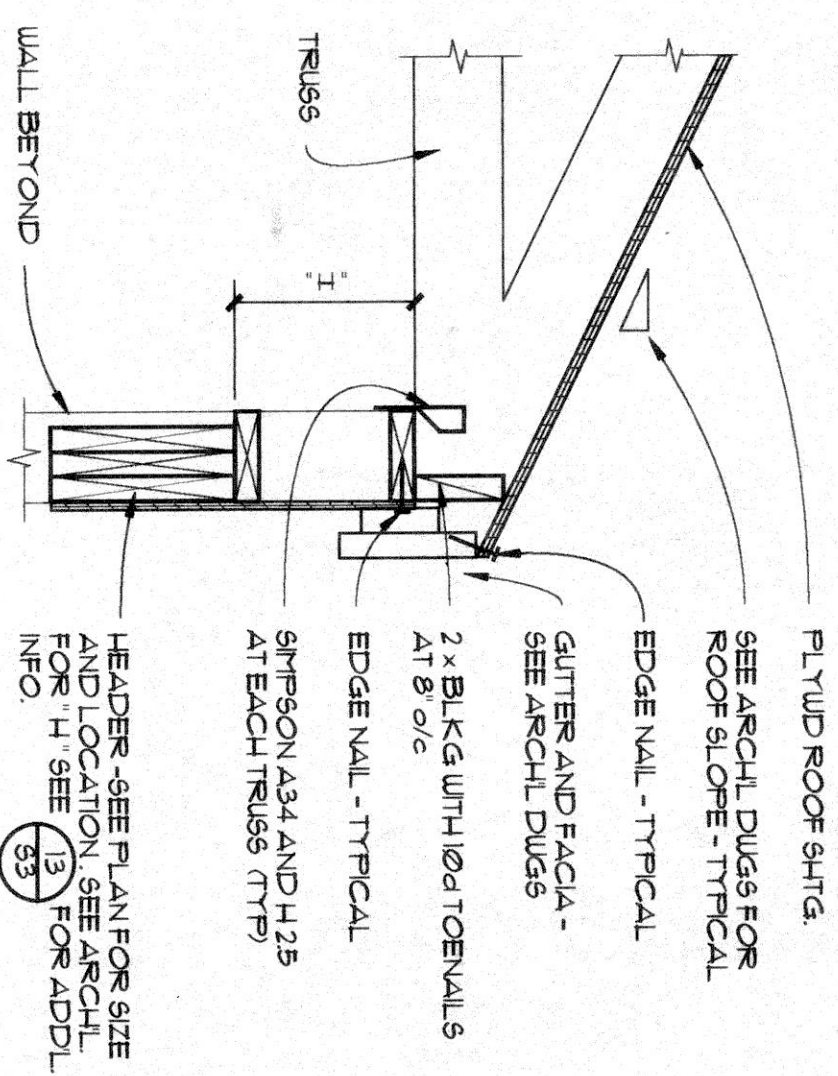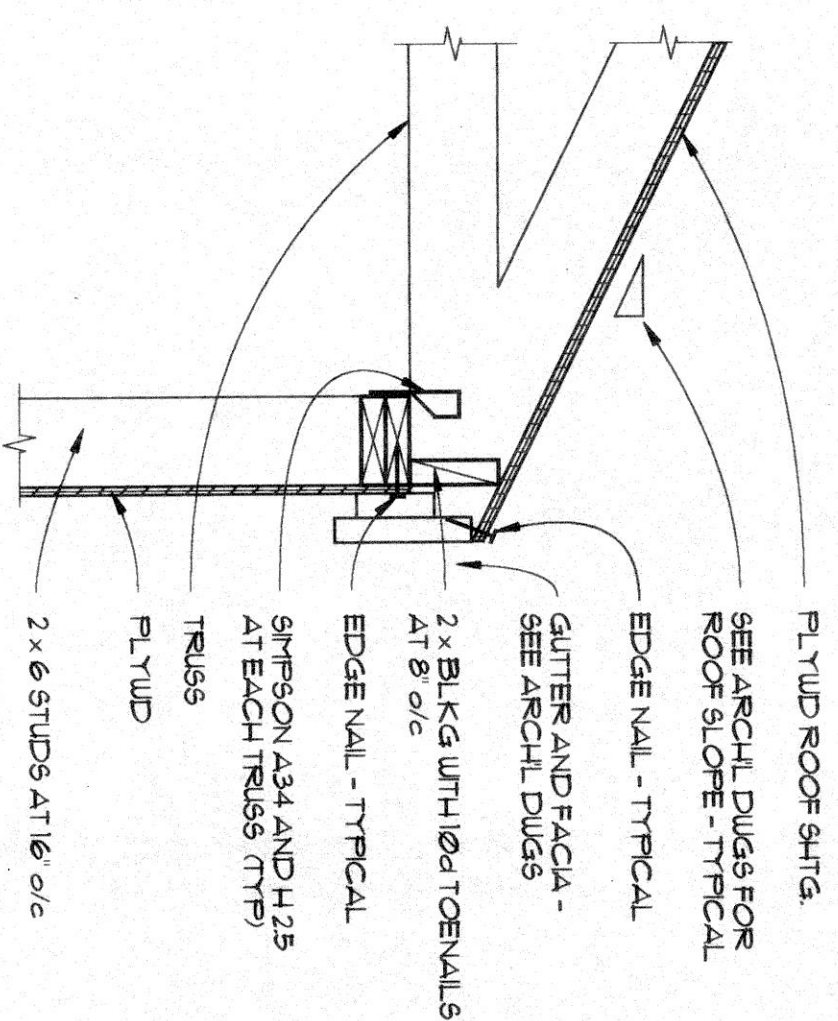

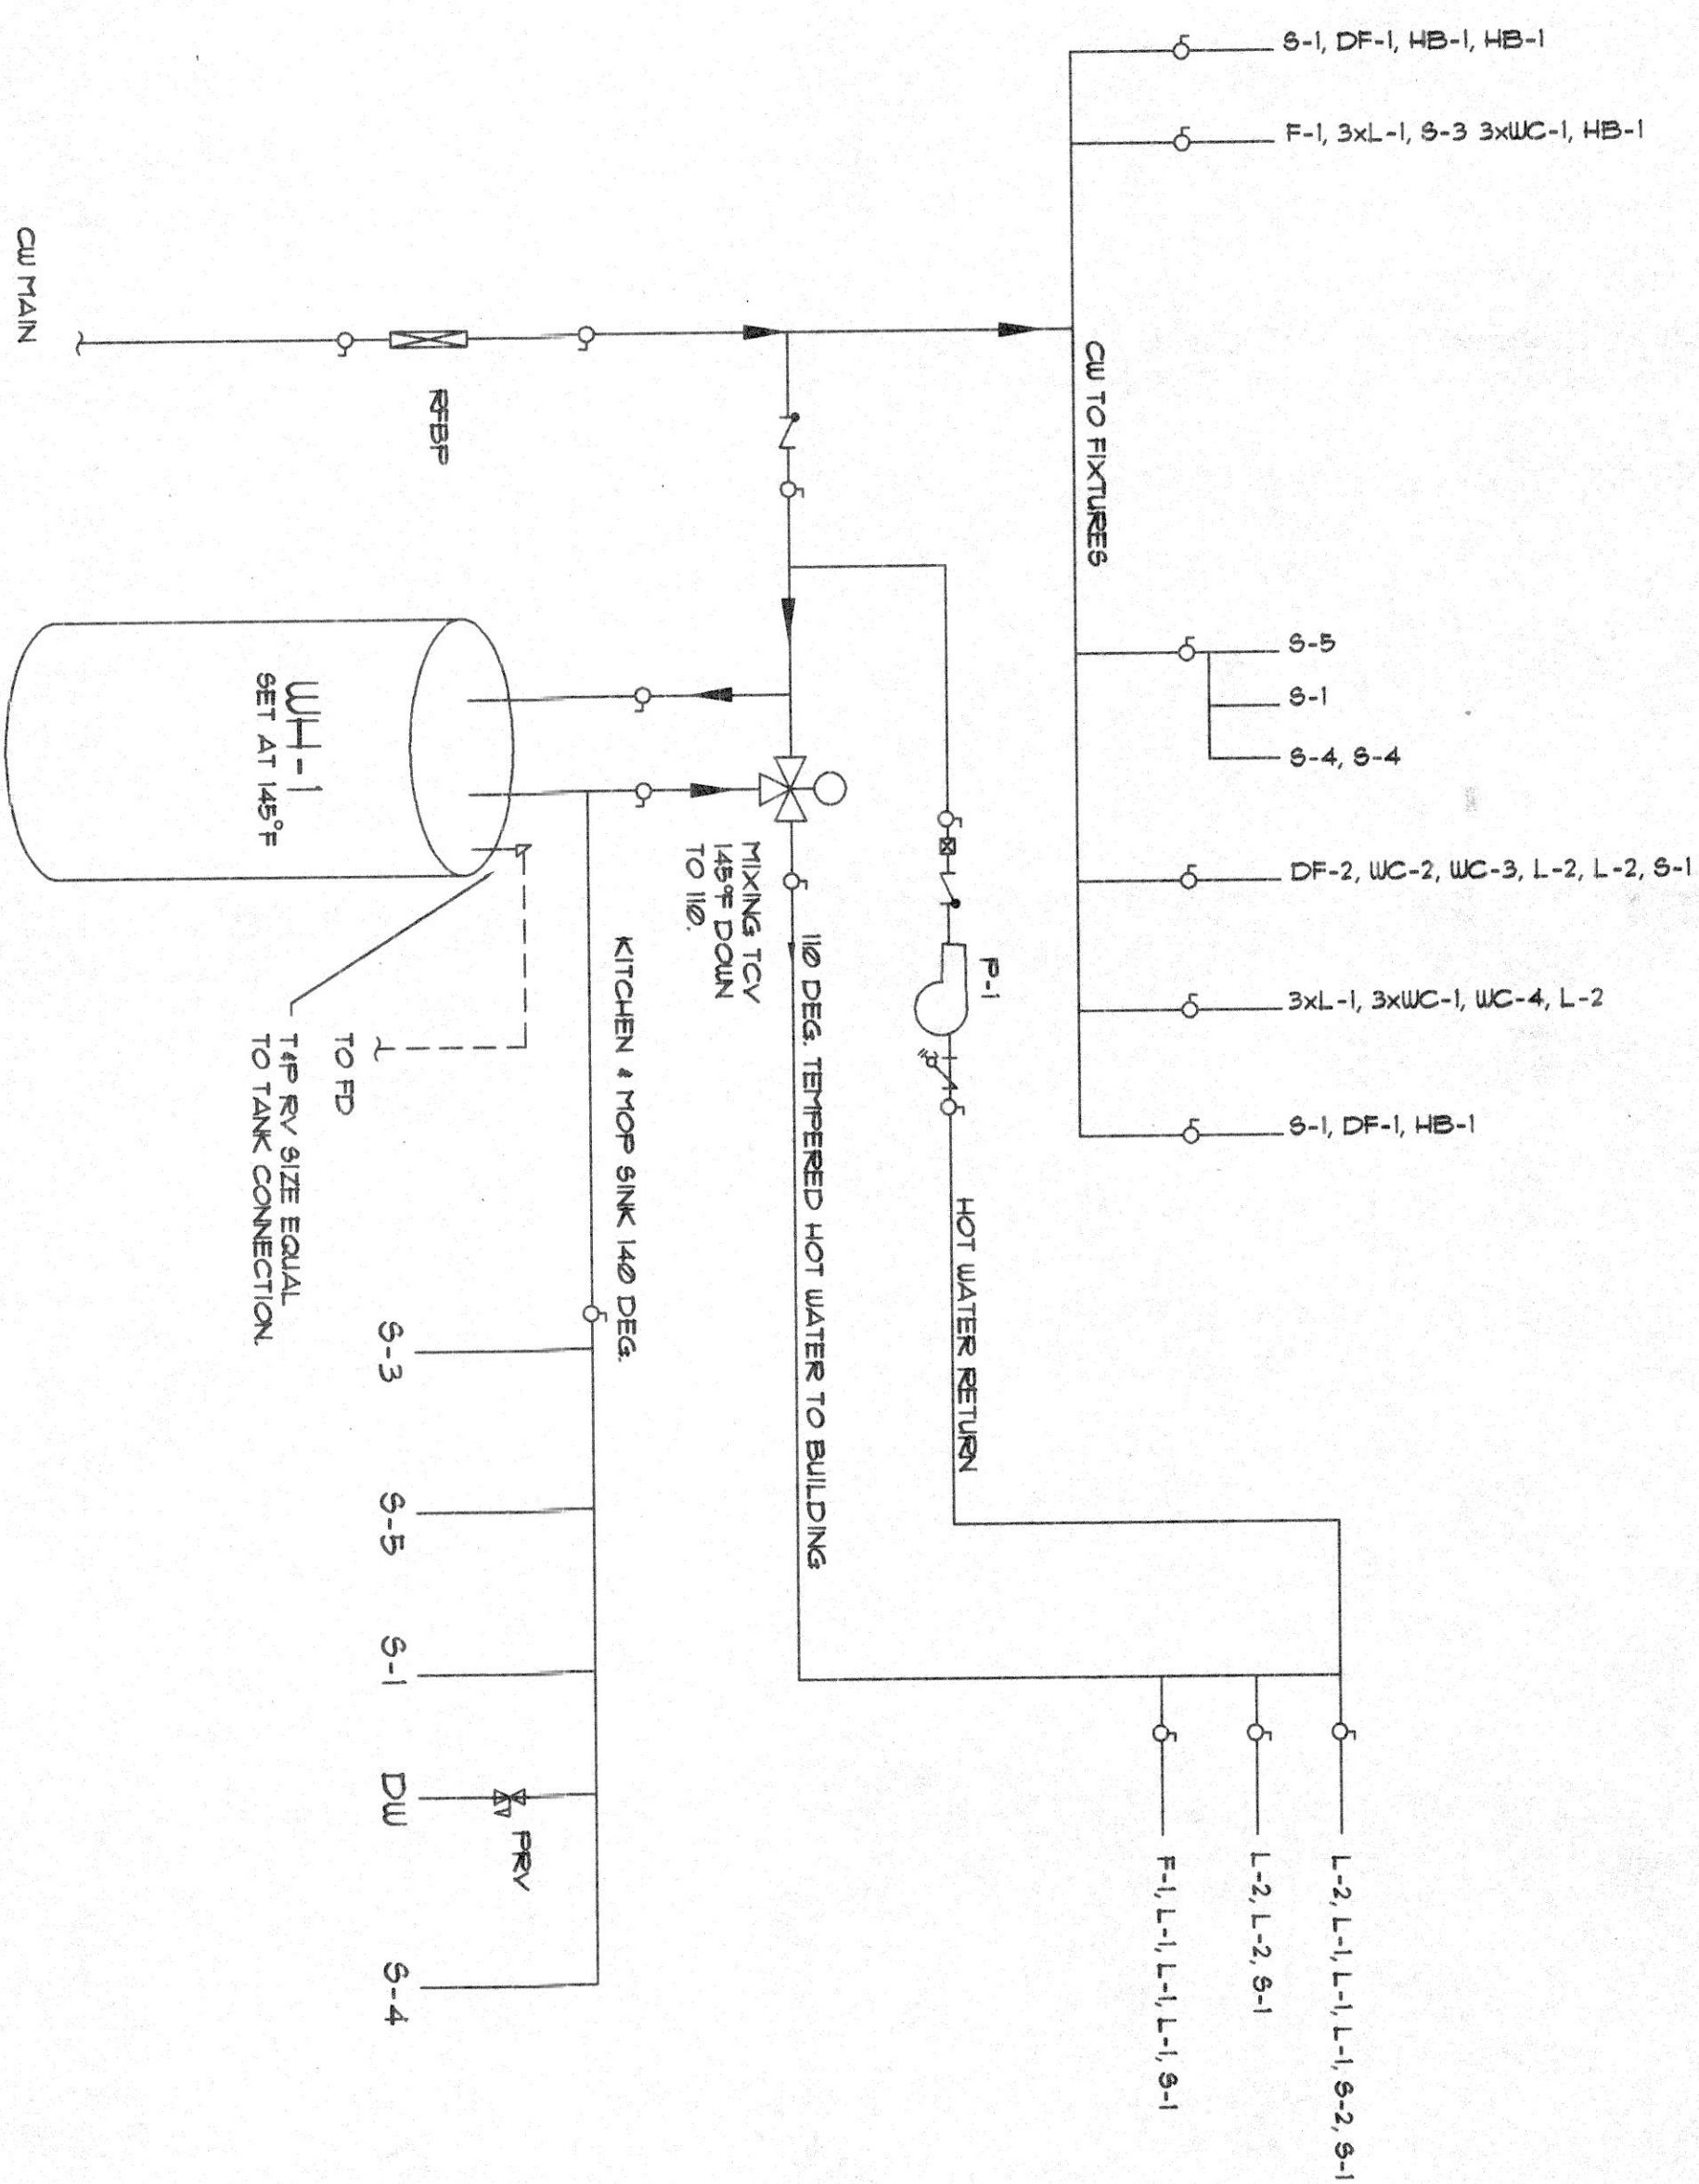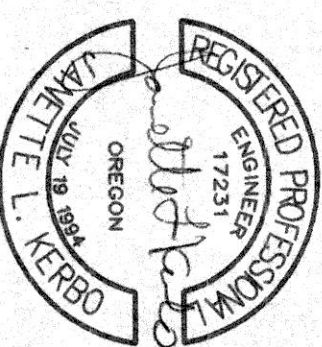

2	DOMESTIC WATER FLOW DIAGRAM
M-2	SCALE: NONE

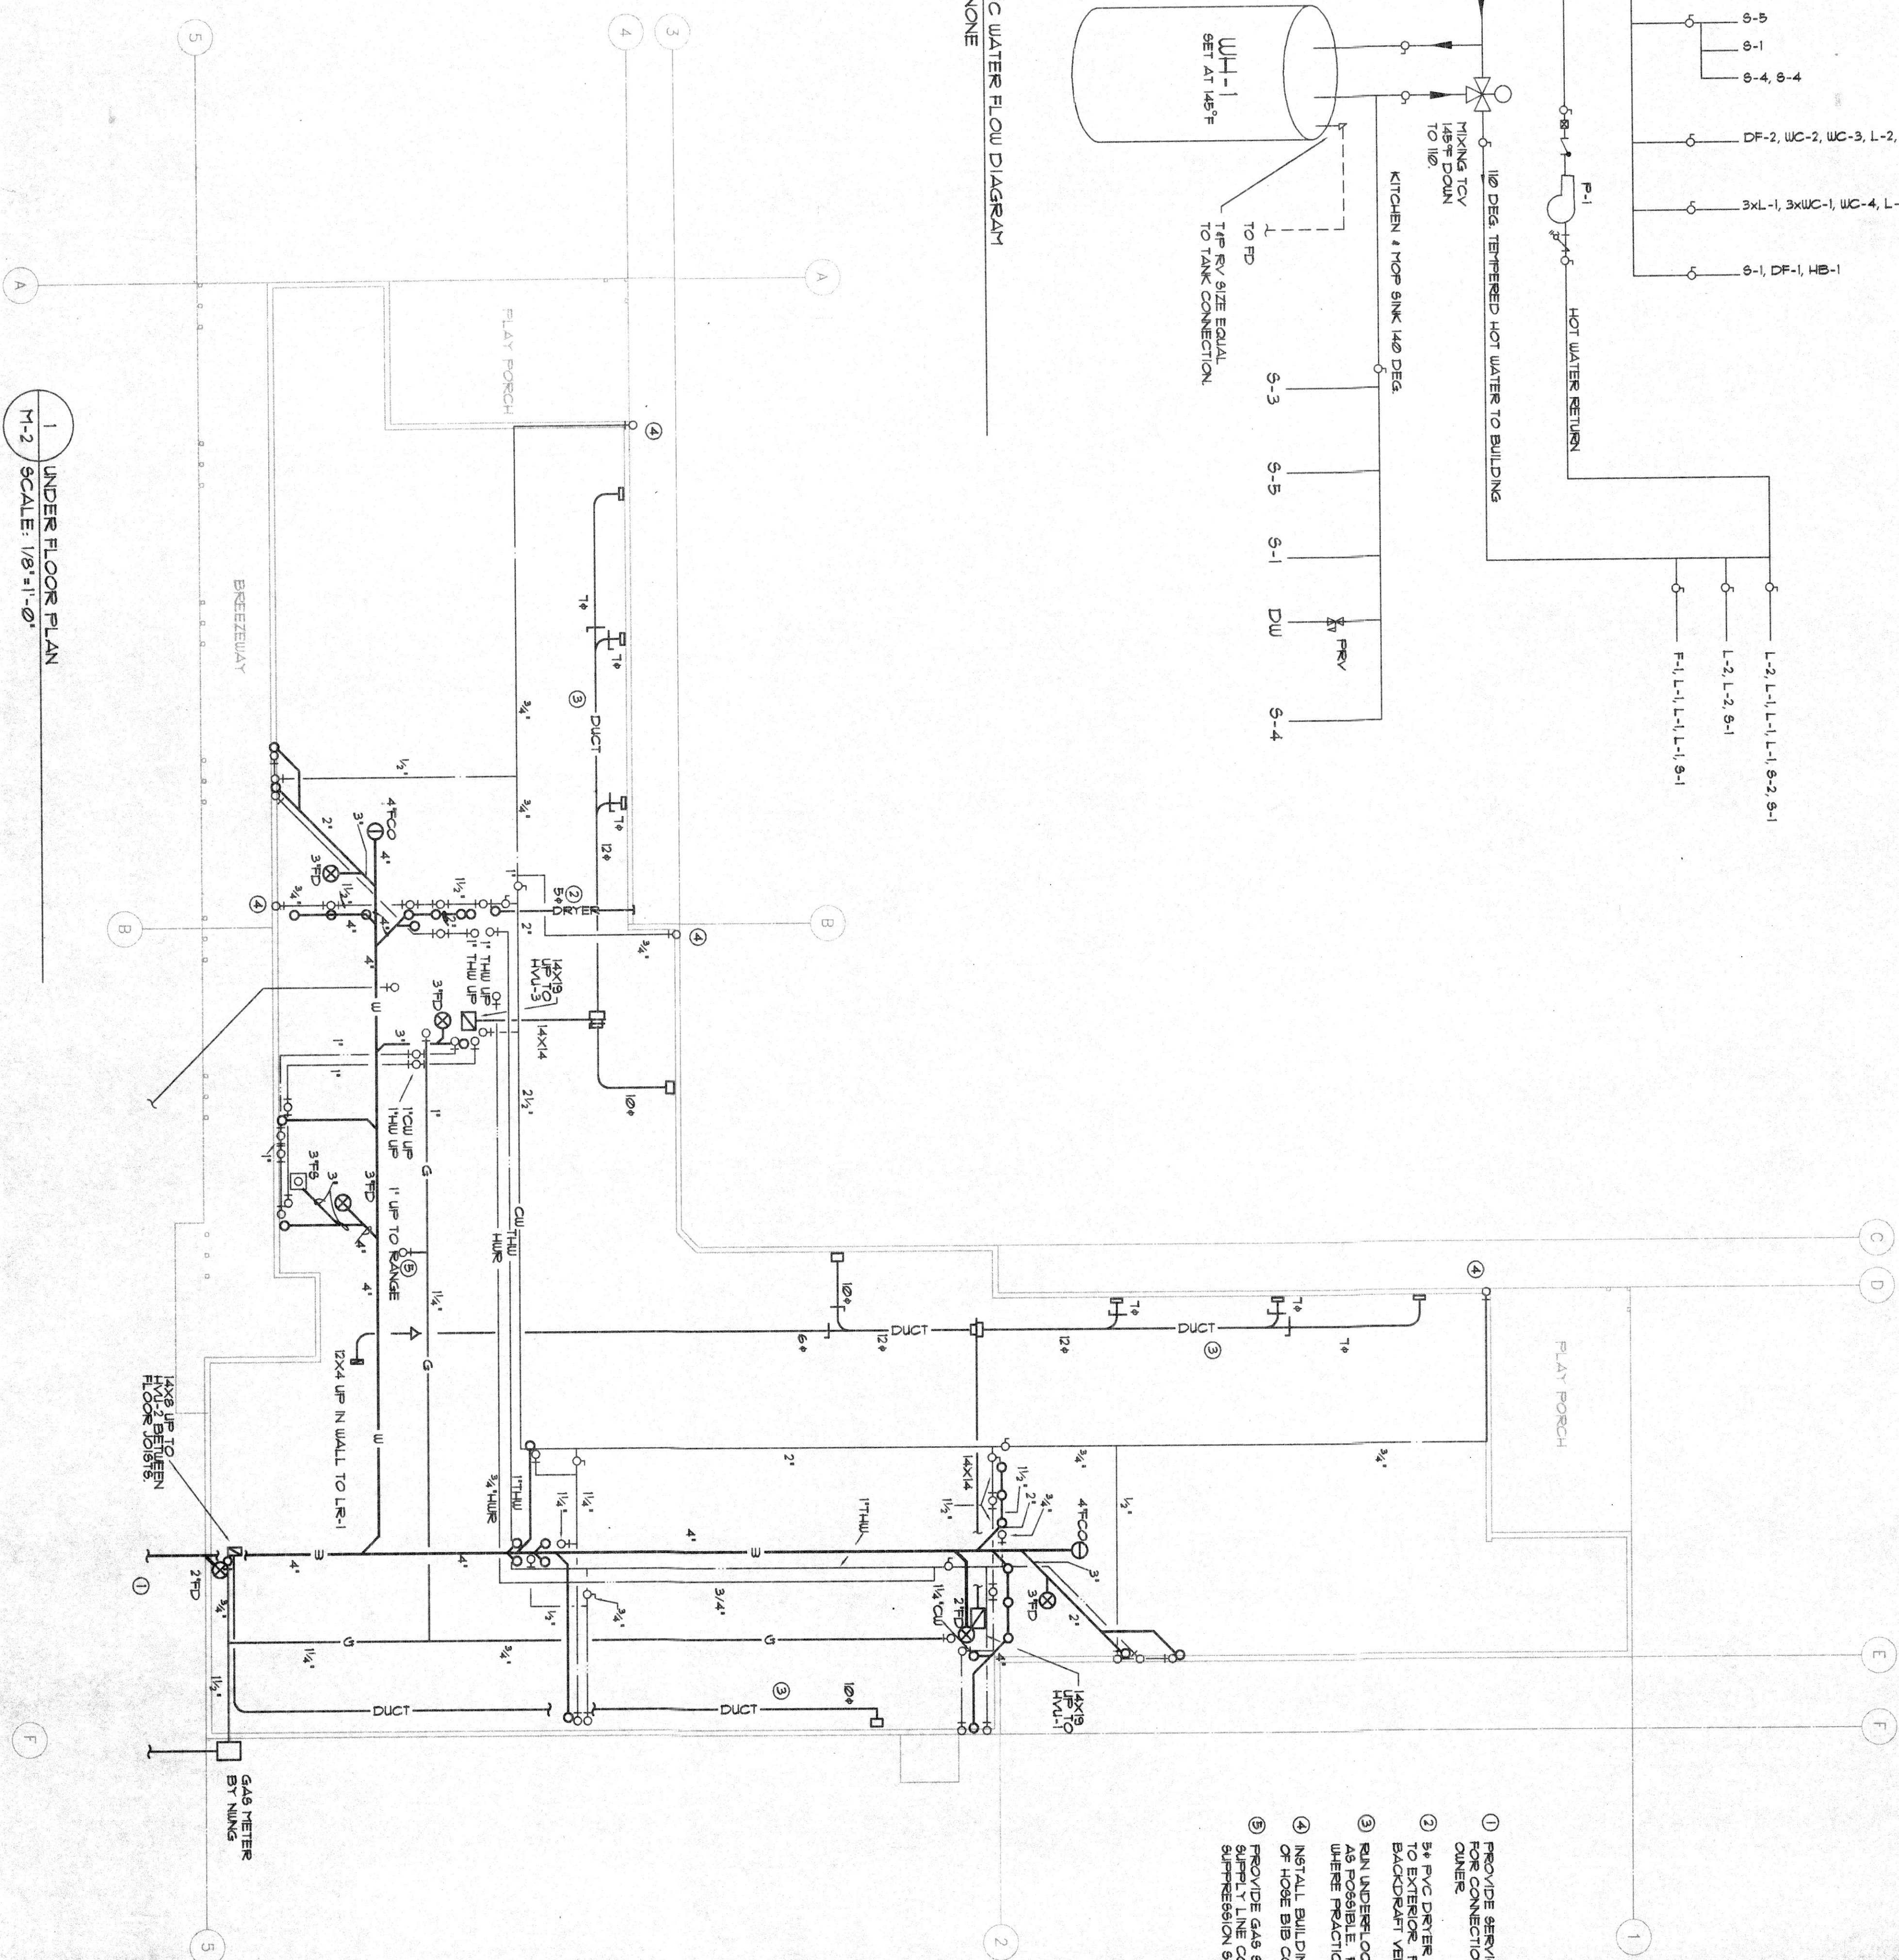

1
M-2 UNDER FLOOR PLAN
SCALE: 1/8" = 1'-0"

- ① PROVIDE SERVICE TO 5'-0" FROM BUILDING FOR CONNECTION TO PUBLIC UTILITIES BY CURBWER.
- ② 3" PVC DRAINER VENT TO EXTERIOR SILL, SLOPE TO DRAIN WATERWAY TO CURB AND RAINDRAIN VENT CAP AT EXTERIOR WALL.
- ③ RAN UNDERFLOOR DUCTWORK AS TIGHT TO STRUCTURE AS POSSIBLE. RAN IN SPACE BETWEEN JOISTS WHERE PRACTICAL.
- ④ INSTALL BUILDING INSULATION ON EXTERIOR SIDE OF HOUSE BIB CONNECTIONS TO REDUCE FREEZING.
- ⑤ PROVIDE GAS SOLEILMENT VALVE ON RANGE GAS SUPPLY LINE CONNECTED TO KITCHEN HOOD FRESH SUPPLESSATION SYSTEM.

**CHRIS
BILINGS &
ASSOCIATES
CONSULTING ENGINEERS**

4445 S.W. BARBUR BLVD
PORTLAND, OR 97201

PH. (603) 228-0008
FAX (603) 228-2280


HEAD START
CENTER

WARRENTON/ASTORIA


PROJECT NO. :	95-0030
FILE NO. :	HS-M-2.dwg
DATE :	JUNE 1, 1995
REVISIONS :	
	DATE :
	DESCRIPTION

SHEET TITLE:
FOUNDATION PLAN
MECHANICAL

N-2

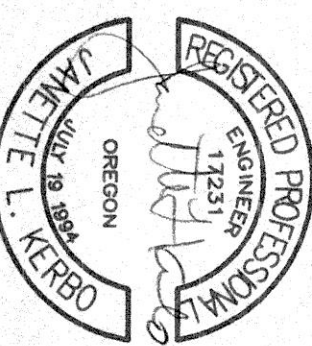


EXPIRES 6/30/95

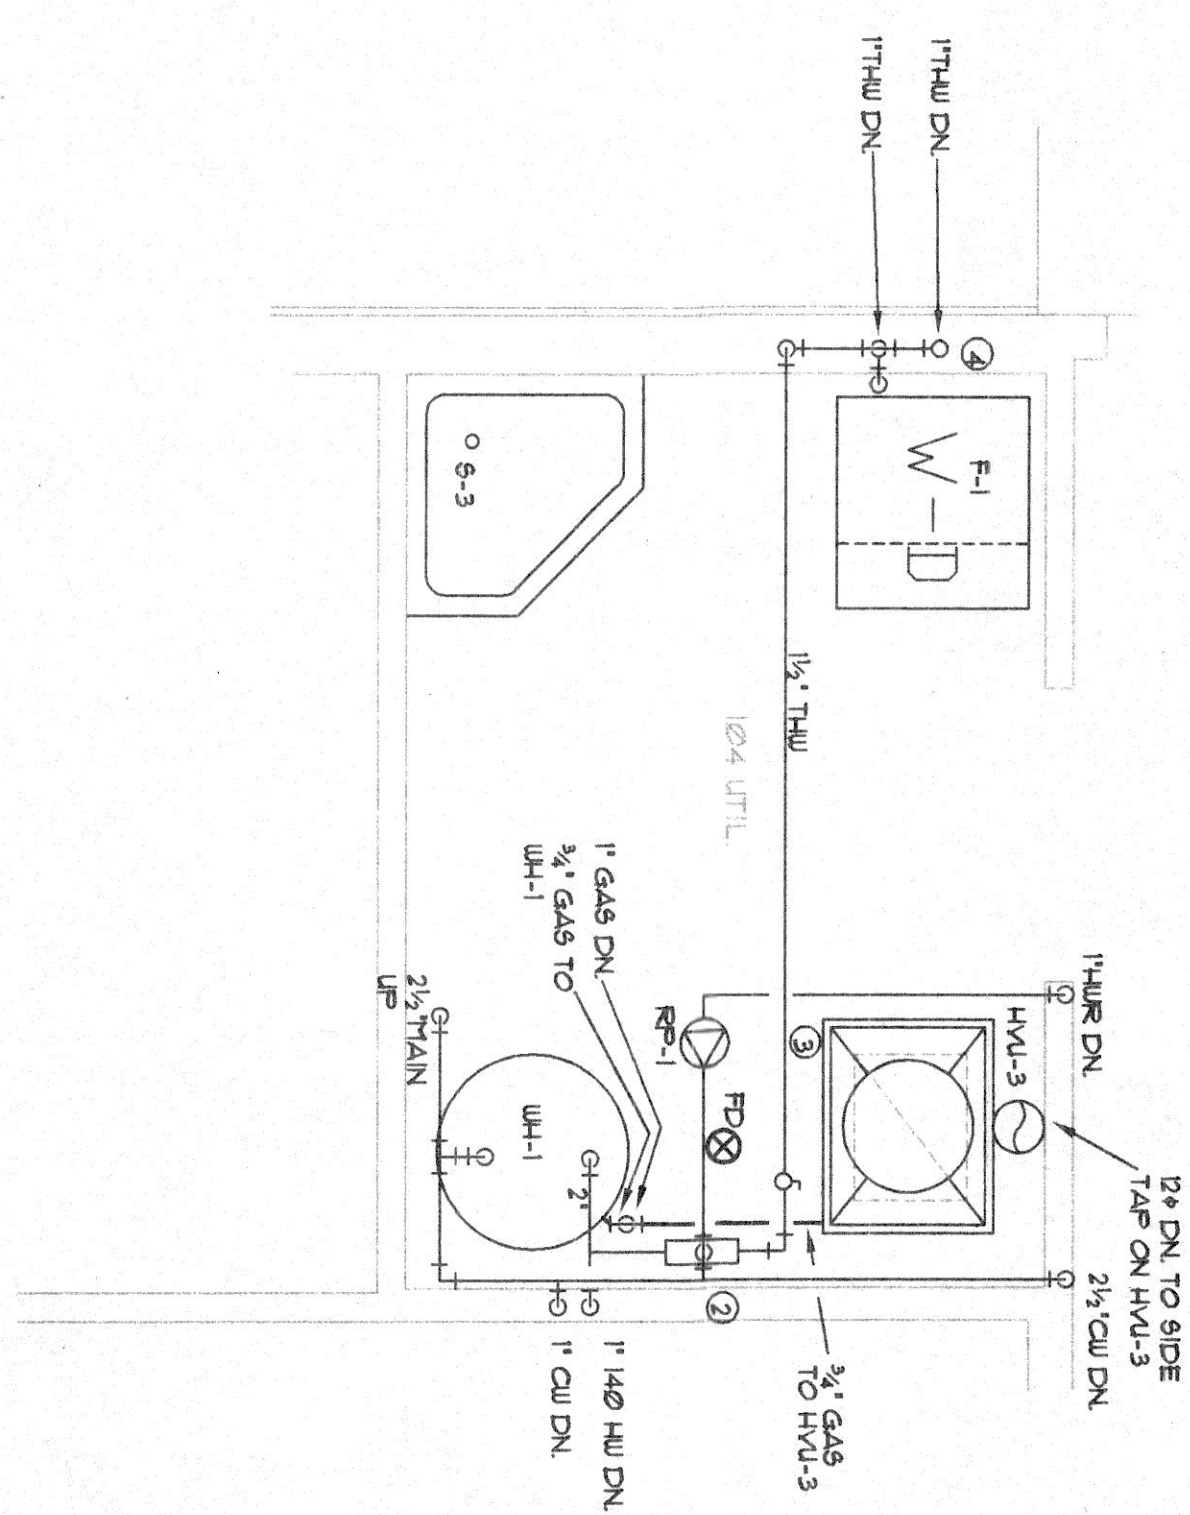

- ① MOUNT THIS FIXTURE AT CHILD HEIGHT WITH BOTTOM OF FOUNTAIN AT 24" AFF. SEE ARCHITECTURAL DRAWINGS.
- ② THERMED WATER HEATING VALVE MOUNTED ON WALL. SET TO DELIVER 100°F.
- ③ PIPE CD TO RD.
- ④ PROVIDE RECESSED DRYER VENT BOX W/ CONNECTIONS DN TO 5% P.V.C.

2	UTILITY ROOM DETAIL
M-3	SCALE: 1/2"=1'-0"

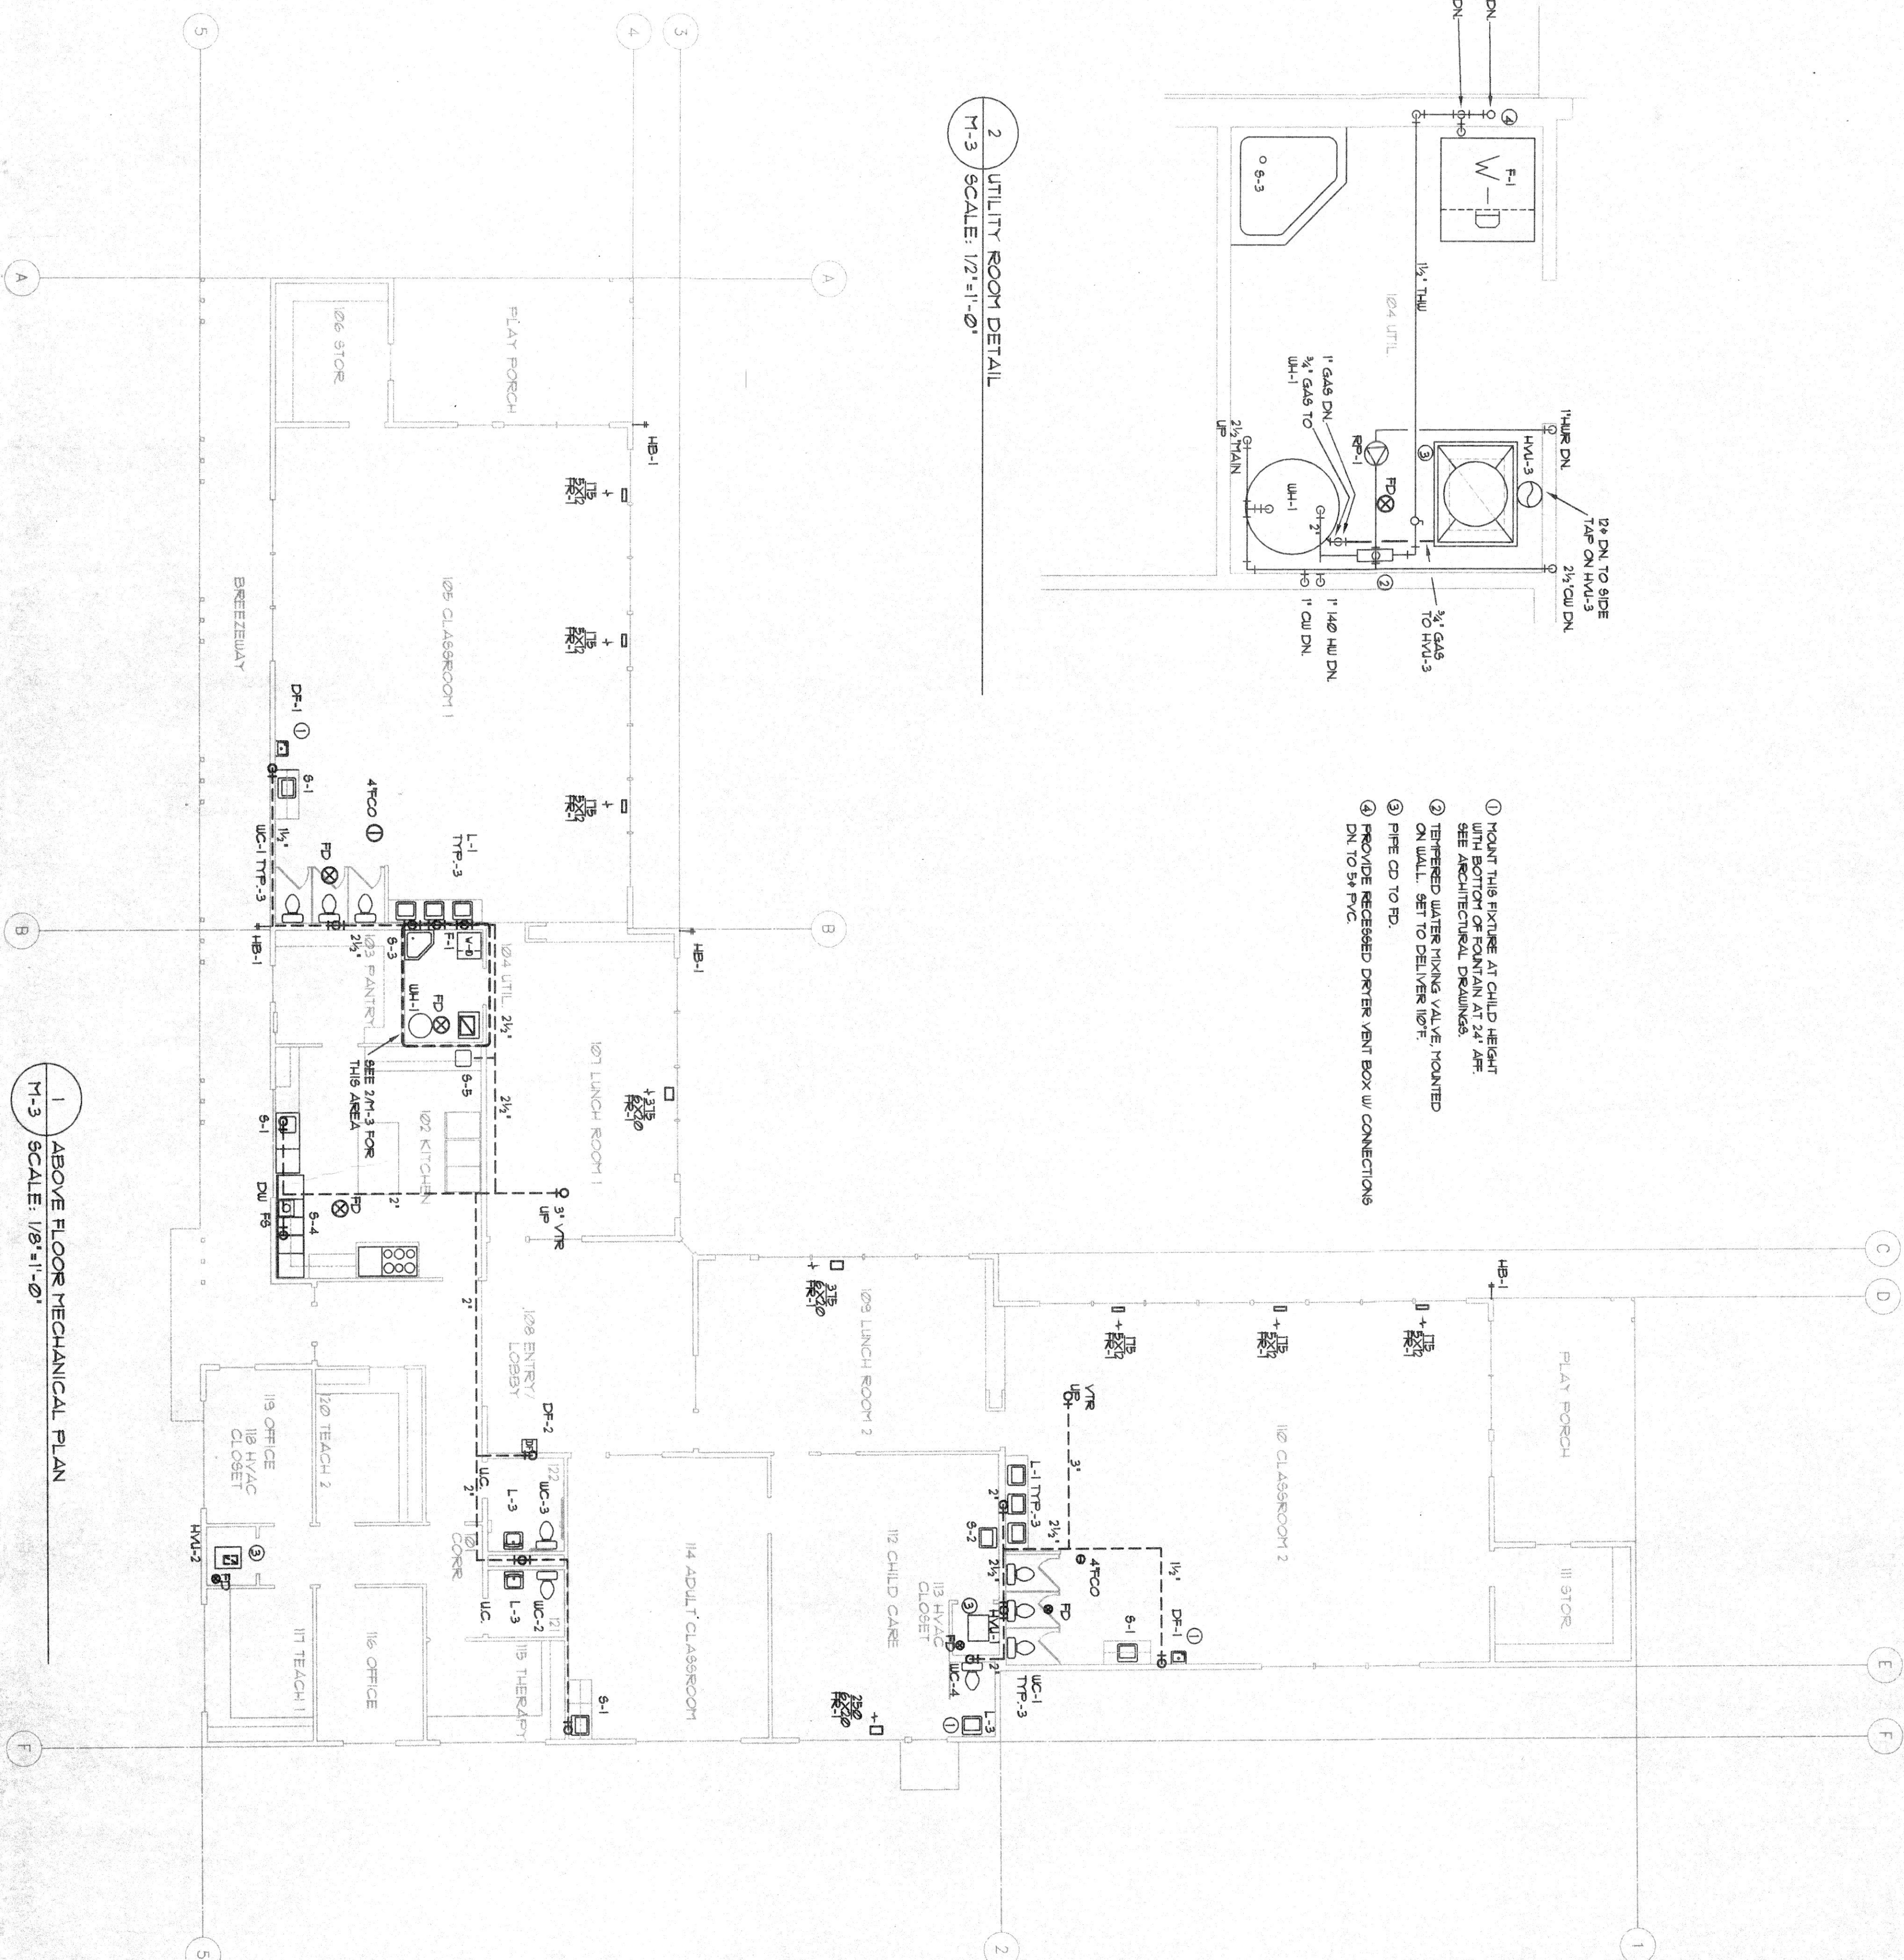

1	ABOVE FLOOR MECHANICAL PLAN
M-3	SCALE: 1/8" = 1'-0"

**CHRIS
BILINGS &
ASSOCIATES**
CONSULTING ENGINEERS

4445 S.W. BARBUR BLVD
PORTLAND, OR 97201

PH. (503) 228-0008
FAX (503) 228-2250


HEAD START
CENTER

WARRENTON/ASTORIA

PROJECT NO. ,	95-0030
FILE NO. ,	HS-M-2.dwg
DATE ,	JUNE 1, 1995
REVISIONS ,	DATE , DESCRIPTION


SHEET TITLE ,
FLOOR PLAN
MECHANICAL
SCALE: 1/8"=1'-0"
SHEET NO. ,
M-3

GENERAL NOTE:
EXHAUST FAN HANG FROM STRUCTURE
IN ATTIC. POSITION SO THAT SINGLE CEILING
TILE PROVIDES ADEQUATE MAINTENANCE
ACCESS. PROVIDE FLEX CONNECTIONS TO DUCTS
AND SEISMIC RESTRAINTS.
UP TO REDUCING LATERAL.

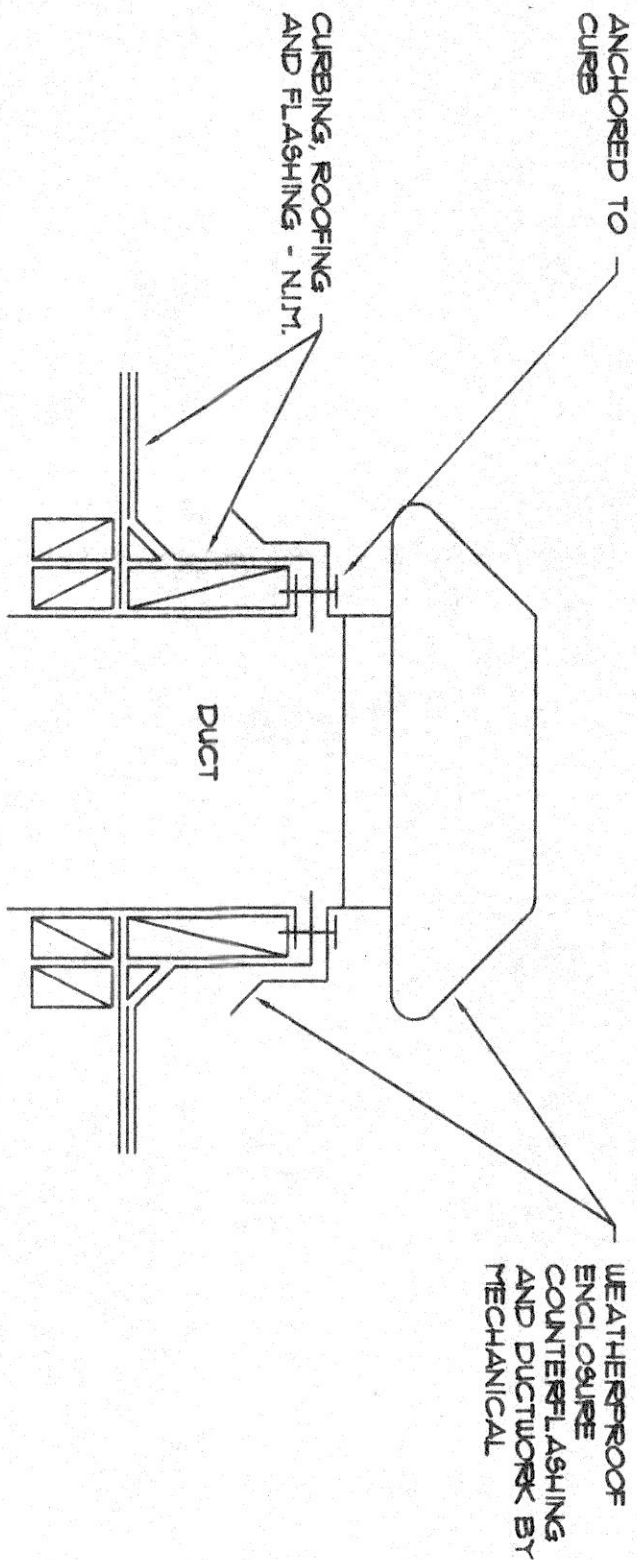

DETAIL - ROOF CAP
NO SCALE

- NOTES
- 1 EXHAUST FAN HANG FROM STRUCTURE IN ATTIC. POSITION SO THAT SINGLE CEILING TILE PROVIDES ADEQUATE MAINTENANCE ACCESS. PROVIDE FLEX CONNECTIONS TO DUCTS AND SEISMIC RESTRAINTS. UP TO REDUCING LATERAL.
 - 2 RECTANGULAR TRANSITION TO 16"
 - 3 VENT HVL THROUGH WALL WITH CONCENTRIC VENT KIT. LOCATE EXTERIOR TERMINATION AS HIGH AS PRACTICAL.
 - 4 PROVIDE RECESSED DRYER VENT BOX WITH CONNECTION TO 54" PVC DOWN IN WALL.
 - 5 64" DUCT THROUGH FLOOR TO VENTILATE GREAT SPACE. PROVIDE RECESSED DRYER VENT BOX WITH CONNECTION TO 54" PVC DOWN IN WALL.
 - 6 PROVIDE COMBUSTION AIR KIT THROUGH ROOF, LOCATED AS SHOWN. SIZE PER MANUFACTURER'S RECOMMENDATIONS.
 - 7 COMBUSTION AIR DUCT, TERMINATE 10' ABOVE FINISH FLOOR.
 - 8 HVL-1 VENT PIPE.
 - 9 KESSELER 100, 95% TAKE UP AIR INTAKE GRILLE MOUNTED IN CEILING OF WALKWAY.

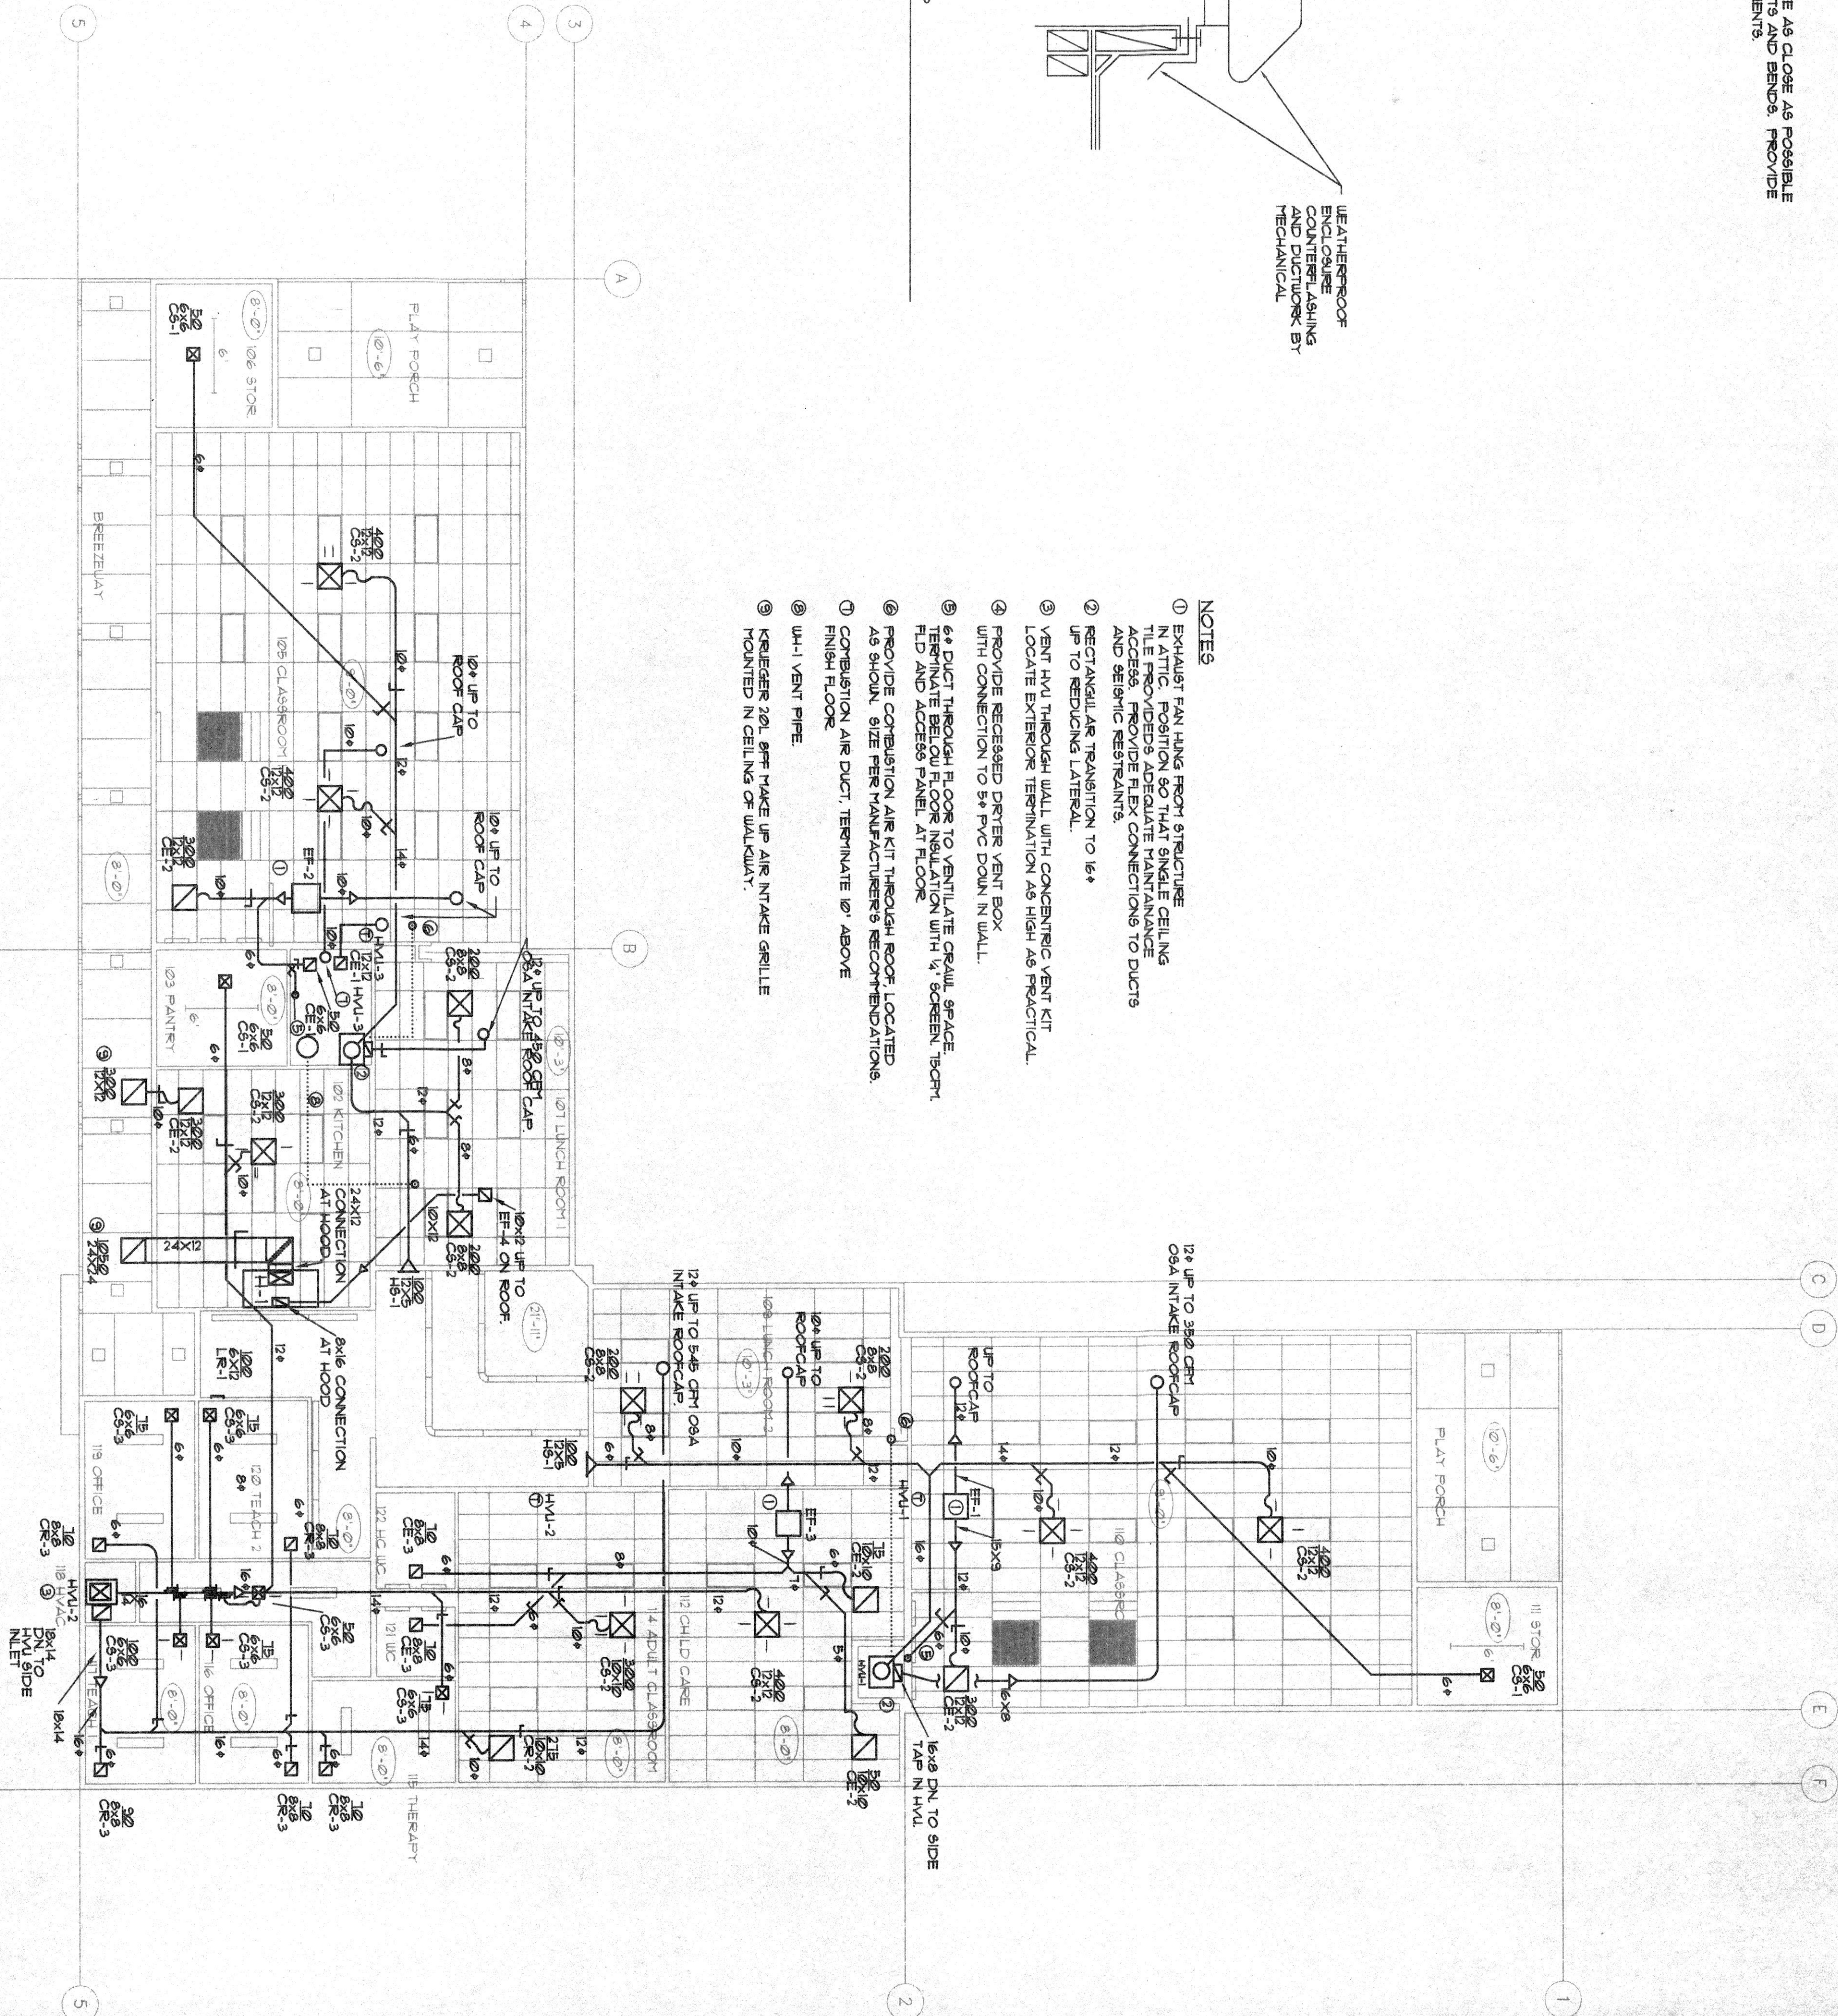

CHRIS
BILLINGS &
ASSOCIATES
CONSULTING ENGINEERS
4445 S.W. BARBUR BLVD
PORTLAND, OR 97201
PH. (503)228-0008
FAX (503)228-2280


PROJECT
HEAD START
CENTER



WARRENTON/ASTORIA

PROJECT NO. 95-0030
FILE NO. HS-M-44w3
DATE JUNE 1, 1995
REVISIONS DATE DISCUSSION

SHEET TITLE
CEILING/ATTIC PLAN
HVAC

SHEET NO. M-4

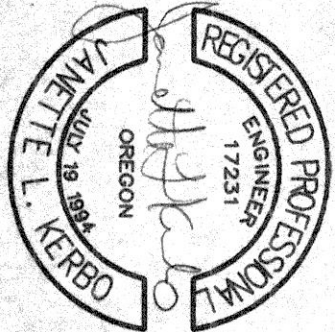

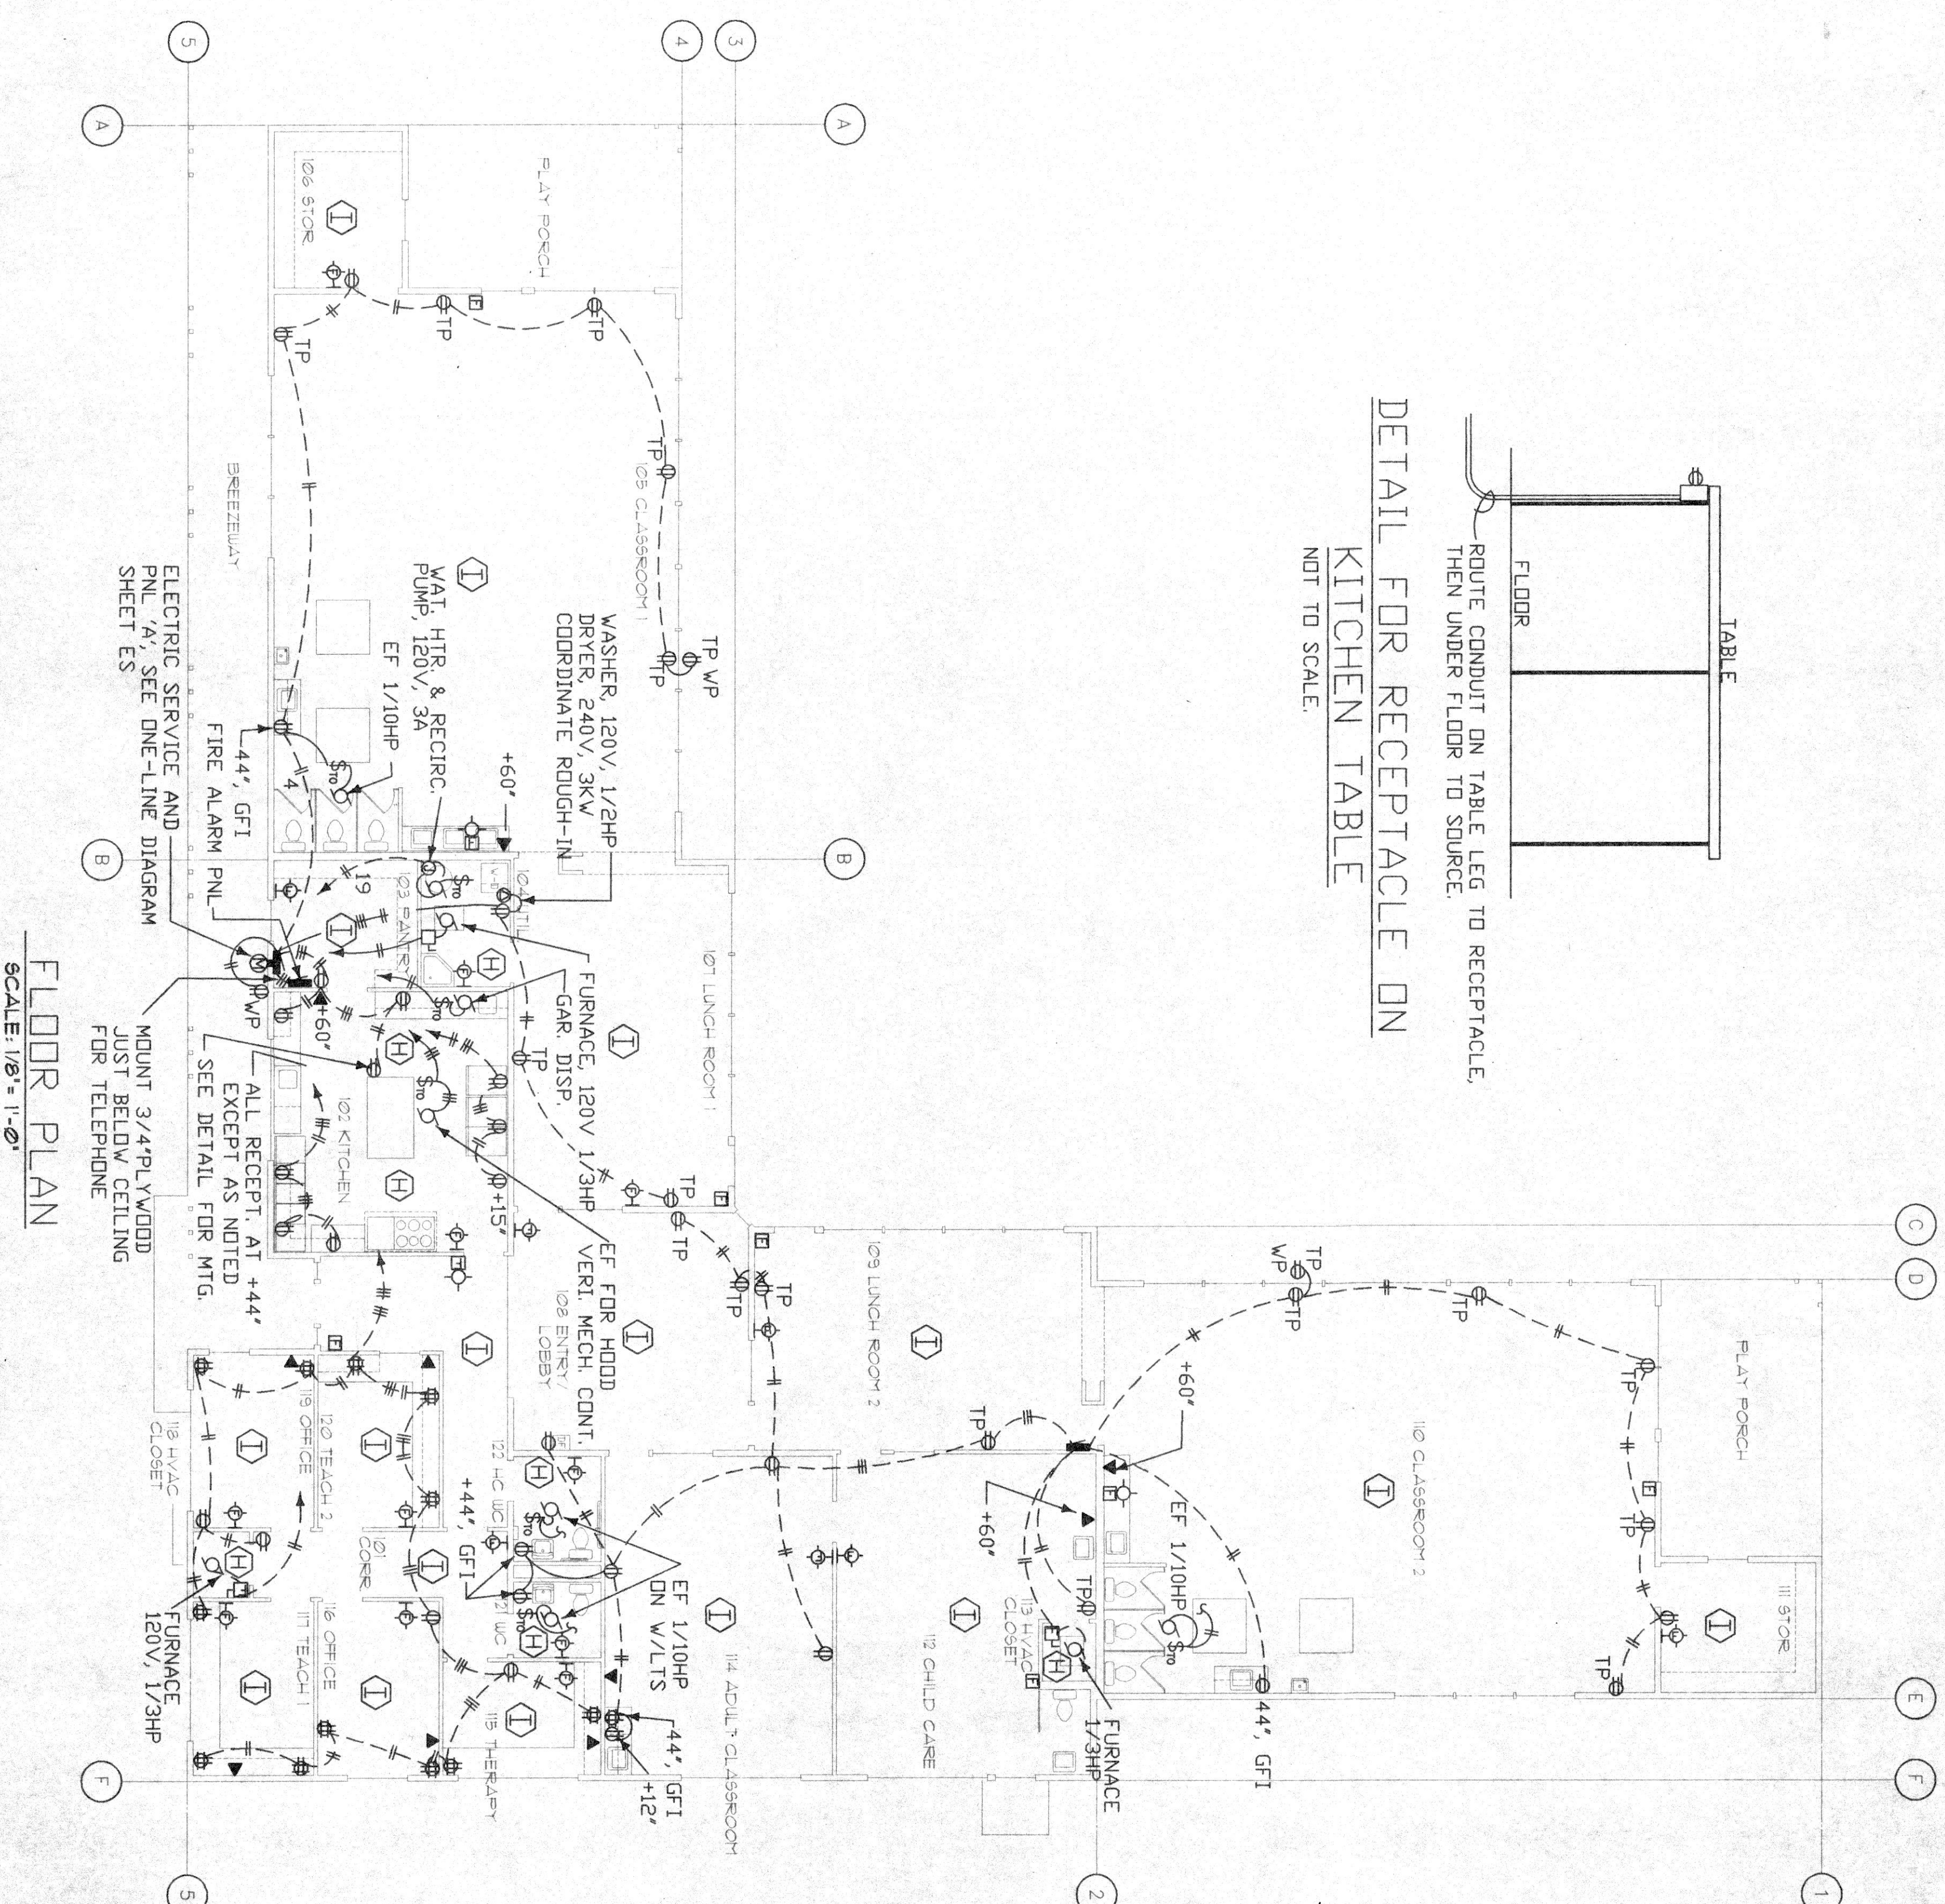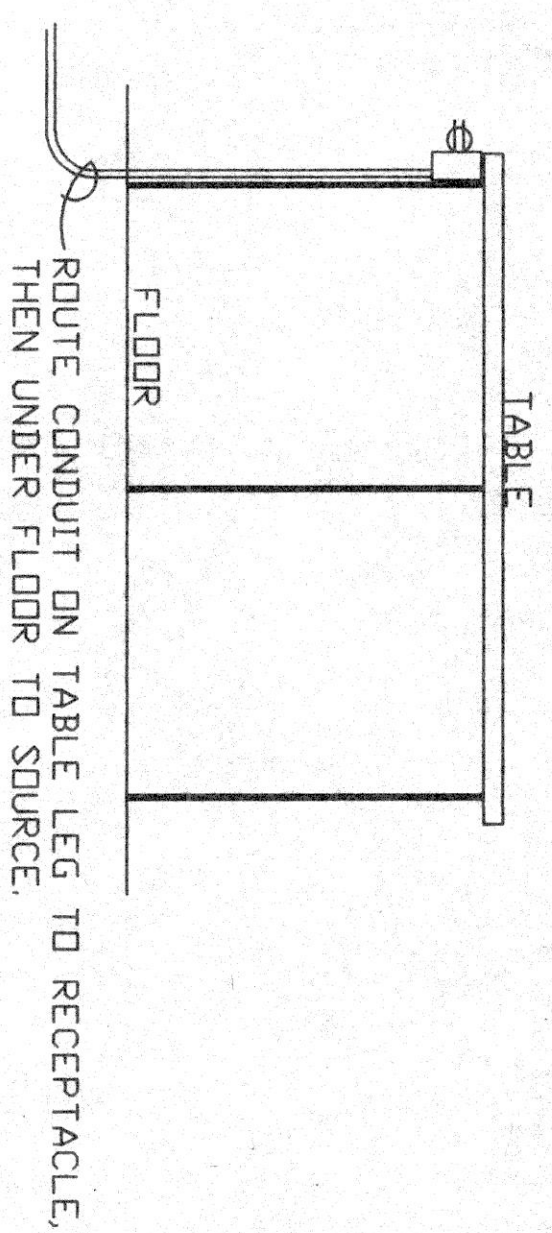


SYMBOL LIST

- Ø DUPLEX RECEPTACLE, MOUNT AT 15'
 - ⊕ DOUBLE DUPLEX RECEPTACLE, MOUNT AT 15'
 - TP TAMPER PROOF
 - Ø MOTOR
 - ⊖ DISCONNECT SWITCH, MOUNT AT 66"
 - ⊖ FIRE ALARM PULL STATION, MOUNT AT 54"
 - ⊕ ADA STROBE LIGHT, MOUNT AT 80"
 - ⊖ FIRE ALARM IONIZATION TYPE SMOKE DETECTOR
 - ⊖ FIRE ALARM HEAT DETECTOR
 - ! BRANCH CIRCUIT PANEL
- * CONDUT AND WIRE CONCEALED IN OR BELOW FLOOR
- * CONDUT AND WIRE CONCEALED IN WALL OR CEILING



COLUMBIA CONSULTING ENGINEERS, Inc.
P.O. BOX 40068 PORTLAND, OR. 97240 (503) 243-2850

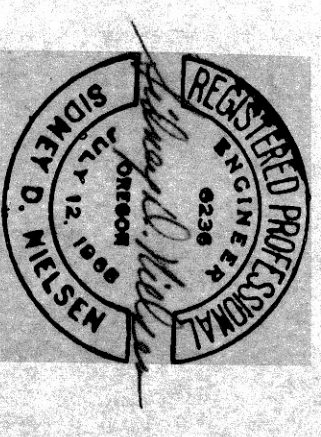


PROJECT HEAD START CENTER


PROJECT NO.	4314
FILE NO.	
DATE	May 25, 1995
REVISIONS	DATE
	DESCRIPTION

SHEET TITLE :
POWER AND
SIGNAL

SHEET NO. E2

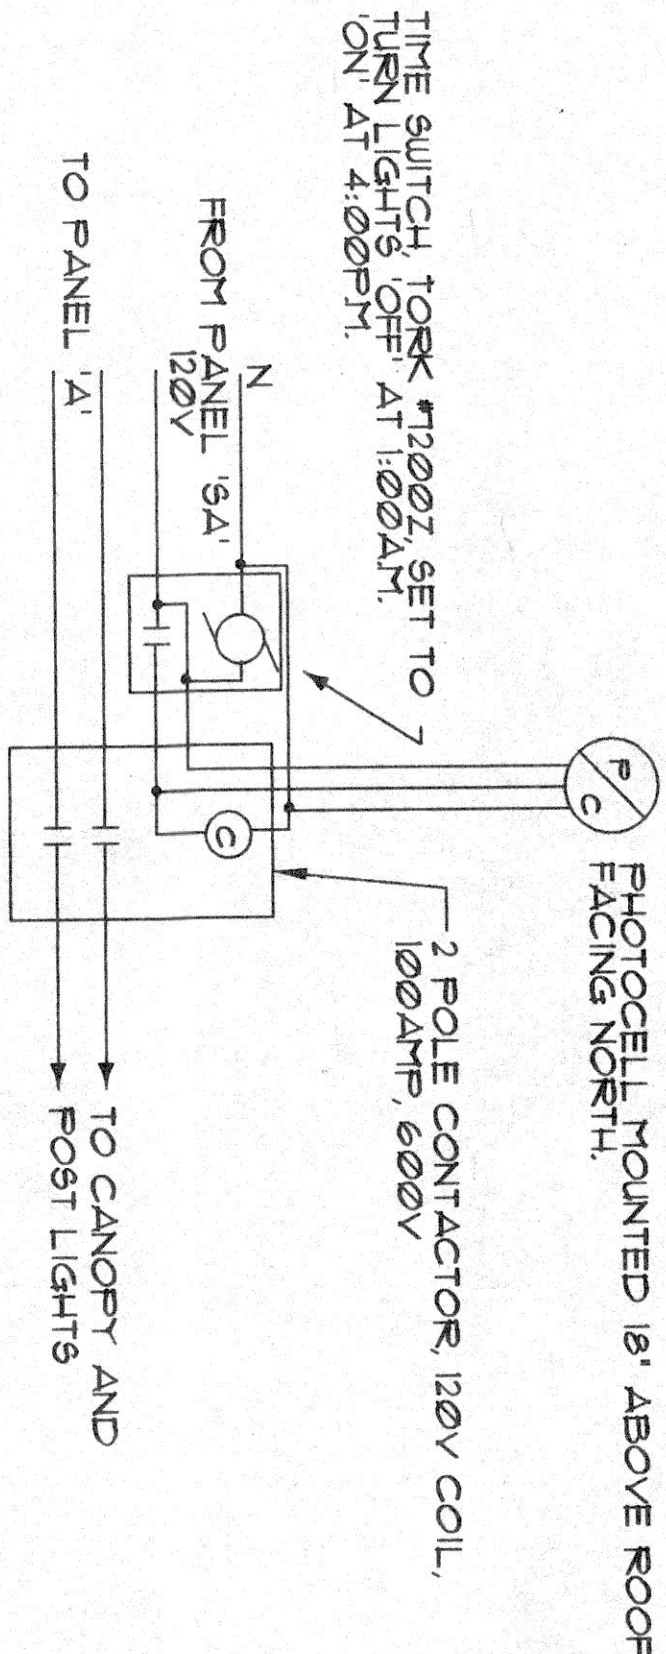


EXTERIOR LIGHTING CONTROL DIAGRAM

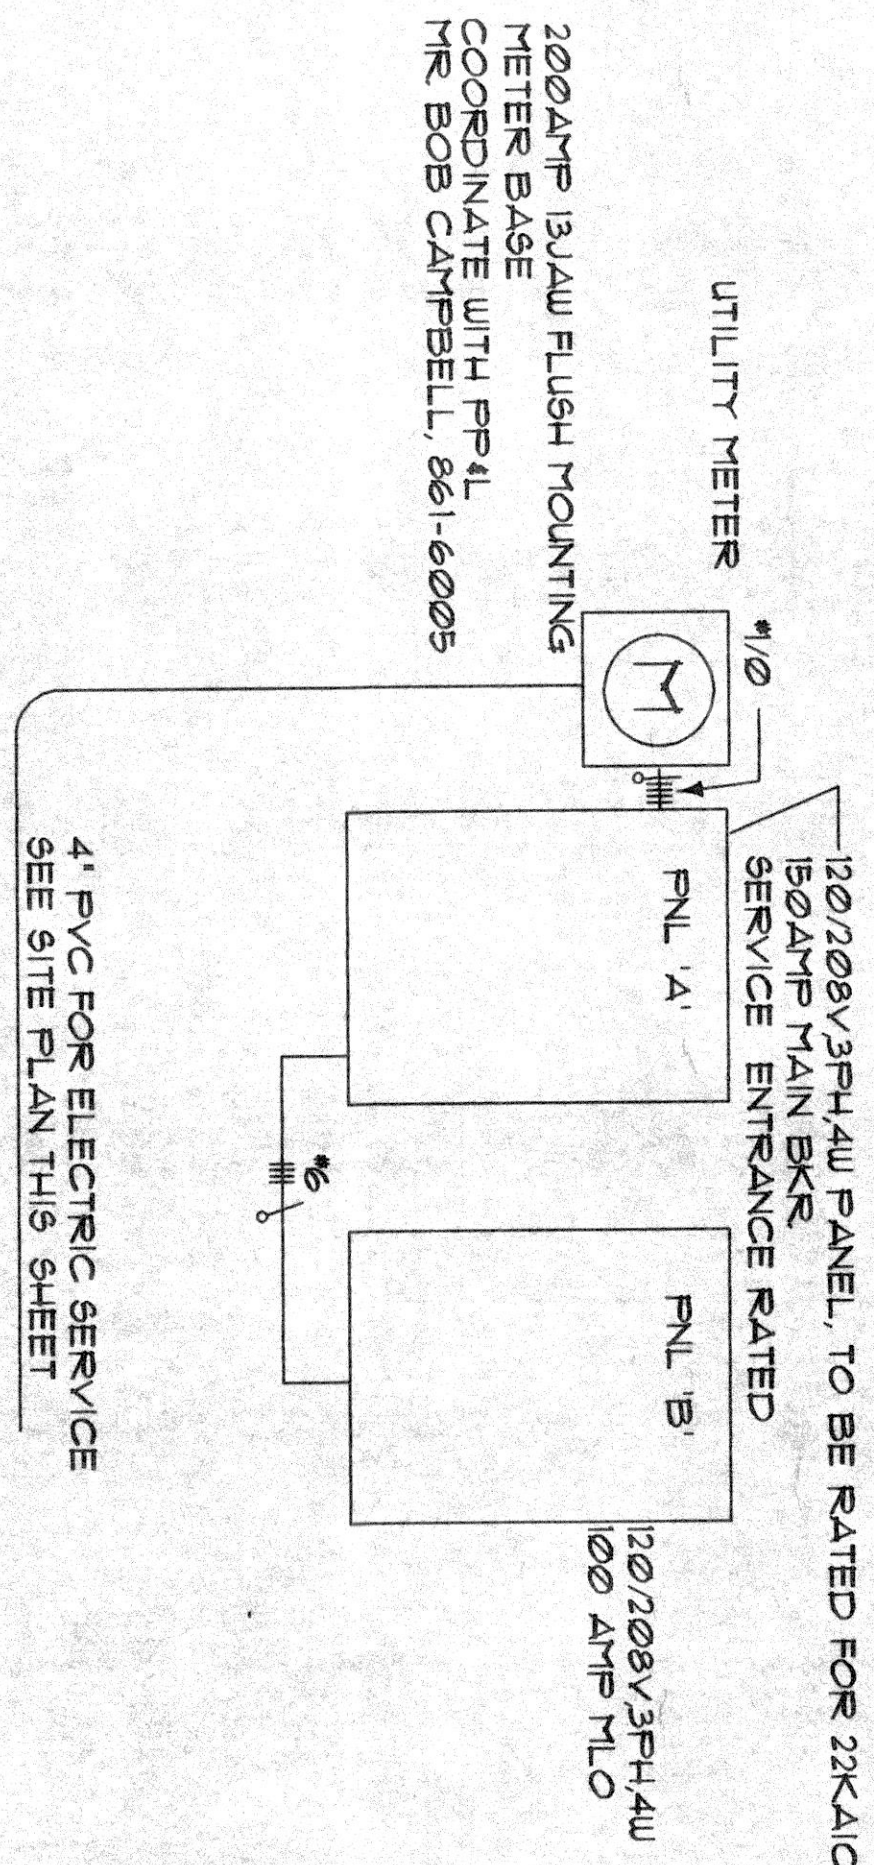

120/240V/1PH/3W ONE-LINE DIAGRAM

PANEL 1A		GROUND BUS		VOLTS 120/208V 3Ø 4W		AMPS 200		MAIN DKT. BKR.		MAIN LUGS ONLY	
NO.	SERVICE	P	A	WATTS	WATTS	NO.	SERVICE	P	A	WATTS	WATTS
1	LIT. EXTERIOR	1	20	1000	1612	2	RECEPT. EXTER.	1	20	360	1260
3	INTERIOR					4	INTERIOR				540
5						8	KITCHEN			360	180
7	RECEPT. OFFICES			1248	1080	10				600	600
9						12				180	180
11						14				180	180
13						16				180	180
15						18				180	180
17	FINANCE			300	1260	20				180	180
19	WASH. & RAMP			200	1260	22				180	180
21	WASHER			200	1260	24				180	180
23	DRYER			200	1260	26				180	180
25						28				180	180
27	PNL 1A			500	2667	30	FIRE ALARM			600	600
29						32	SPACE			400	400
31						34					
33						36					
35						38					
37						40					
39						42					
41											
TOTAL WATTS		8224		1819	8019	PHASE WATTS		2100		2400	1900
						PHASE AMPS		85			

PANEL 1B		GROUND BUS		VOLTS 120/208V 3Ø 4W		AMPS 60		MAIN DKT. BKR.		MAIN LUGS ONLY	
NO.	SERVICE	P	A	WATTS	WATTS	NO.	SERVICE	P	A	WATTS	WATTS
1	LIT. INTERIOR	1	20	912	930	2	RECEPT. EXT.	1	20	360	1260
3						4	INTERIOR			1260	1260
5						6				1260	1260
7	FINANCE			1200	1100	8				1260	1260
9	SPACE					10				1260	1260
11						12				1260	1260
13						14				1260	1260
15						16				1260	1260
17						18				1260	1260
19						20				1260	1260
21						22				1260	1260
23						24				1260	1260
25						26				1260	1260
27						28				1260	1260
29						30				1260	1260
31						32				1260	1260
33						34				1260	1260
35						36				1260	1260
37						38				1260	1260
39						40				1260	1260
41						42				1260	1260
TOTAL WATTS		1192		930	1100	PHASE WATTS		1440		1700	1030
						PHASE AMPS		22.2			

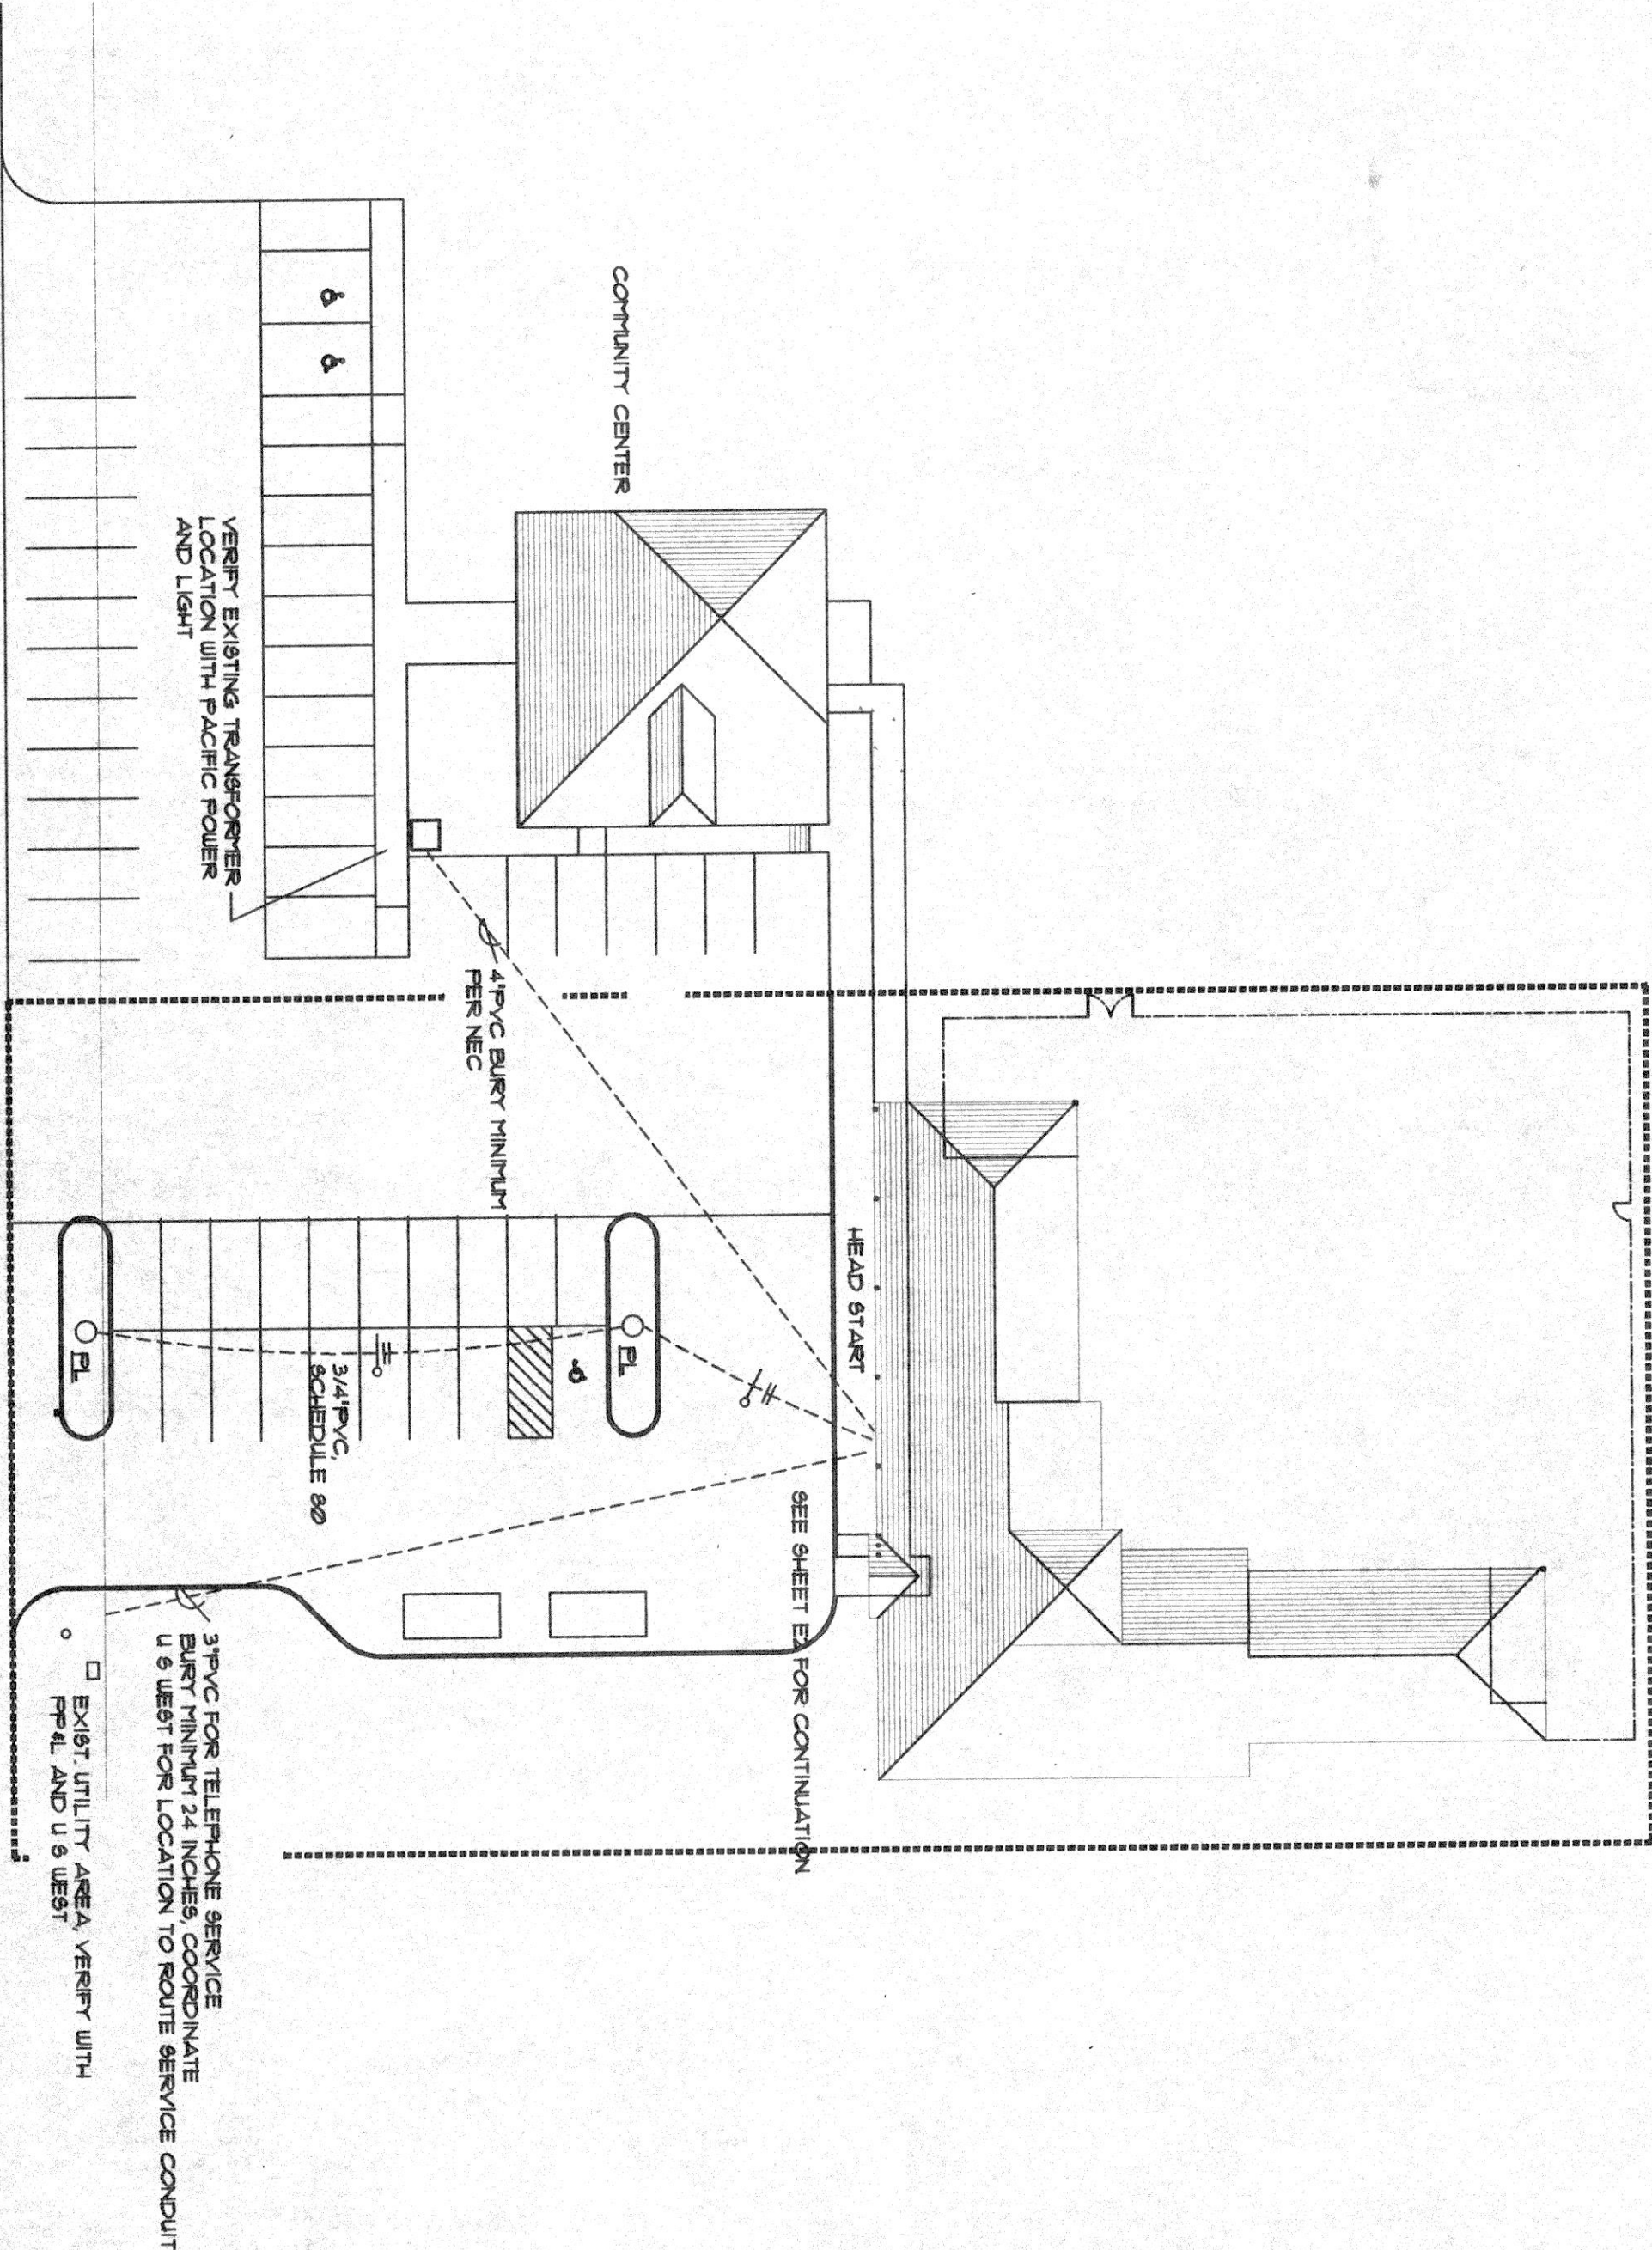

SITE PLAN

PROJECT: HEAD START CENTER

WARRENTON/ASTORIA WARRENTON, OREGON

DATE: JUNE, 21, 1995

DESIGNER: [Signature]


REVISION: [Signature]

SHEET TITLE: SITE PLAN - ELECTRICAL

SHEET NO. ES

IRRIGATION PLAN

SCALE 1"=30'-0"

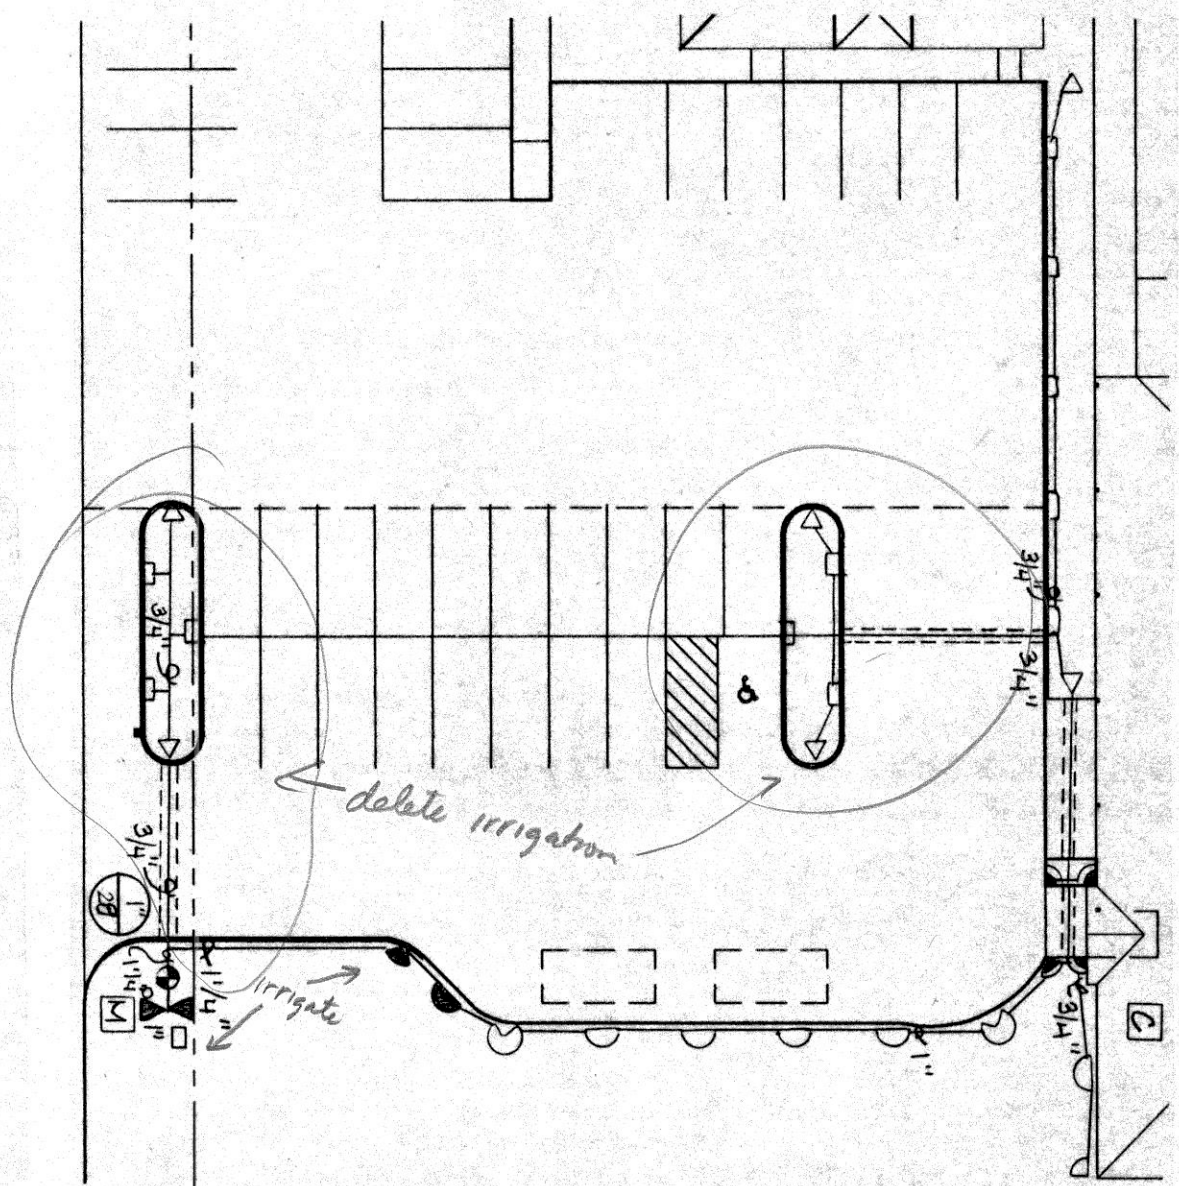


LEGEND

- Existing Water Meter. Location is approximate, verify in field.
- 1" Feco 805Y Backflow Preventer in Ametek #190106 Meter Box with Green CV cover installed per local codes and manufacturers specifications. With a 1" Nibco T1-8 Gate Valve in Ametek 10" Box & Cover. Location is approximate, verify in field.
- 1" Weathermatic 11024 Valve in Ametek #170106 Standard Box & Cover installed per local codes & manufacturers specifications.
- Toro 5702 Series 4-EST-PC
- Toro 5702 Series 9-SST-PC
- Toro 5702 Series 10-Q-H-PC
- Toro 5702 Series 5-H-TT-PC
- Toro 5702 Series 5-Q-PC
- CONTROLLER NELSON 8424 (Controller to be located in field by Landscape Architect)


3" PVC Sleeve

PLANTING DETAILS

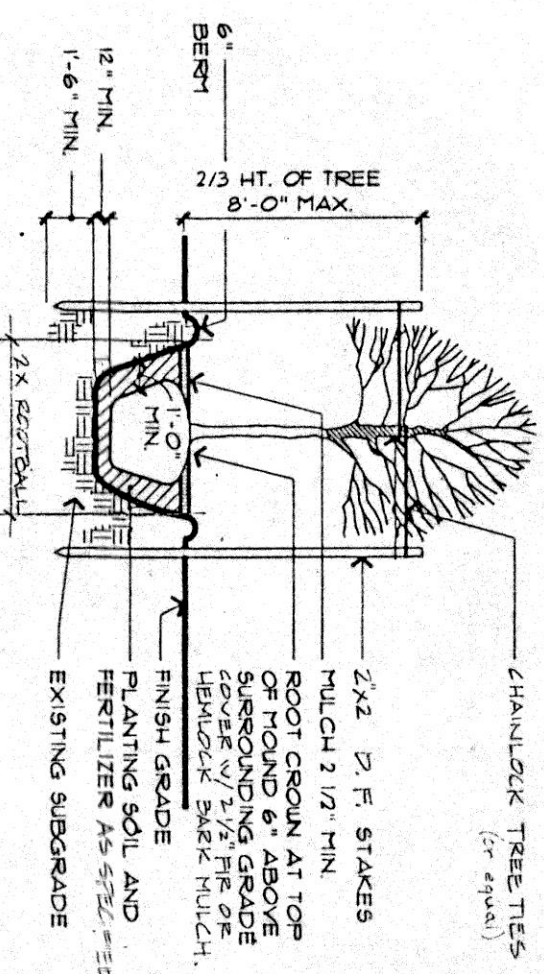

DECIDUOUS TREE PLANTING DETAIL

NOT TO SCALE

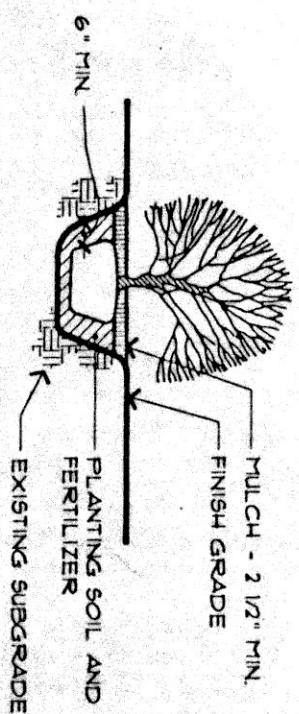


SHRUB PLANTING DETAIL

NOT TO SCALE

GENERAL NOTES

- THE CONTRACTOR SHALL EXAMINE THE SITE AND FAMILIARIZE HIMSELF WITH ALL CONDITIONS PERTINENT TO THIS WORK.
- IT WILL BE THE CONTRACTOR'S RESPONSIBILITY TO DETERMINE THE LOCATION OF ALL EXISTING UTILITIES AND AVOID DAMAGE TO THE SAME.
- SPRING SHOWN IS DIAGRAMMATIC. CONTRACTOR SHALL ROUTE SPRING TO AVOID CONFLICT WITH EXISTING CONDITIONS OR EXISTING UTILITIES.
- ACTUAL FIELD CONDITIONS MAY NECESSITATE ADDING, DELETING, OR MAKING MINOR ADJUSTMENTS IN SPRING HEADS TO INSURE UNIFORM COVERAGE.
- ALL MAINLINES TO BE A MINIMUM OF 18" BELOW GRADE. LATERAL LINES TO BE A MINIMUM OF 12" BELOW GRADE.
- INSTALL 3/4" BRASS MANUAL DRAIN VALVES AT LOW POINTS OR END OF MAINLINES. BE VALVES TO BE INSTALLED WITH A VALVE MARKER AND COVER.
- A TRACER WIRE SHALL BE INSTALLED ALONG THE TOP OF ALL PIPING OR NONMETALLIC COMPOSITION, SUCH AS PVC MAINLINES AND LATERALS. TAP TO PIPING AT 10-FOOT INTERVALS WITH STANDARD BLACK 3/4" ELECTRICAL TAPE.
- POINT OF CONNECTION IS SHOWN IN APPROXIMATE LOCATION DUE TO SITE CONDITIONS AND LOCATION OF THE WATER METER.
- ALL SHRUB BED POPS MUST HAVE A 4" RISER AND ALL LAWN POPS TO HAVE A 6" RISER.
- GUARANTEE: ALL MATERIALS AND LABOR USED IN CONSTRUCTION OF THE IRRIGATION SYSTEM SHALL BE FULLY GUARANTEED FOR ONE YEAR FROM THE DATE OF ACCEPTANCE BY THE OWNER.

COMMUNITY CENTER

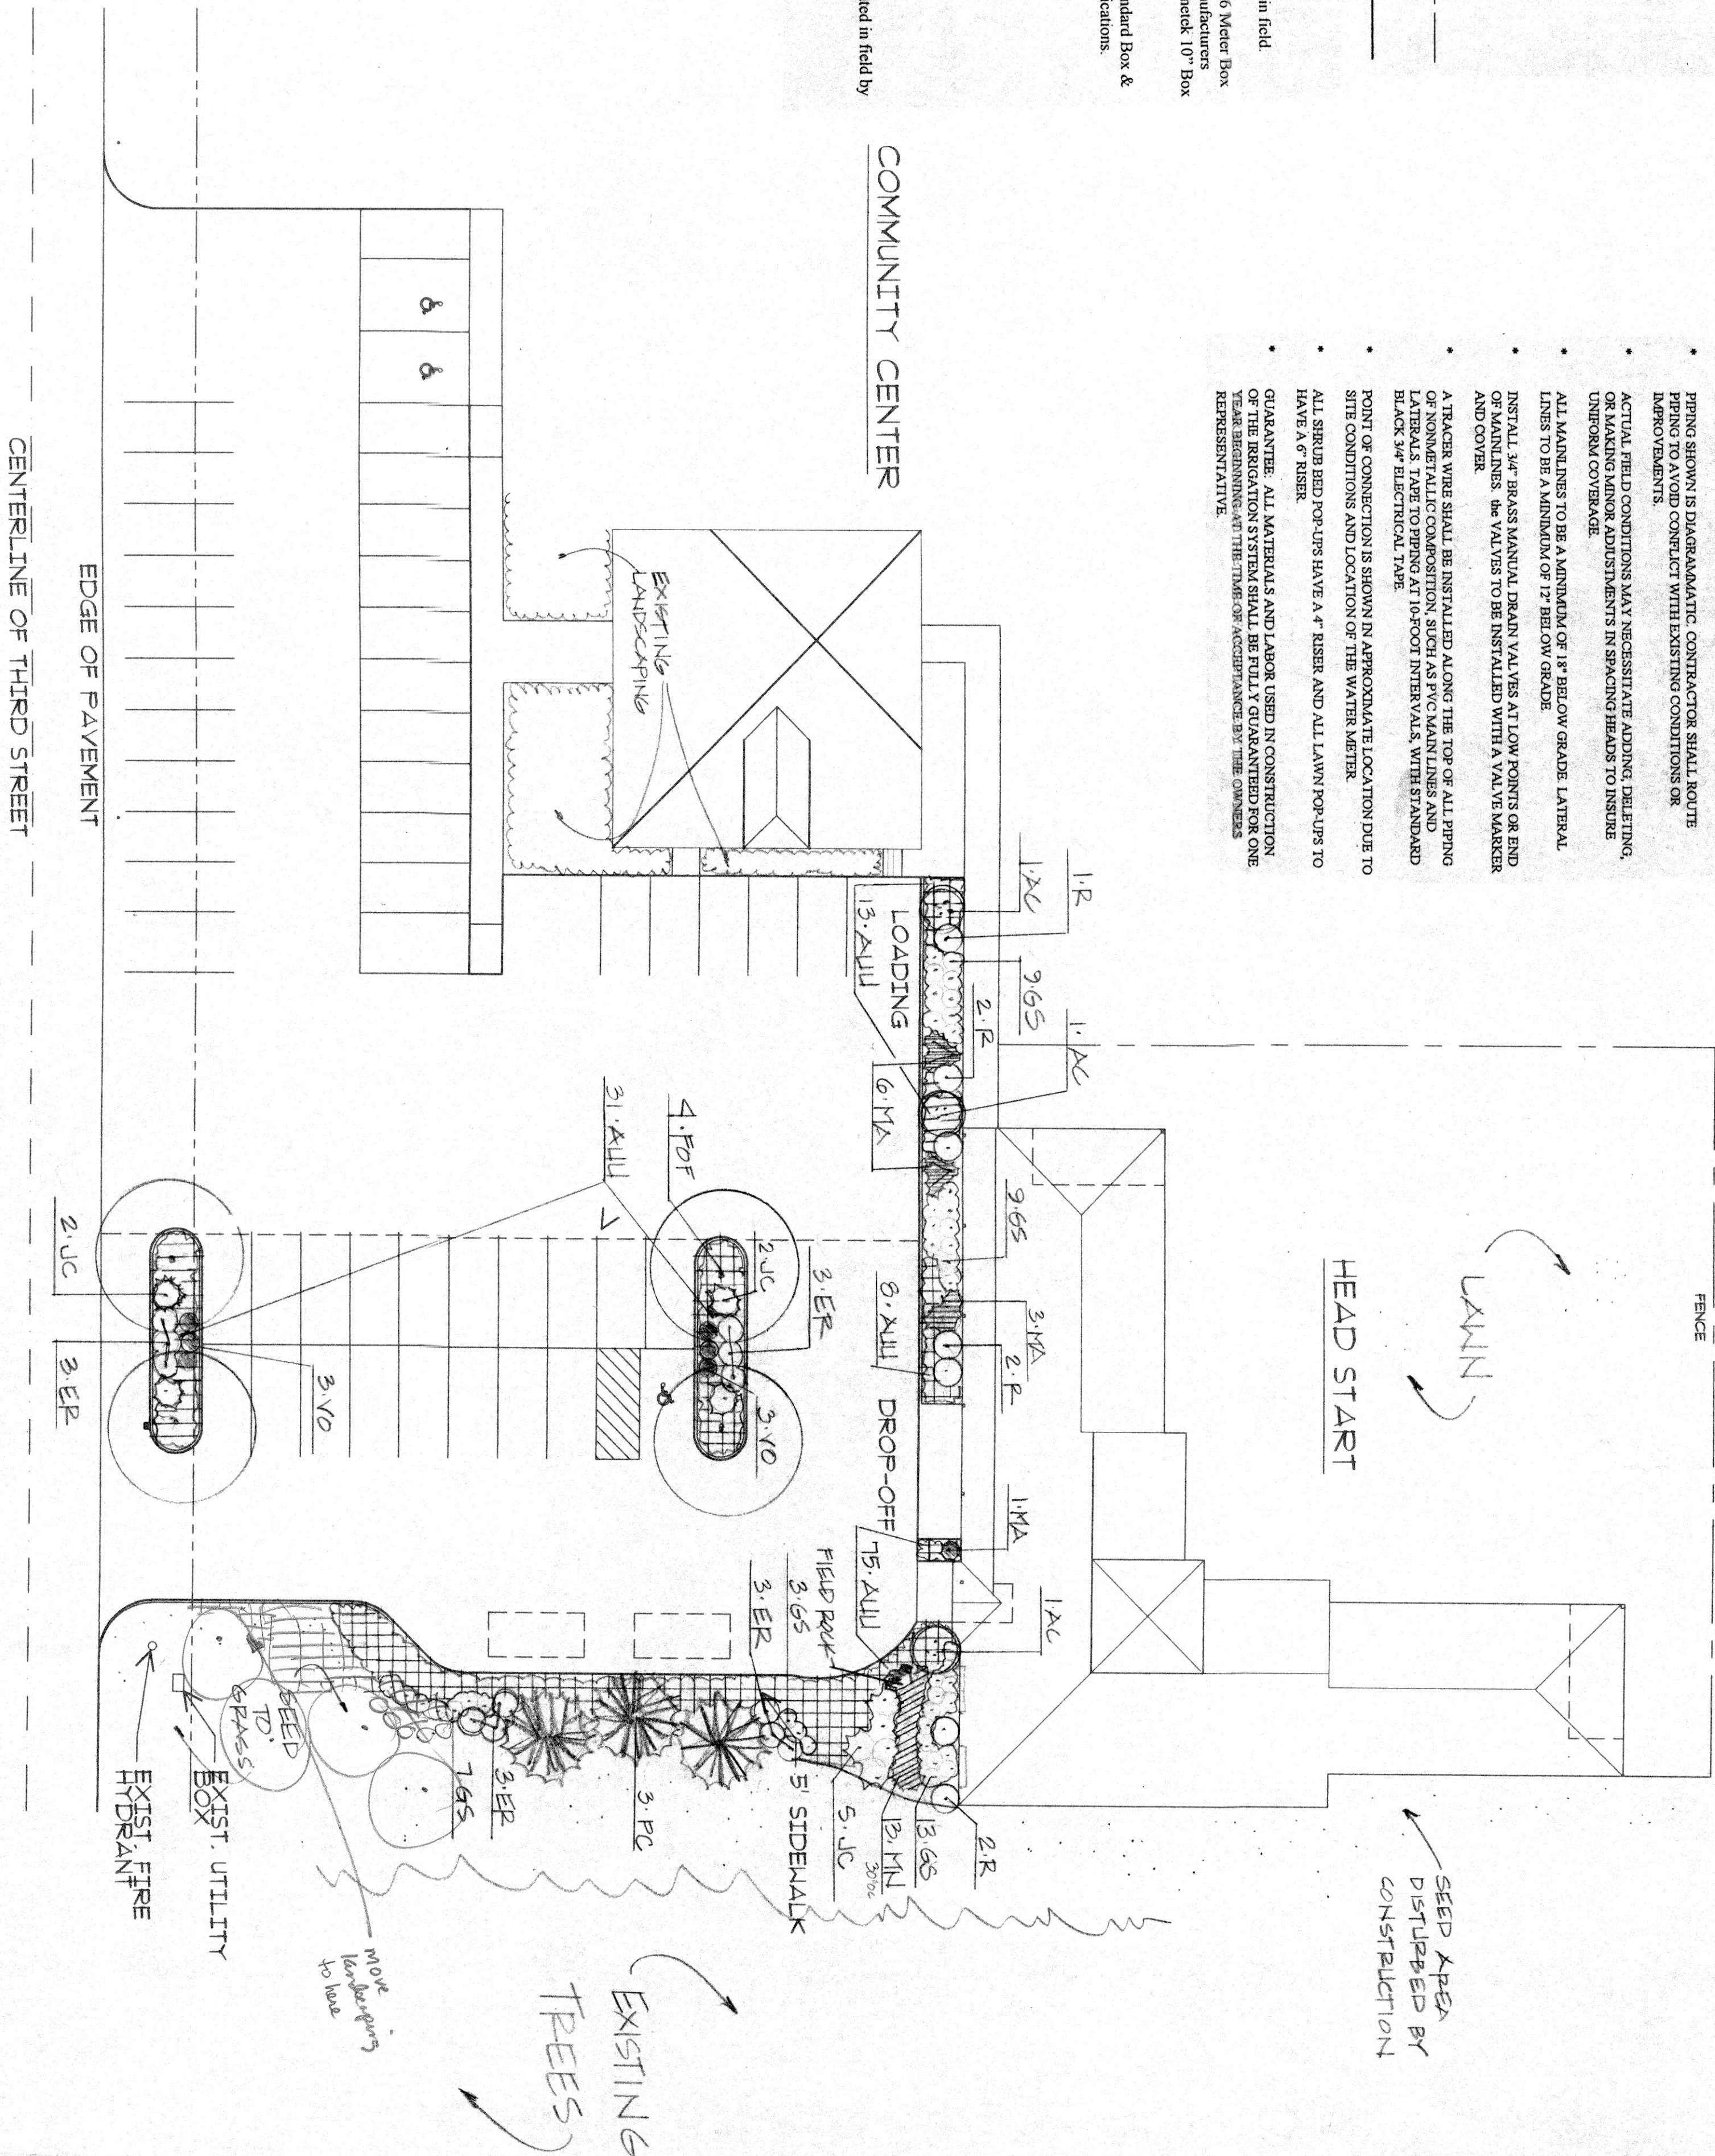

CENTERLINE OF THIRD STREET

EDGE OF PAVEMENT

PLANT LIST	QTY.	KEY	NAME	SIZE	SPACING
GRONNOCYPERUS					
127	ADU		ARCTOSTAPHYLOS UVA-URSI "WASS."	1 gal.	3' x 3' c.
13	NH		MAMMILLARIA MEXICANA (Longleaf Mammoth)	2 gal.	2' x 2' c.
SHRUBS:					
12	ER		ESCALONIA "APPLE BLOSSOM"	5 gal.	4' x 4' c.
41	GS		GAUTHIERIA SHALON (Sisal)	2 gal.	3' x 3' c.
9	JC		JUNIPERUS COMMENSALIS "BLUE PACIFIC"	2 gal.	5' x 5' c.
10	MA		MADONIA (Oregon Grape)	24"	3' x 3' c.
7	R		RHOISODENDRON "SCINTILLATION"	21"	5' x 5' c.
6	VO		VACCINIUM OXYCOCOS (Evergreen Huckleberry)	2 gal.	3' x 3' c.
3	AC		ACER CIRCINATUM (Vine Maple, Min. 4 Stem)	8'	as shown
4	PO		POPPUS (Pine)	2" cal.	"
3	PC		PRUNUS COMPTONII (Shore Pine)	6-7'	12' x 12' c.

NOTES:

- CONTRACTOR TO VERIFY ALL PLANT QUANTITIES.

ORIGINS SPECIFICATION - PLANTING AND SEEDING

GENERAL: All plants shall conform to all applicable standards of the latest edition of the American Standard for Nursery Stock. Plants shall be healthy, well branched and rooted, formed into a well-balanced shape, free of disease, injury, defects, insects, weeds, and other undesirable growth. Plants shall have straight trunks, symmetrical tips, and have an adequate number of leaves. Plants shall be free of any other defects or damage.

SEEDING: All seed shall be of the highest quality and shall be certified by a reputable seed company. Seed shall be sown in a well-prepared seed bed, and shall be covered with a layer of soil. Seed shall be watered regularly and shall be protected from birds and other animals.

PLANTING: All plants shall be planted in a well-prepared planting hole, and shall be watered regularly. Plants shall be protected from birds and other animals.

SEEDLING: All seedlings shall be sown in a well-prepared seed bed, and shall be covered with a layer of soil. Seedlings shall be watered regularly and shall be protected from birds and other animals.

TRANSPLANTING: All transplants shall be sown in a well-prepared seed bed, and shall be covered with a layer of soil. Transplants shall be watered regularly and shall be protected from birds and other animals.

REMOVAL: All plants shall be removed from the site as soon as they are no longer needed. Plants shall be removed in a well-prepared manner, and shall be disposed of properly.

MAINTENANCE: All plants shall be maintained in a well-prepared manner, and shall be watered regularly. Plants shall be protected from birds and other animals.

NOTIFICATION: The contractor shall notify the landscape architect 48 hours in advance of the location of the plants. Final location shall be approved by the landscape architect.



OTTEN & ASSOCIATES, INC. • LANDSCAPE ARCHITECTS
Post Office Box 213 • Beaverton, Oregon 97005 • Phone (503) 641-5086 • Fax (503) 641-5092
11855 S.W. Ridgeway Dr. • Suite 405 • Beaverton, Oregon 97006

WARRENTON HEAD START
WARRENTON, OREGON

LANDSCAPE PLAN

DATE 06/09

SCALE 1"=20'-0"

DRAWN 06/05

CHECKED

SHEET NO.

INFORMATION ON THIS DOCUMENT IS NOT
APPROVED FOR CONSTRUCTION UNTIL A
BUILDING PERMIT HAS BEEN ISSUED.

OTTEN & ASSOCIATES, INC.
WARRENTON 6/17/95 14:14:33